



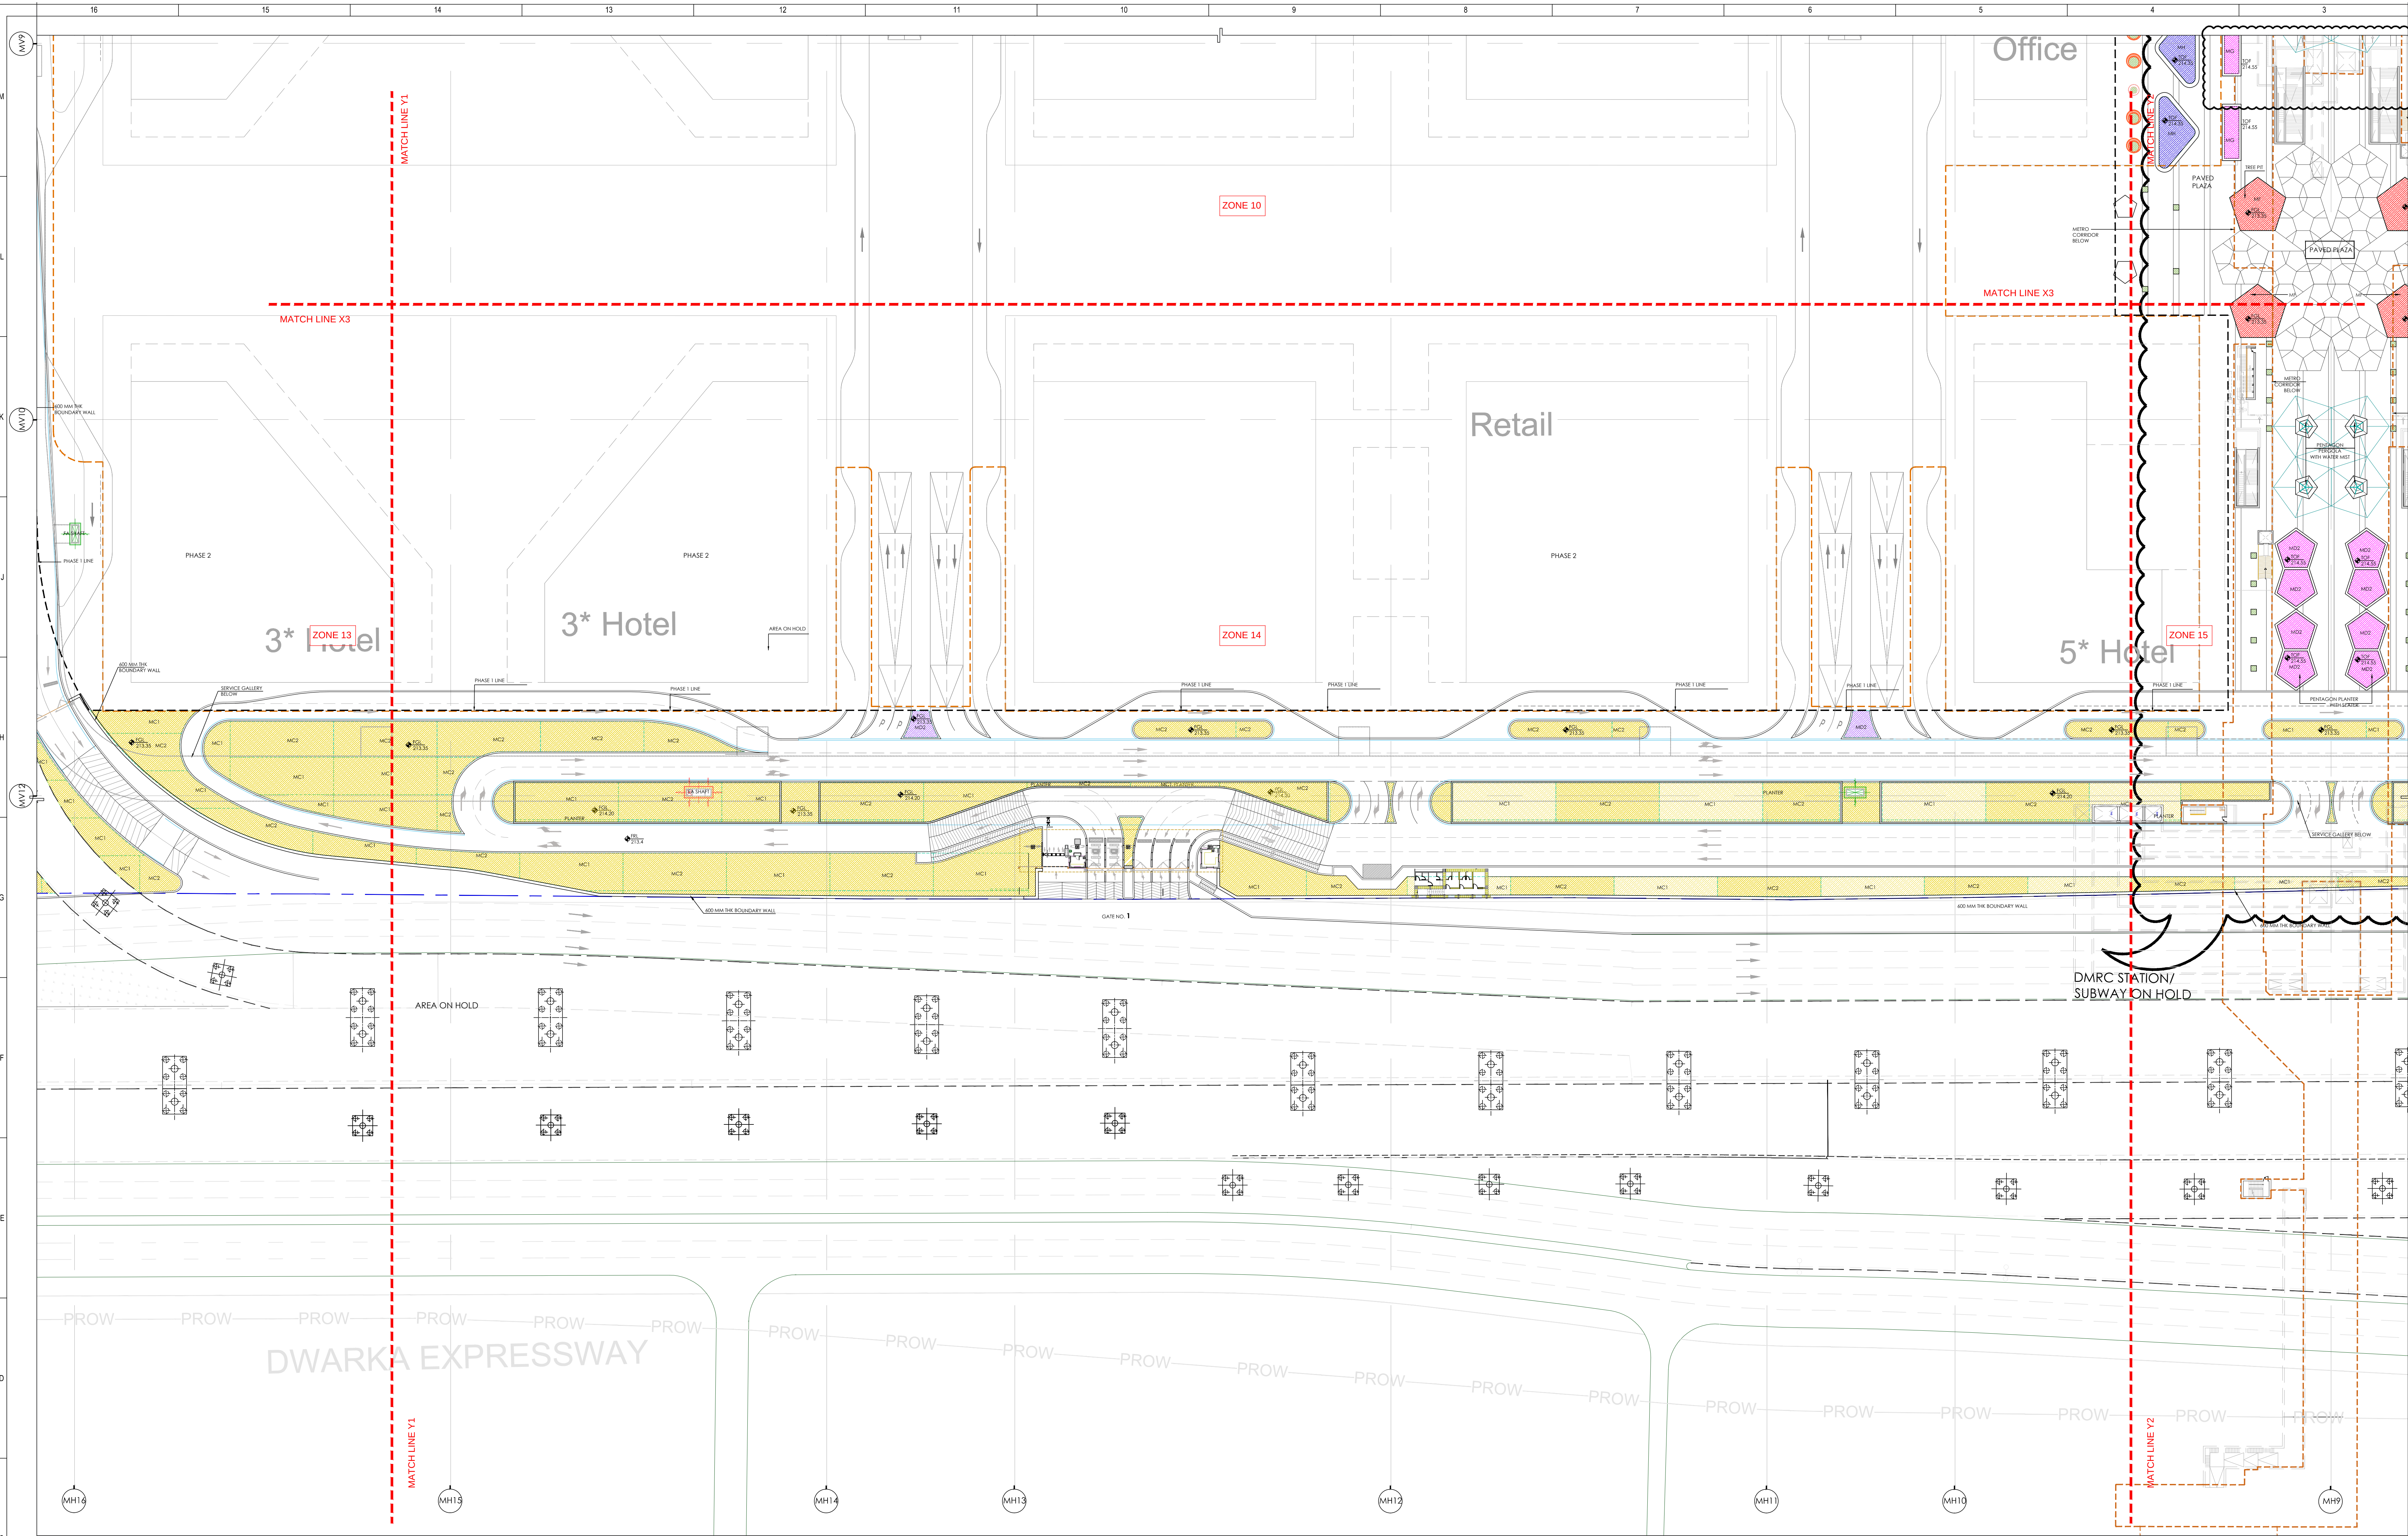

PLANTING MODULE FOR SHRUBS AND GROUND COVERS

(Refer O17203-N-SP-00-WD-0817 sheet for details)

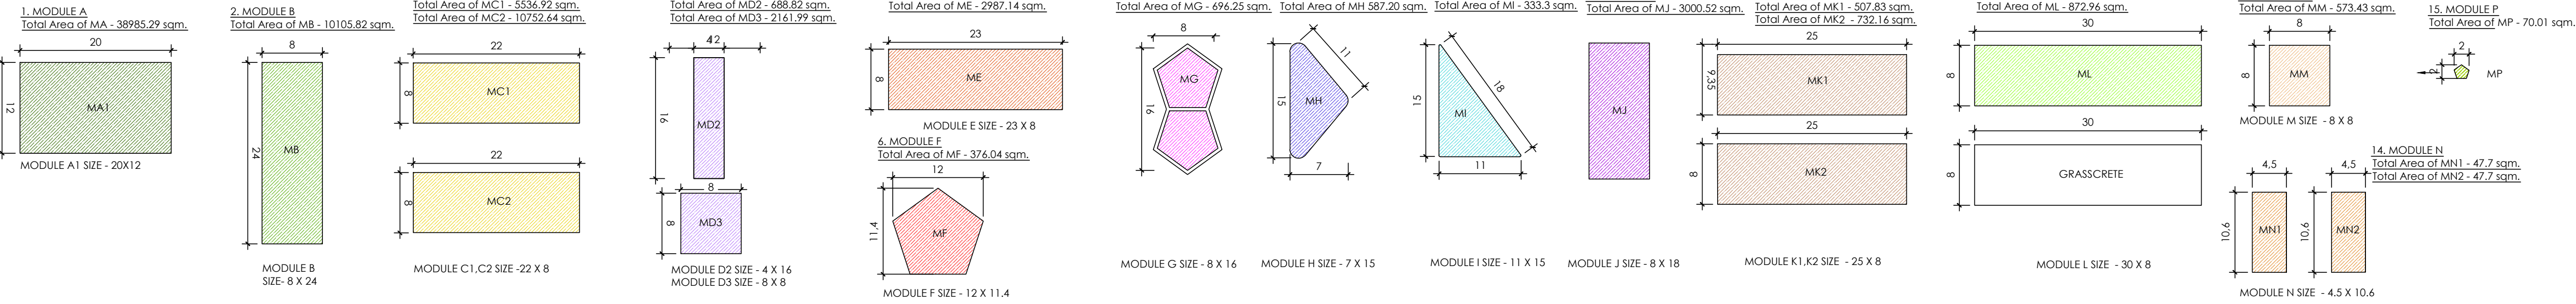

- O17203-N-SP-00-WD-(0800-0816)-PLANTING SET - TO BE REFERRED FOR FOLLOWING POINTS :**
1. All dimensions are in Meter. Dimensions to be read and shall not be measured from the drawing.
 2. View locations are provided only for reference.
 3. For specifications of the shrubs & ground covers refer separate document.
 4. Green areas and Planting of lower canopy are shown in colored hatches. To get clear understanding prints should be taken in colour.
 5. Metro corridor line depiction in orange colour.
 6. Lower canopy layouts do not show details for the modules. Refer drawing no. O17203-N-SP-00-WD-0817 for the same.
 7. Service gallery and tunnel coming in green areas and landscape plazas to be designed for the tree loading.

- ABBREVIATIONS :**
1. FRL - FINISHED ROAD LEVEL
 2. FFL - FINISHED PAVED LEVEL
 3. FGL - FINISHED GROUND LEVEL
 4. BPL - BUILDING PAVED LEVEL
 5. TOF - TOP OF FILL

LEGEND:

- METRO LINE
- PHASE 1 LINE
- PHASE 2 ZONE

NORTH:

Key Plan:

Owner / Employer

India International Convention & Exhibition Centre Limited
Room No. 824, Ministry of Commerce & Industry,
DFP, 10/10/10, New Delhi - 110011, India

Department of Industrial Policy and Promotion Ministry of Commerce & Industry Government of India

Knowledge Partner

Dehi Mumbai Industrial Corridor Development Corporation
Room No. 341 & 342, 3rd Floor, 10/10/10, New Delhi - 110011, India

Employer's Representative

Employer Engineer
Programme Management Consultant (PMC)

AECOM

Preliminary Engineering Architecture Consultants (PEAC)

Idom

Ac, Del Mar, 10/10/10, New Delhi - 110011, India

EPC Contractor

L&T Construction
Buildings & Factories
Mount Poonam Road, Mangalore,
P.O. No. 177, Chennai - 600 089

EPC Contractor's Representatives

Design Consultant
Engineering Design and Research Center (EDRC)
L&T Construction - Buildings & Factories

Architectural Consultant
ARCOOP
Arco Associates Pvt. Ltd.,
A-15, Preeti Park, Gurgaon,
New Delhi - 110048, India

Structural Proof Consultant
Indian Institute of Technology (IIT) Madras
Sector Park Road, Chennai - 600 075, India

MEP Proof Consultant
Egis India Consulting Engineers Pvt. Ltd.,
Plot No. 46, Sector 12, Industrial Area,
Gurgaon, Haryana - 122002

ICT Proof Consultant
CKR Consulting Engineers Pvt. Ltd.,
4/771, 3rd Floor, Naraina Area,
Suburban Road, New Delhi - 110028, India

Certification

EPC Contractor

Design Consultant

Architectural Consultant

Proof Consultant

Structural

MEP

ICT

PEAC

Issued by:
Employer / Employer's Engineer

Revisions

REV	DESCRIPTION	DATE	DESIGN	CHKD	APPD
1	ISSUED FOR CONSTRUCTION	11/01/18	NL	TA	NL

Revisions

REV	DESCRIPTION	DATE	DESIGN	CHKD	APPD
1	ISSUED FOR CONSTRUCTION	11/01/18	NL	TA	NL

EPC Contractor

L&T Construction
Buildings & Factories

JOB No : O17203

Project Name
DESIGN AND CONSTRUCTION OF INDIA INTERNATIONAL CONVENTION & EXPO CENTRE
SECTOR 25, DWARKA, NEW DELHI, INDIA

Drawing Status
GOOD FOR CONSTRUCTION (GFC)

Drawing No
N 00 0814 R0

Rev. No
R0

Title :
LANDSCAPE PLANTING PLAN - LOWER CANOPY: ZONE 14

EDRC DWG No :
O17203-N-SP-00-WD-0814

Scale
1:500

Sheet Size
A0



EPC Contractor

L&T Construction

Buildways & Facilities

JOB No : 017023

Project Name

DESIGN AND CONSTRUCTION OF INDIA
INTERNATIONAL CONVENTION & EXPO CENTRE

SECTOR 25, DWARKA, NEW DELHI, INDIA

Drawing Status

GOOD FOR CONSTRUCTION (GFC)

Drawing No

Rev. No

N

00

0815

RO

Title :

LANDSCAPE PLANNING PLAN -
LOWER CANOPY: ZONE 15

EDRC DWG No :


Scale

Sheet Size


017203-N-SP-00-WD-0815

1:500

A3

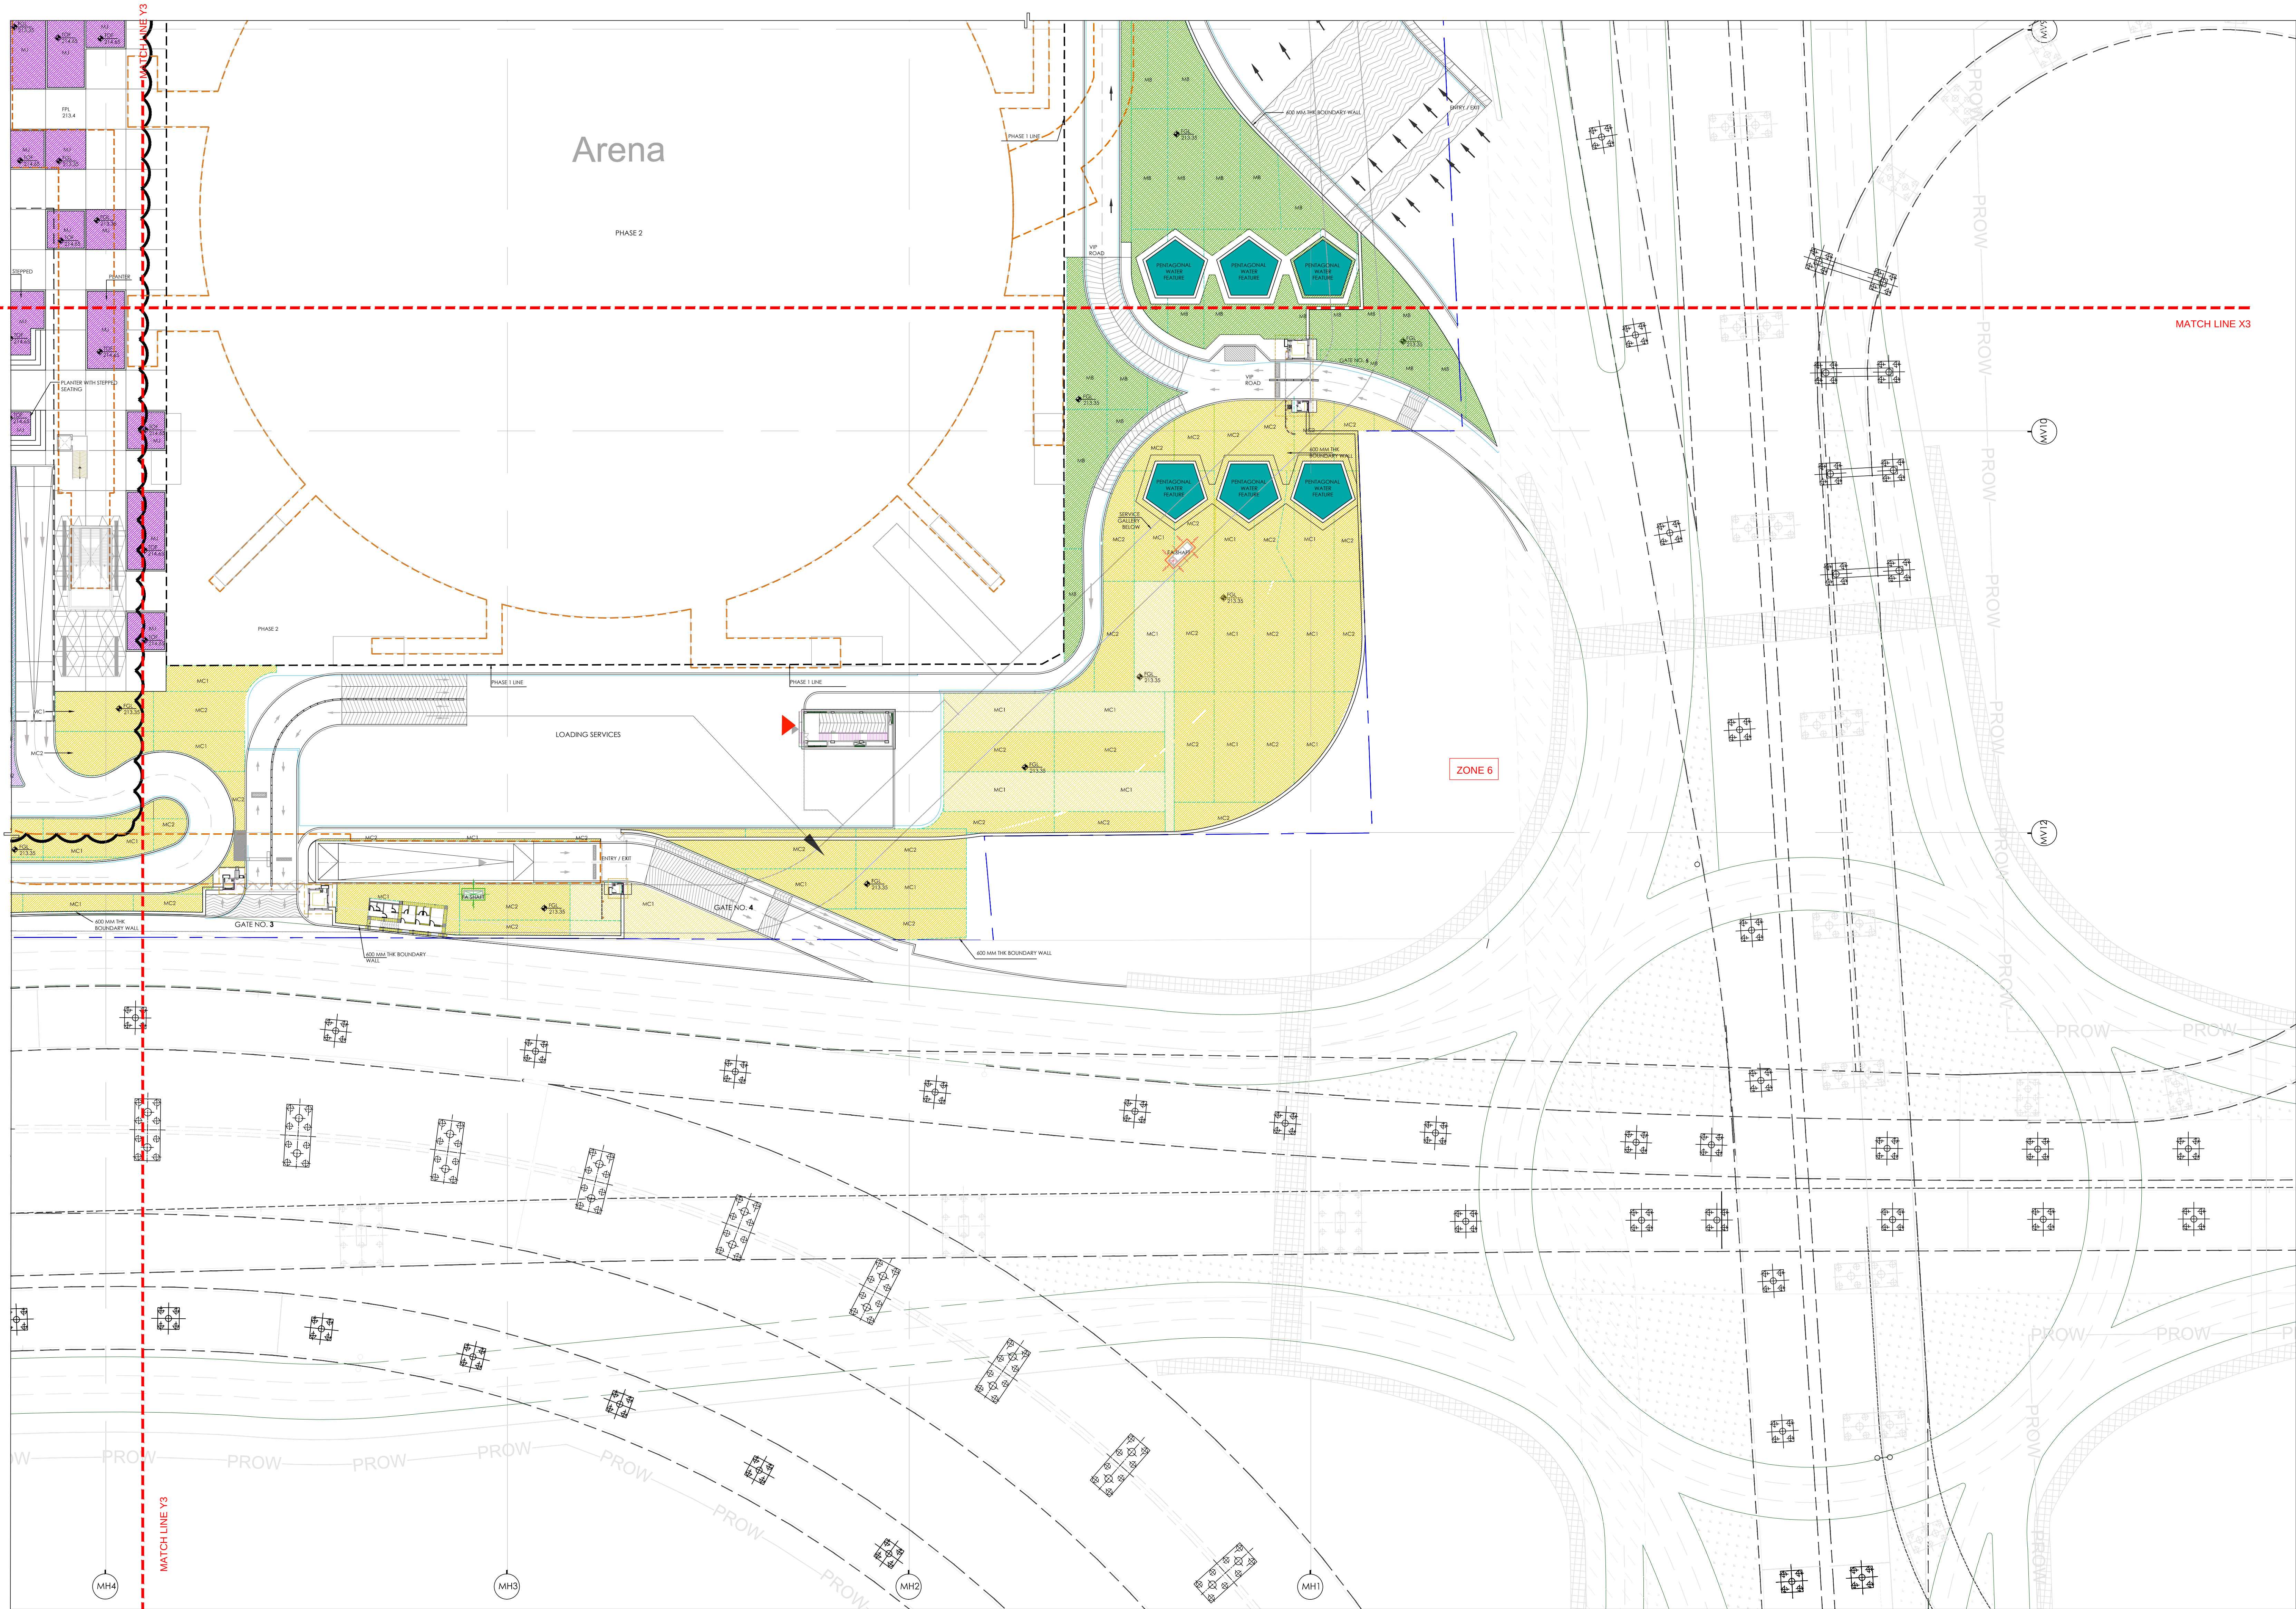

PLANTING MODULE FOR SHRUBS AND GROUND COVERS
(Refer O17203-N-SP-00-WD-0817 sheet for details)

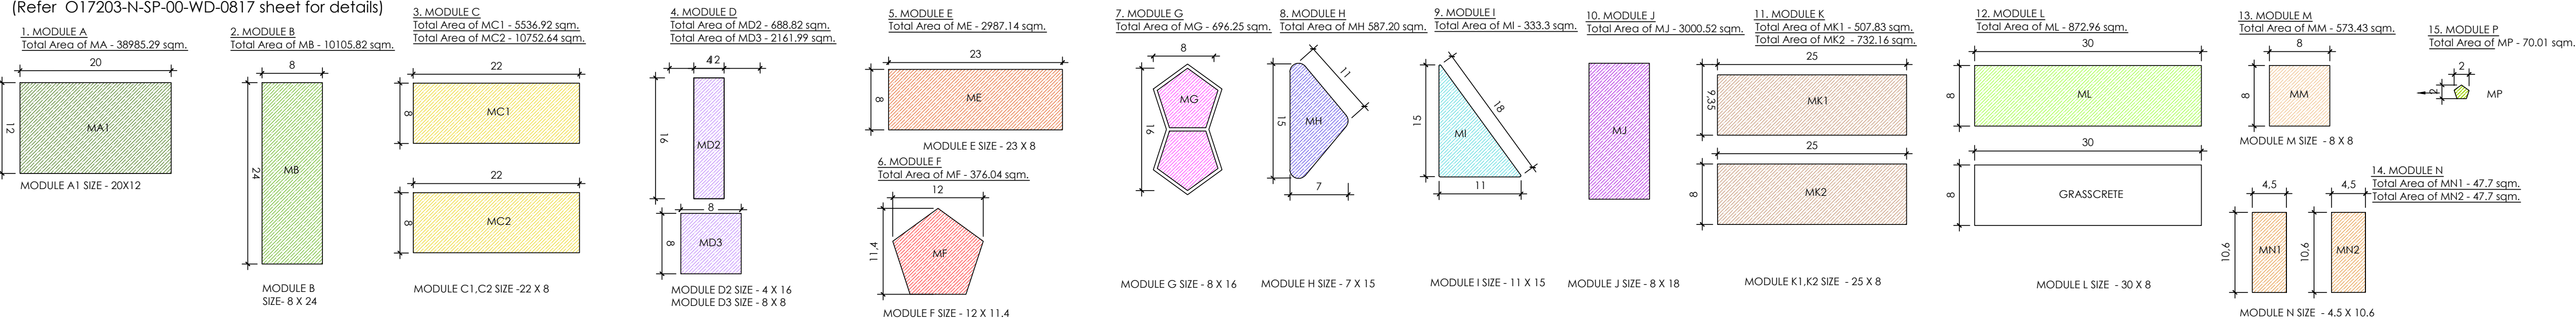


- O17203-N-SP-00-WD-(0800-0816) - PLANTING SET - TO BE REFERRED FOR FOLLOWING POINTS :**
- All dimensions are in Meter. Dimensions to be read and shall not be measured from the drawing.
 - View locations are provided only for reference.
 - For specifications of the shrubs & ground covers refer separate document.
 - Green areas and Planting of lower canopy are shown in colored hatches. To get clear understanding prints should be taken in colour.
 - Metric contour line depiction in orange colour.
 - Lower canopy layouts do not show details for the modules. Refer drawing no. O17203-N-SP-00-WD-0817 for the same.
 - Service gallery and tunnel coming in green areas and landscape plaza to be designed for the tree loading.

- ABBREVIATIONS :**
- FRL - FINISHED ROAD LEVEL
 - FPL - FINISHED PAVED LEVEL
 - FGL - FINISHED GRAVEL LEVEL
 - BPL - BUILDING PAVED LEVEL
 - TOP - TOP OF FILL

LEGEND :

- METRO LINE
- PHASE 1 LINE
- PHASE 2 ZONE

NORTH :

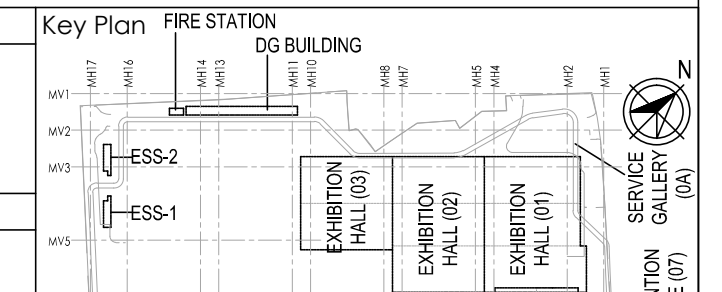

Zone 16

LANDSCAPE PLANTING PLAN - LOWER CANOPY: ZONE 16

EDRC DWG No : O17203-N-SP-00-WD-0816
Scale : 1:500
Sheet Size : A0

Owner / Employer
India International Convention & Exhibition Centre Limited
Room No. 814, Ministry of Commerce & Industry,
DPP, 10/30/30, New Delhi - 110011, India
Department of Industrial Policy and Promotion Ministry of Commerce & Industry Government of India

Knowledge Partner
Dehi Mumbai Industrial Corridor Development Corporation
Room No. 814 & 3rd Floor, 10/30/30, New Delhi - 110011, India
DPP, 10/30/30, New Delhi - 110011, India

Employer's Representative
Programme Management Consultant (PMC)
AECOM
Preliminary Engineering Architecture Consultants (PEAC)
Idom
CPKUREJA
EPC Contractor
L&T Construction
Buildings & Factories
Mount Poonam Road, Mangalore,
P.B. No. 177, Chennai - 600 089

EPC Contractor's Representatives
Design Consultant
Engineering Design and Research Center (EDRC)
L&T Construction - Buildings & Factories
Architectural Consultant
ARCO P
Arco Associates Pvt. Ltd.
A-15, Poonam Road, Gurgaon,
New Delhi - 110048, India

Structural Proof Consultant
Indian Institute of Technology (IIT) Madras
Sector 25, Anna Nagar, Chennai,
Tamil Nadu 600 008

MEP Proof Consultant
Egis India Consulting Engineers Pvt. Ltd.
Plot No. 46, Sector 13, Industrial Area,
Gurgaon, Haryana 122001

ICT Proof Consultant
CKR Consulting Engineers Pvt. Ltd.
4/71, 3rd Floor, Naraina Arcade,
Subodh Chandra Road, New Delhi - 110028, India

Certification
EPC Contractor
Design Consultant
Architectural Consultant
Proof Consultant
Structural
MEP
ICT
FEAC
Issued by:
Employer / Employer's Engineer

REV	DESCRIPTION	DATE	DESIGN	DRWN	CHKD	APPRD
01	GOOD FOR CONSTRUCTION	11/01/18	NL	16	NL	16

REV	DESCRIPTION	DATE	DESIGN	DRWN	CHKD	APPRD
01	GOOD FOR CONSTRUCTION	11/01/18	NL	16	NL	16


REV	DESCRIPTION	DATE	DESIGN	DRWN	CHKD	APPRD
01	GOOD FOR CONSTRUCTION	11/01/18	NL	16	NL	16

REV	DESCRIPTION	DATE	DESIGN	DRWN	CHKD	APPRD
01	GOOD FOR CONSTRUCTION	11/01/18	NL	16	NL	16

REV	DESCRIPTION	DATE	DESIGN	DRWN	CHKD	APPRD
01	GOOD FOR CONSTRUCTION	11/01/18	NL	16	NL	16

REV	DESCRIPTION	DATE	DESIGN	DRWN	CHKD	APPRD
01	GOOD FOR CONSTRUCTION	11/01/18	NL	16	NL	16

REV	DESCRIPTION	DATE	DESIGN	DRWN	CHKD	APPRD
01	GOOD FOR CONSTRUCTION	11/01/18	NL	16	NL	16

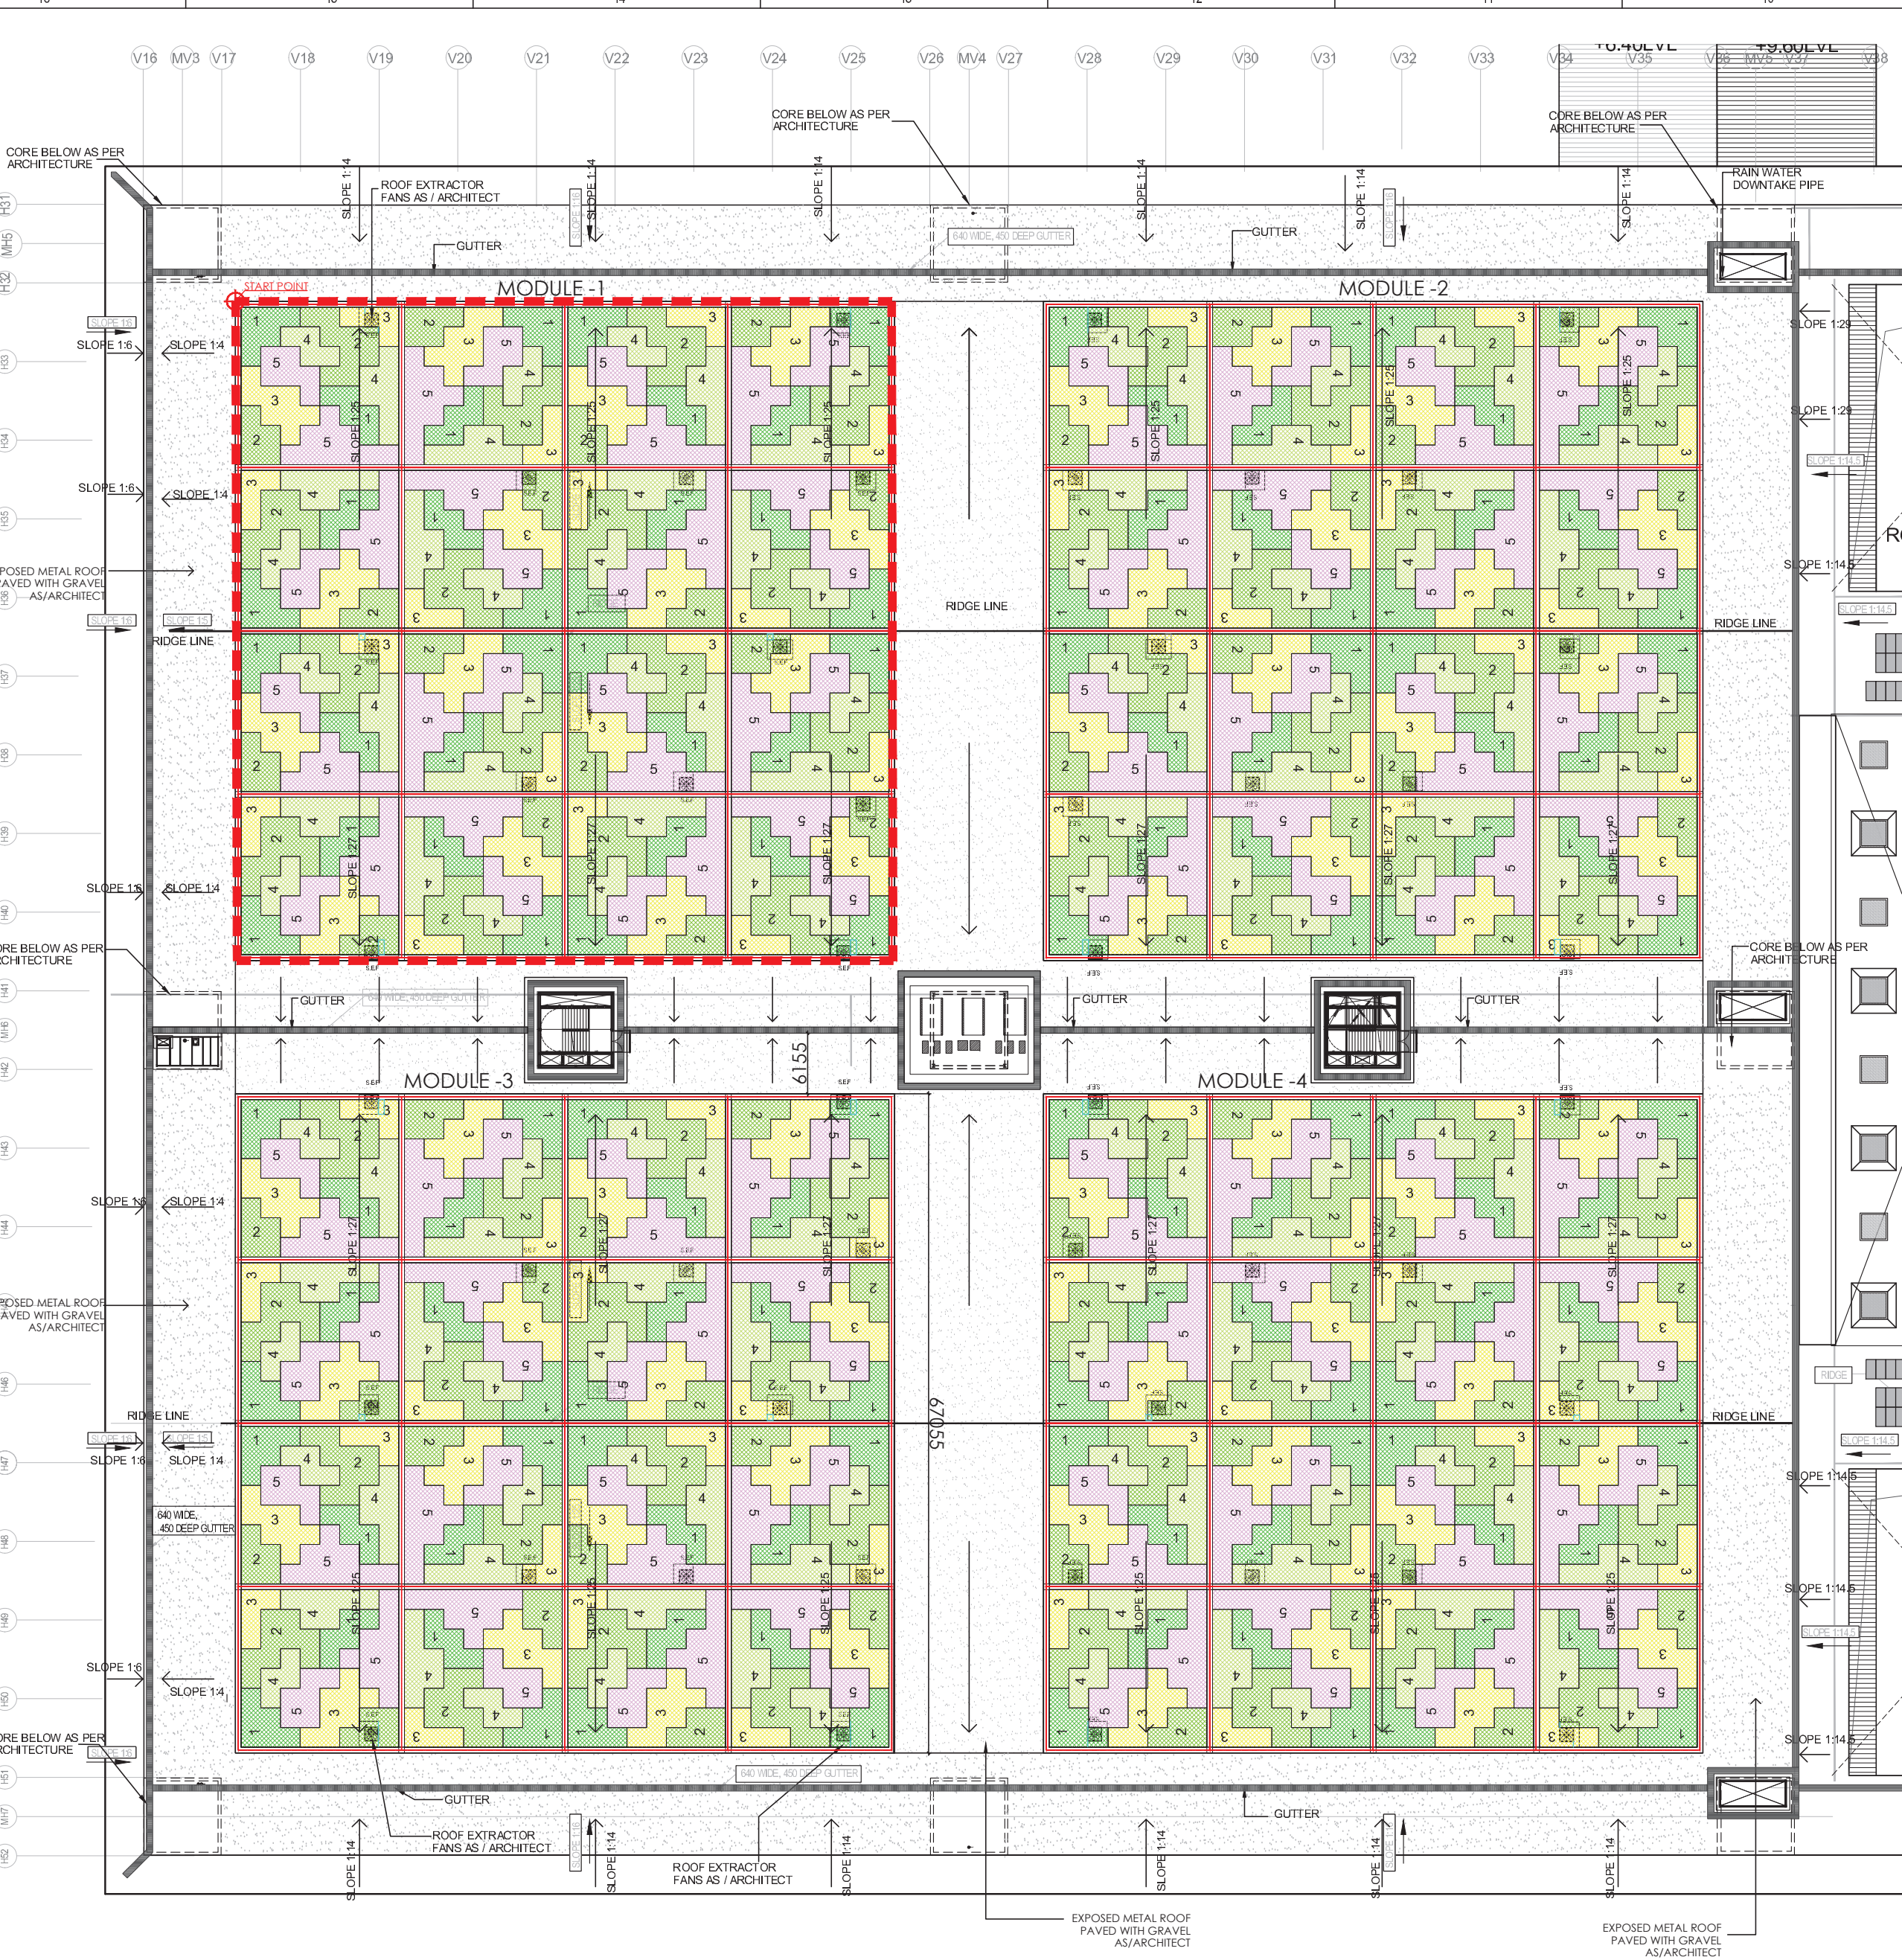

1 LANDSCAPE ROOF PLAN - DETAIL B | EH 2
Scale - 1:400

LEGEND FOR MODULE 1 :			LEGEND FOR MODULE 2 :			LEGEND FOR MODULE 3 :			LEGEND FOR MODULE 4 :		
TYPE	SPECIES	IMAGES	TYPE	SPECIES	IMAGES	TYPE	SPECIES	IMAGES	TYPE	SPECIES	IMAGES
1	Verbena bonariensis perennials		1	Ficus Longland		1	Pennisetum Red		1	Lantana Red	
2	Ficus Longland		2	Pennisetum Red		2	Lantana Red		2	Wadella Trilobata	
3	Pennisetum Red		3	Lantana Red		3	Wadella Trilobata		3	Rheo Discolor	
4	Lantana Red		4	Wadella Trilobata		4	Rheo Discolor		4	Ophiopogon Jaburum Variegated	
5	Wadella Trilobata		5	Rheo Discolor		5	Ophiopogon Jaburum Variegated		5	Pennisetum villosum green	




LEGEND:
--- PHASE LINE FOR COMPLETE LANDSCAPE
--- PHASE LINE FOR ROAD AND SIGNAGE
--- METRO LINE
--- METRO CONNECTION
--- RIDGE LINE


ABBREVIATION:
FRL - FINISHED FLOOR LEVEL
FPL - FORMED ROAD LEVEL
FVL - FORMED PAVEMENT LEVEL
LVL - LEVEL
TOPW - TOP OF PLANTER WALL
TOF - TOP OF FILL

NOTES:
1. ALL DIMENSIONS ARE IN MILLIMETERS, LEVELS IN METERS AND ANGLES IN DEGREES UNLESS OTHERWISE NOTED.
2. THE DRAWING IS TO BE READ AND NOT TO BE SCALED; ONLY WRITTEN DIMENSIONS IN ALL CASES SHALL BE FOLLOWED.
3. THE DRAWING SHALL BE READ IN CONJUNCTION WITH ALL RELEVANT ARCHITECTURAL, STRUCTURAL AND SERVICE DRAWINGS.
4. ALL DIMENSIONS SHALL BE VERIFIED ON SITE PRIOR TO START OF WORK AND ANY DISCREPANCY SHALL BE BROUGHT TO THE NOTICE OF THE ARCHITECT.
5. KINDLY FOLLOW ARCHITECTURE AND STRUCTURE ROOF BUILT UP SEPARATE DRAWINGS

NOTE :-
1. THE 200MM SOIL FILL IS COMPOSED OF SOILRITE, WASHED SAND AND ORGANIC MANURE.
2. REFER DRAWING NUMBER- O17203-A-SP-01-WD-0009 FOR EH1 ARCHITECTURAL ROOF PLAN
3. REFER DRAWING NUMBER- O17203-A-SP-02-WD-1702 FOR EH1 ROOF GARDEN TYPICAL DETAIL
4. LANDSCAPE DRAWINGS TO BE READ IN CONJUNCTION WITH ARCHITECTURAL DRAWINGS
5. REFER DRAWING NUMBER- O17203-A-SP-01-WD-0009 FOR EH1 METAL ROOF PAVING DETAIL
6. REFER ELECTRICAL DRG NO : O17203-E-SP-01-LL-0021,0022, & 0024 FOR TERRACE SERVICES LIGHTING LAYOUT.

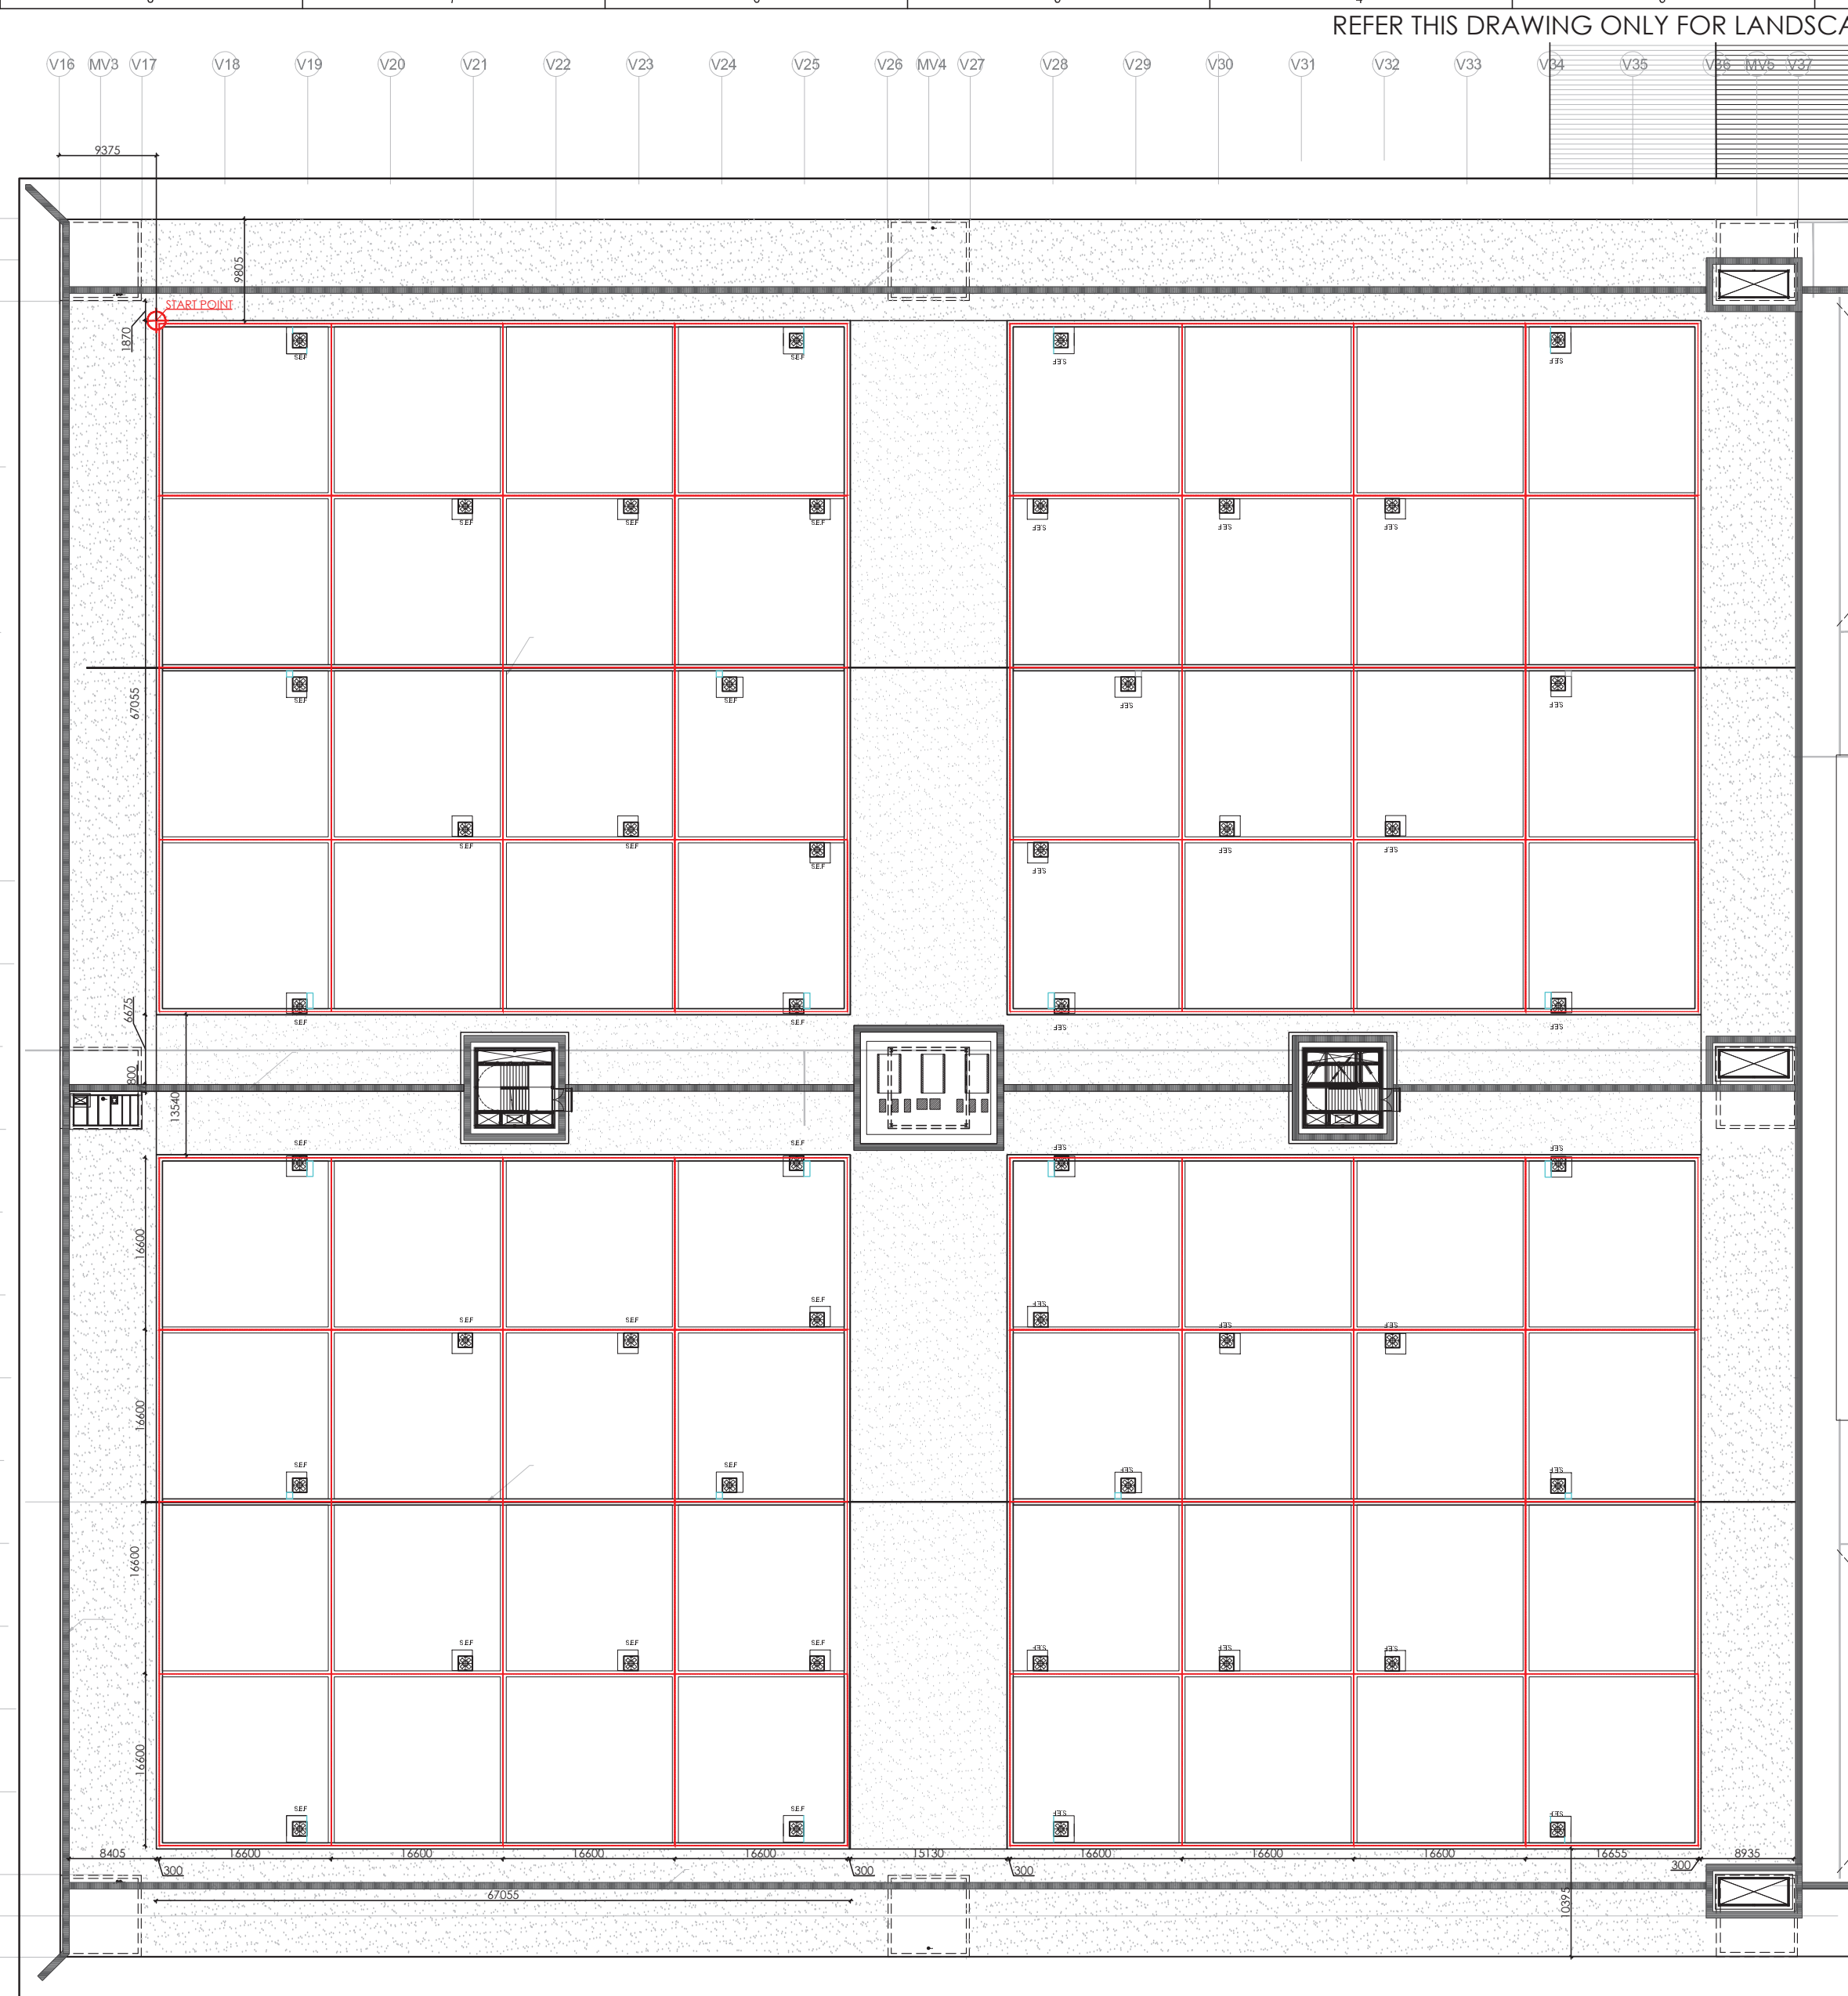


2 SETTING OUT OF MODULES | EH 2
Scale - 1:400

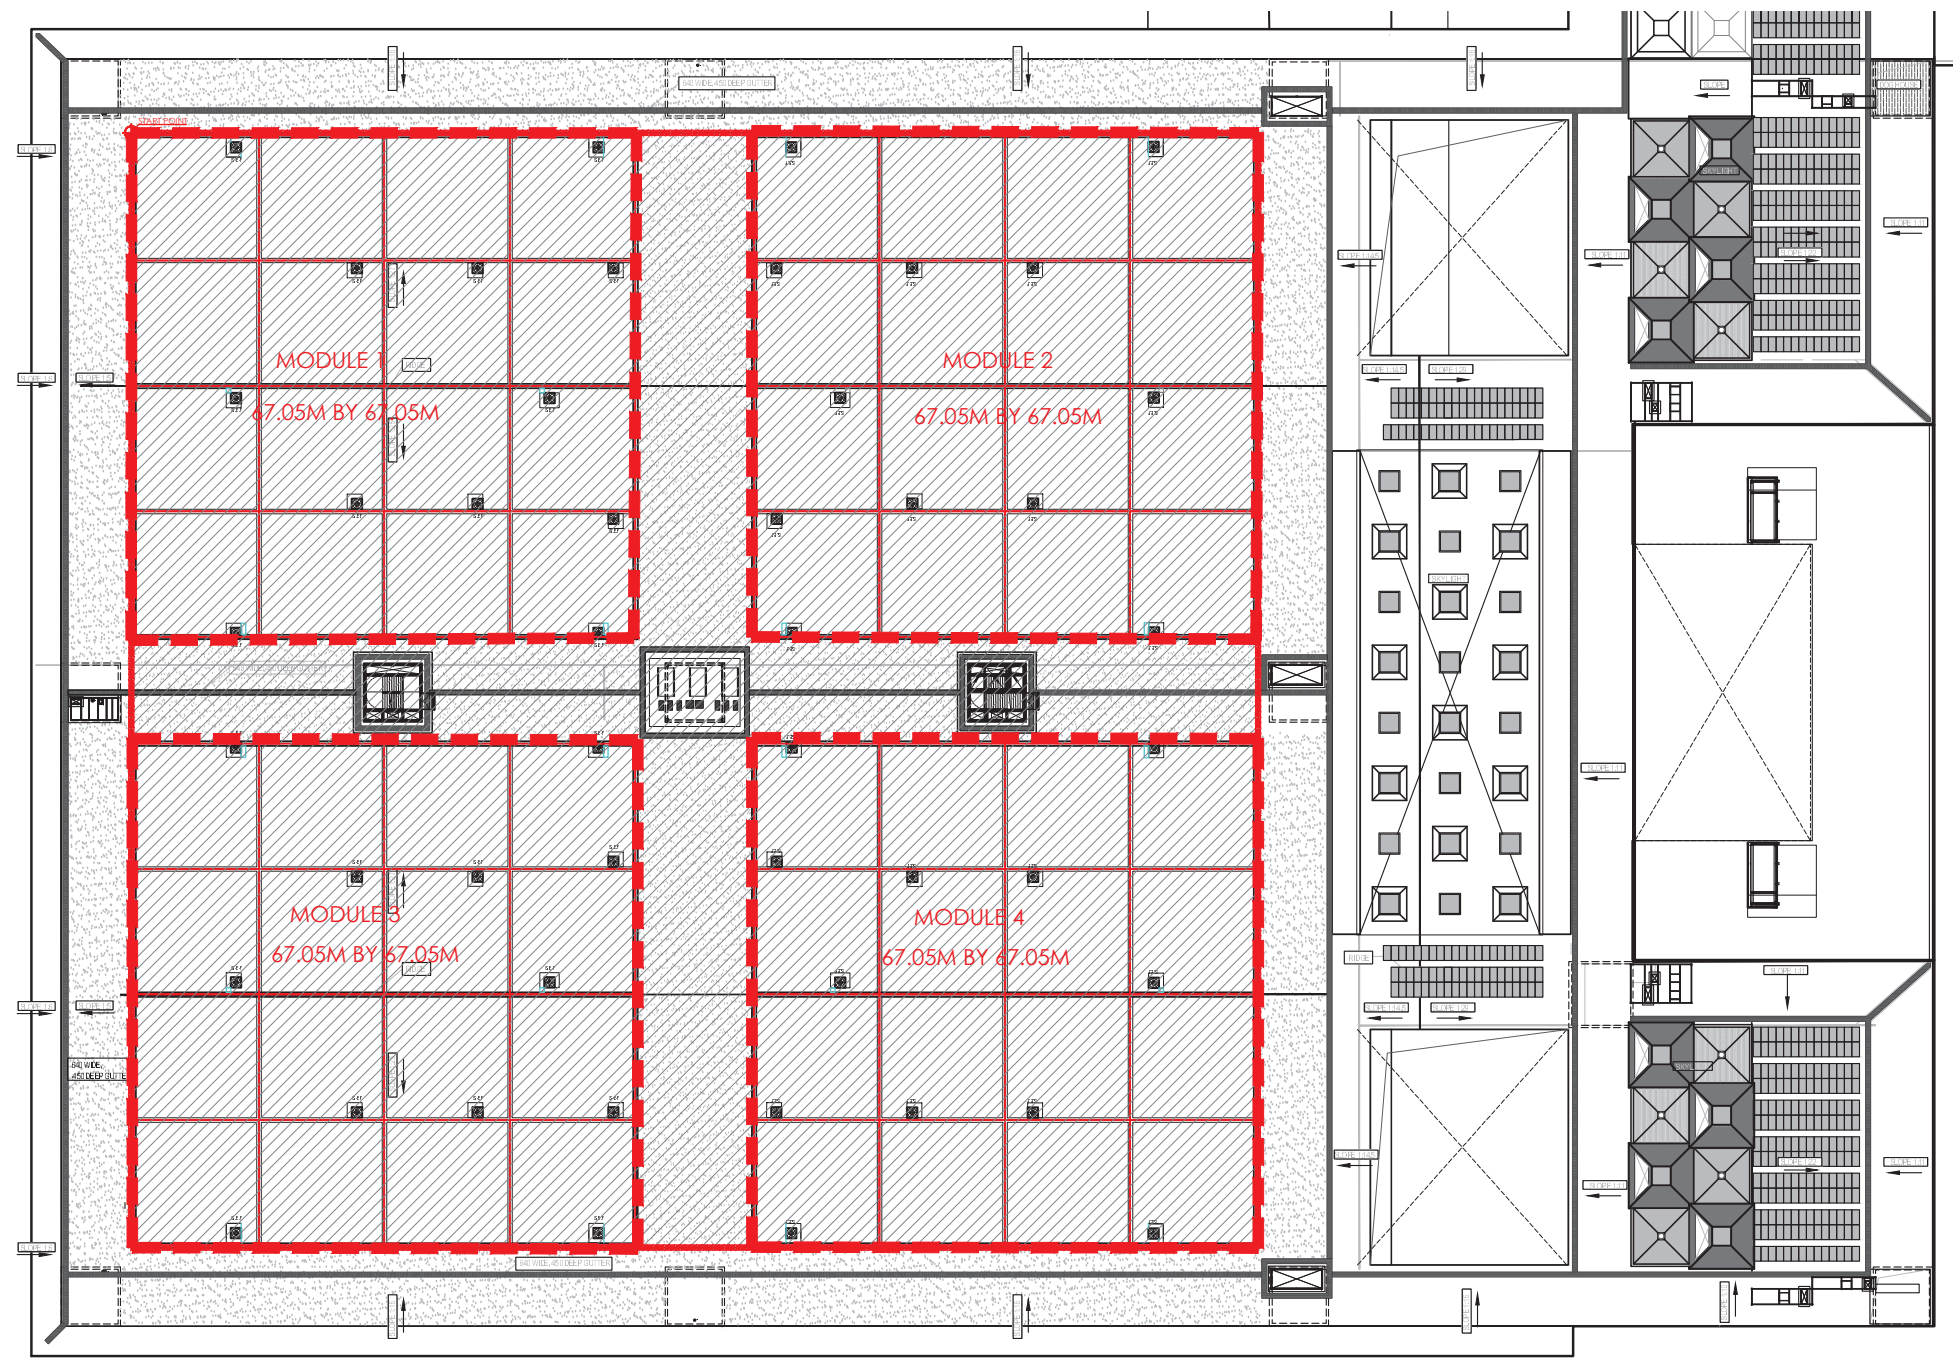

3 KEY PLAN | EH 2
Scale - 1:700

DRIP IRRIGATION SYSTEM TO BE USED (IRRIGATION LAYOUT TO BE PROVIDED BY VENDOR)

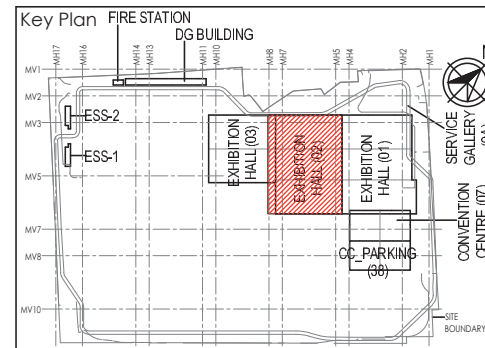

India International Convention & Exhibition Centre Limited
Room No. 302, Ministry of Commerce & Industry,
DPP, Using Bhawan, New Delhi-110011, India

Department of Industrial Policy and
Promotion Ministry of Commerce & Industry
Government of India

Knowledge Partner
Dell Mumbai Industrial Corridor
Development Corporation
Room No. 302, 3rd Floor, A-Block,
Diplomatic Enclave, 308 Convent Road,
New Delhi-110021, India

Employer Engineer
Programme Management Consultant (PMC)
AECOM

Preliminary Engineering Architecture Consultants (PEAC)
idom **CPKUREJA**
Av. De Montevideo de B Escalad. 4, N. 201, Anshad Building, Convent Road,
28049 Madrid, Spain New Delhi, Delhi 110016, India

EPC Contractor
L&T Construction
Buildings & Factories
Mount Road, Chennai - 600 089

Design Consultant
Engineering Design and Research Center (EDRC)
L&T Construction - Buildings & Factories
Architectural Consultant
ARCOP Arcop Associates Pvt. Ltd.
A-15, Panchsheel Park, G-1, New Delhi, Delhi 110016, India

Structural Proof Consultant
Indian Institute of Technology (IIT) Madras
Sanjay Road, Opposite to C. I. B. A. Road, Chennai,
Tamil Nadu 600035

MEP Proof Consultant
egis Egis India Consulting Engineers Pvt. Ltd.
Plot No. 44, Sector 13, Industrial Area,
Opp. Janta Solutions, Gurgaon,
Haryana 122001

ICT Proof Consultant
CCR CCR Consulting Engineers Pvt. Ltd.
4471, 3rd Floor, Narayana Arcade,
Subramanyam Road, Madhavapuri Circle,
Kozhikode, Kerala - 560004

EPC Contractor
L&T Construction
Buildings & Factories

Design Consultant
ARCOP Arcop Associates Pvt. Ltd.

Architectural Consultant
ARCOP Arcop Associates Pvt. Ltd.

Structural Proof Consultant
ARCOP Arcop Associates Pvt. Ltd.

MEP Proof Consultant
ARCOP Arcop Associates Pvt. Ltd.

ICT Proof Consultant
ARCOP Arcop Associates Pvt. Ltd.

Issued by:
Employer / Employer's Engineer

REV	DESCRIPTION	DATE	DESIGN	DRAWN	CHECKED	APPROVED
01	GOOD FOR CONSTRUCTION	2023-01-11	N.J.	S.S.	N.J.	R.K.












REV	DESCRIPTION	DATE	DESIGN	DRAWN	CHECKED	APPROVED
01	GOOD FOR CONSTRUCTION	2023-01-11	N.J.	S.S.	N.J.	R.K.

REV	DESCRIPTION	DATE	DESIGN	DRAWN	CHECKED	APPROVED
01	GOOD FOR CONSTRUCTION	2023-01-11	N.J.	S.S.	N.J.	R.K.

REV	DESCRIPTION	DATE	DESIGN	DRAWN	CHECKED	APPROVED
01	GOOD FOR CONSTRUCTION	2023-01-11	N.J.	S.S.	N.J.	R.K.

REV	DESCRIPTION	DATE	DESIGN	DRAWN	CHECKED	APPROVED
01	GOOD FOR CONSTRUCTION	2023-01-11	N.J.	S.S.	N.J.	R.K.

REV	DESCRIPTION	DATE	DESIGN	DRAWN	CHECKED	APPROVED
01	GOOD FOR CONSTRUCTION	2023-01-11	N.J.	S.S.	N.J.	R.K.

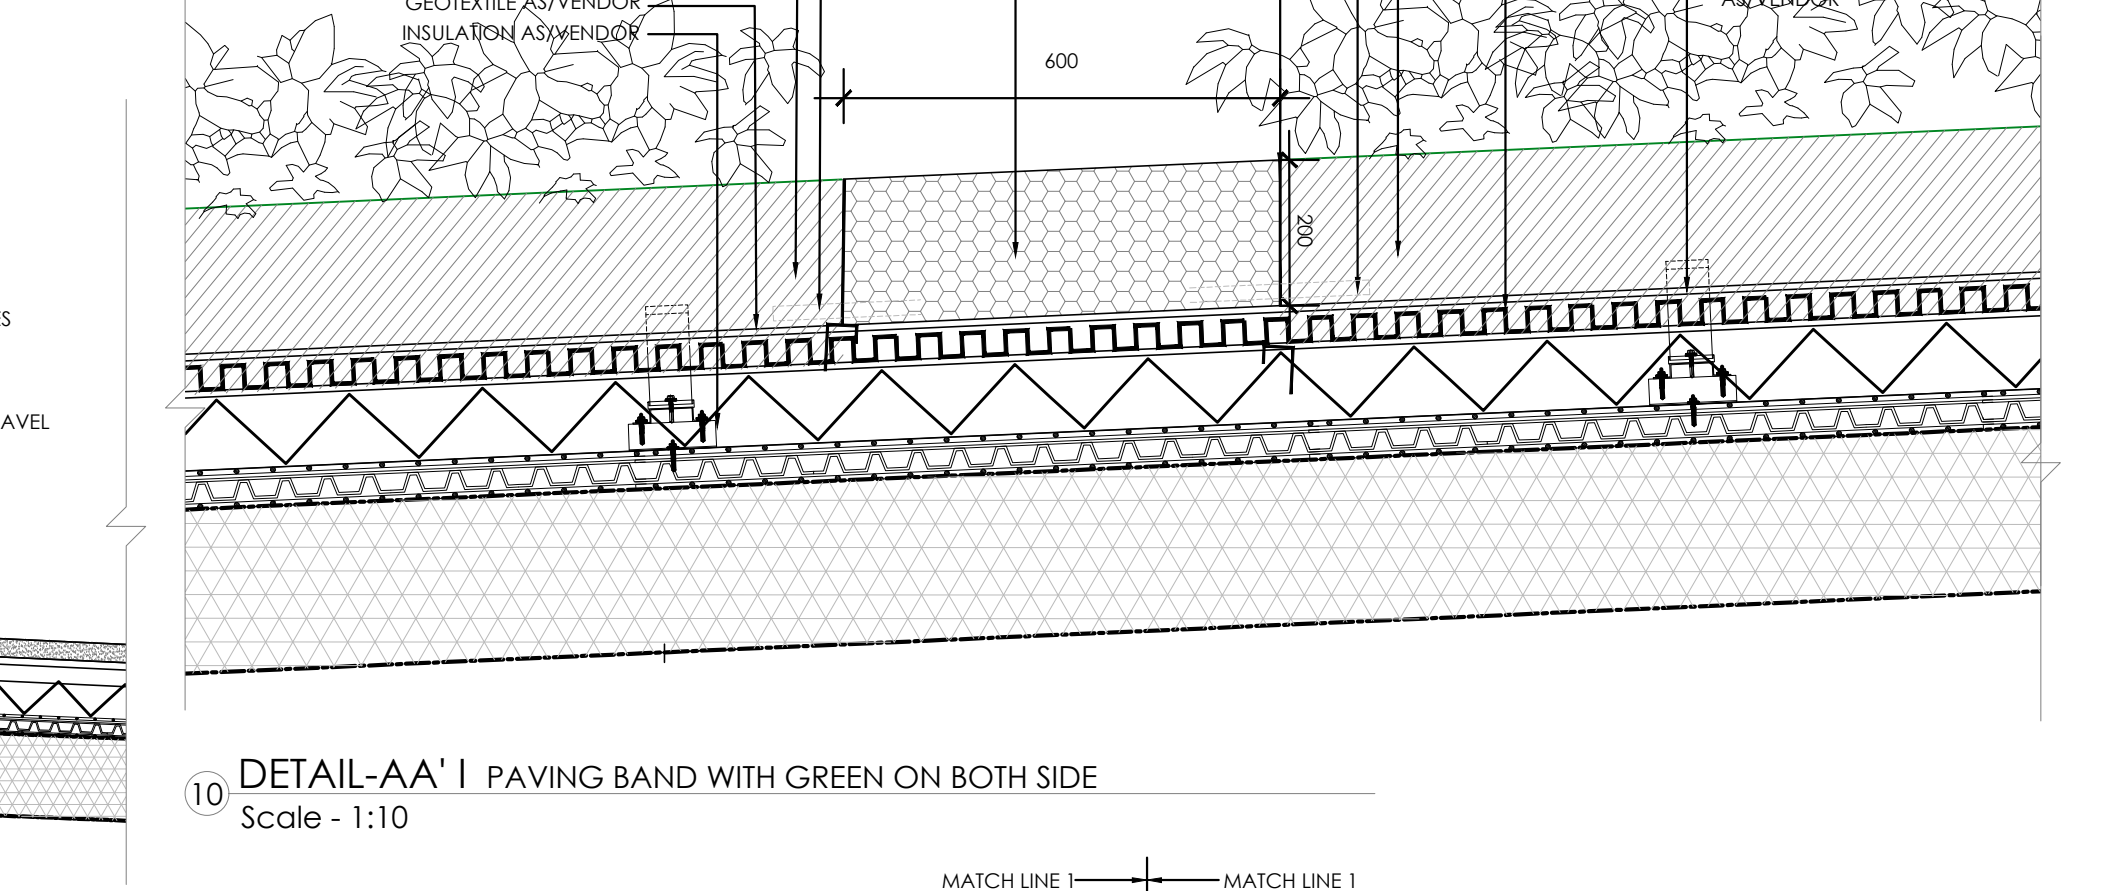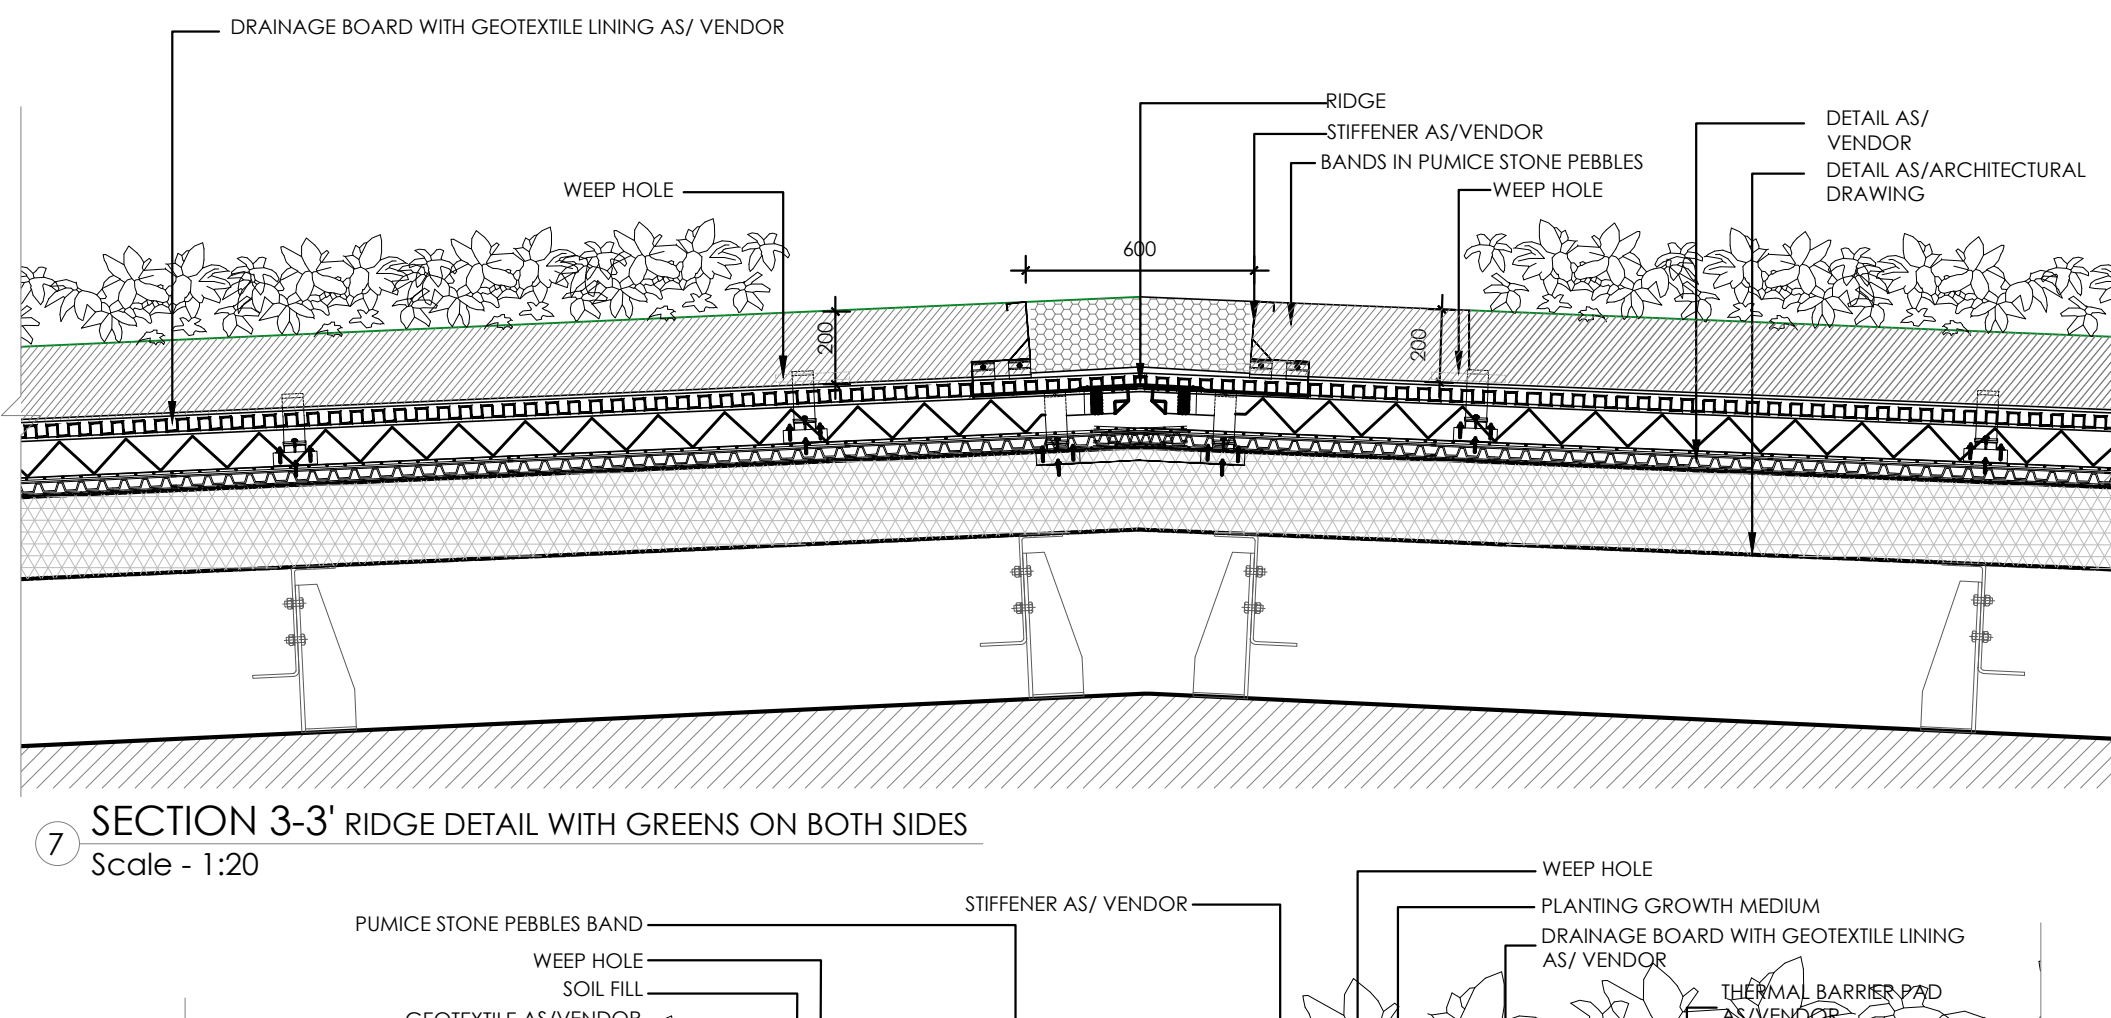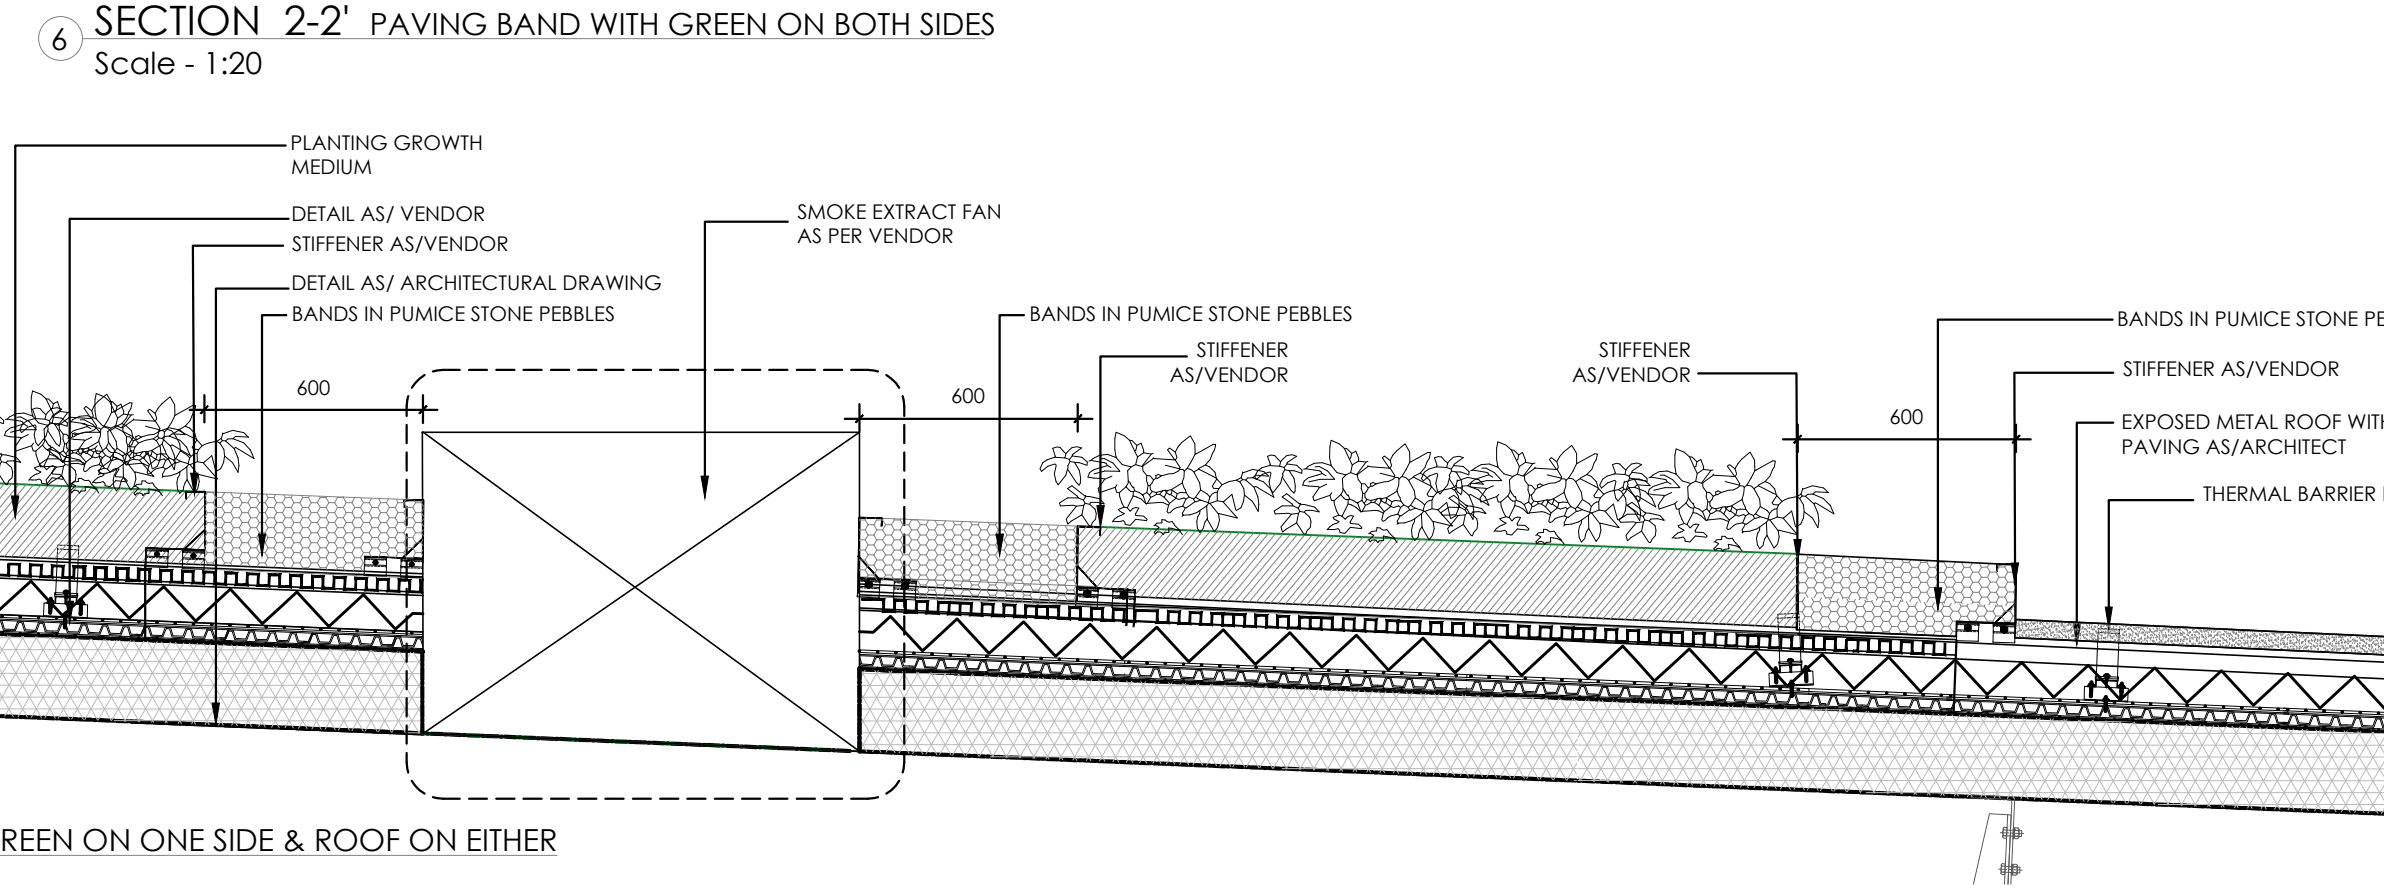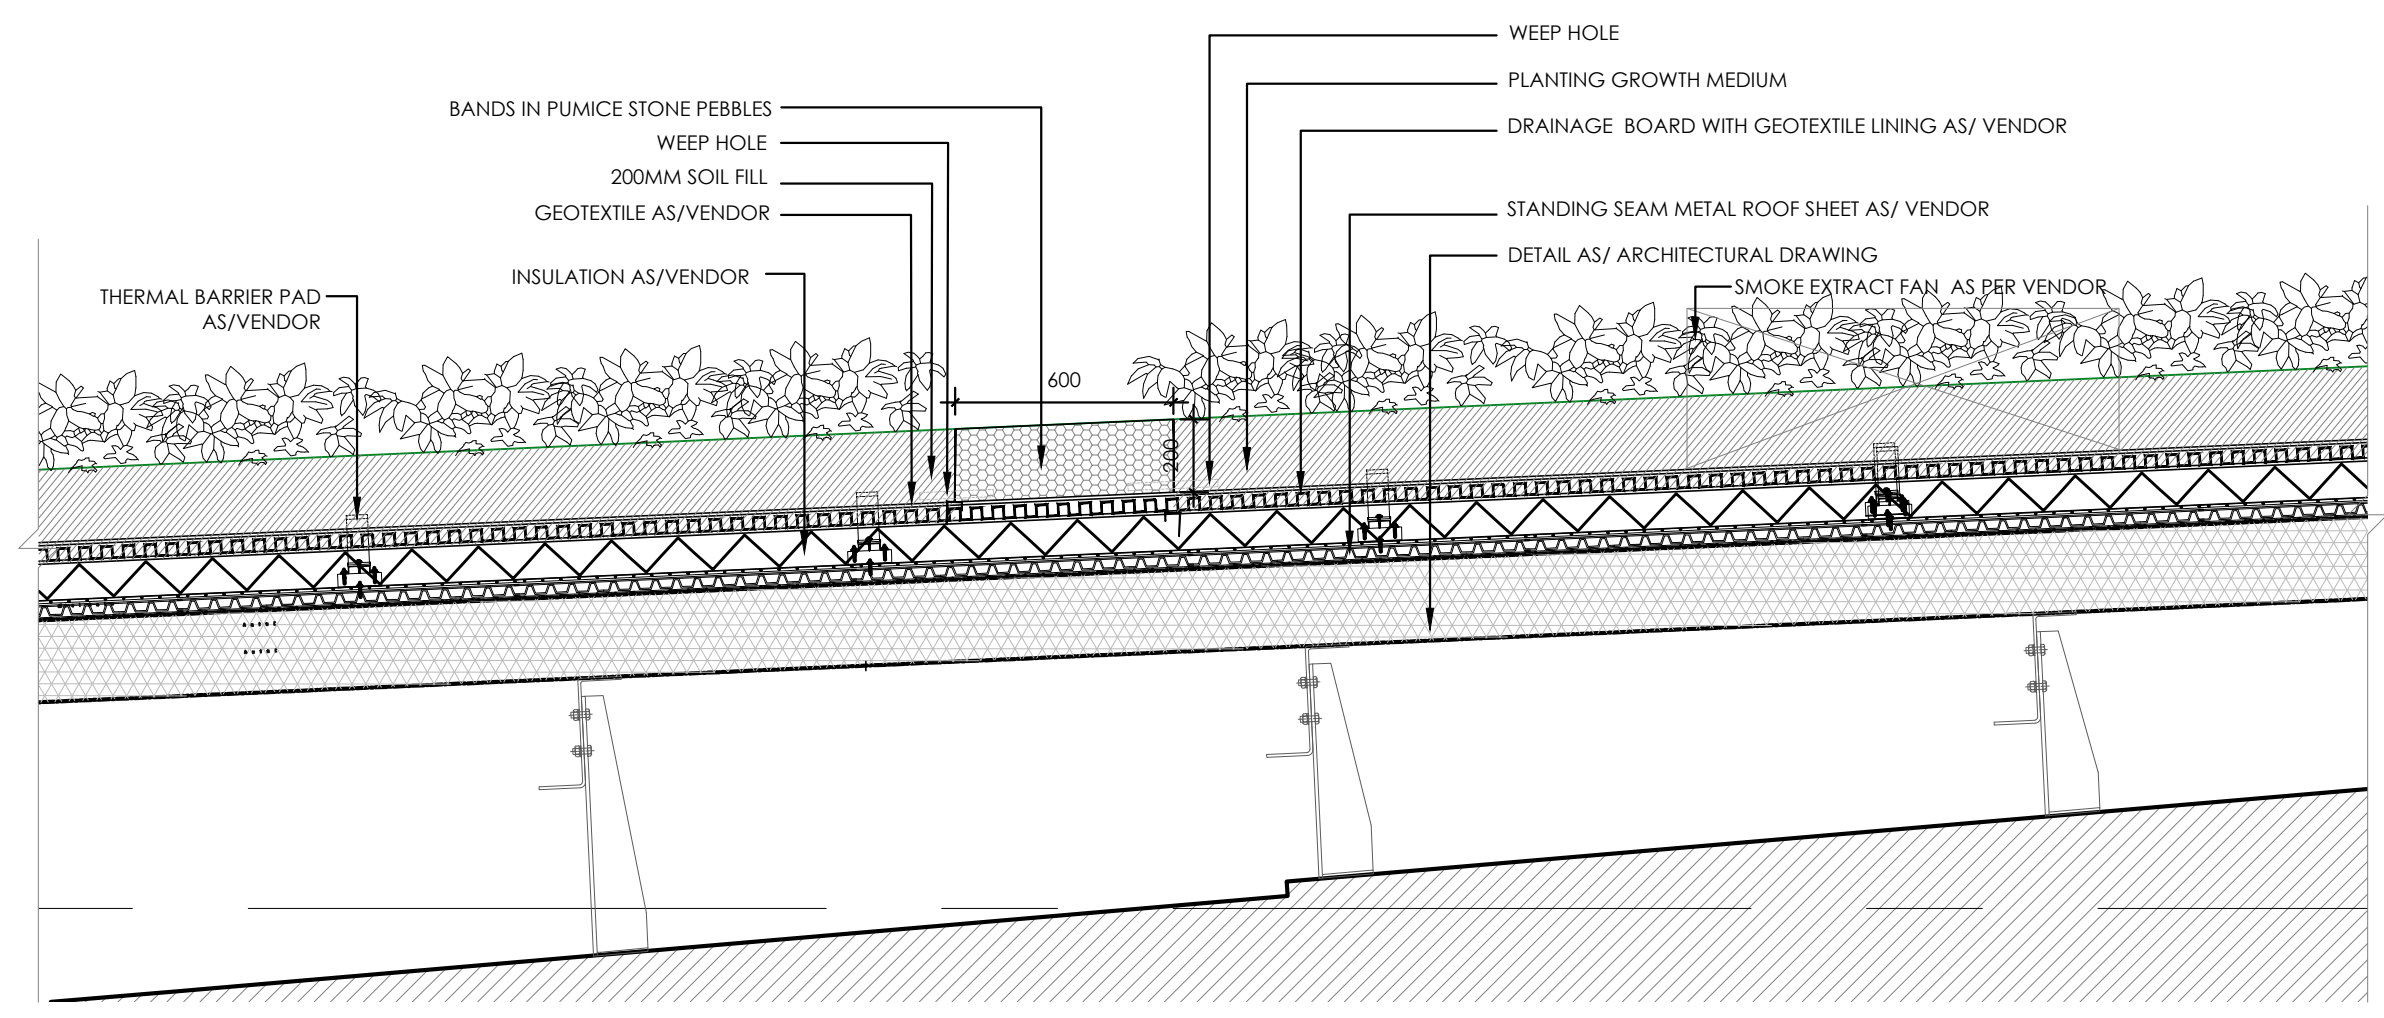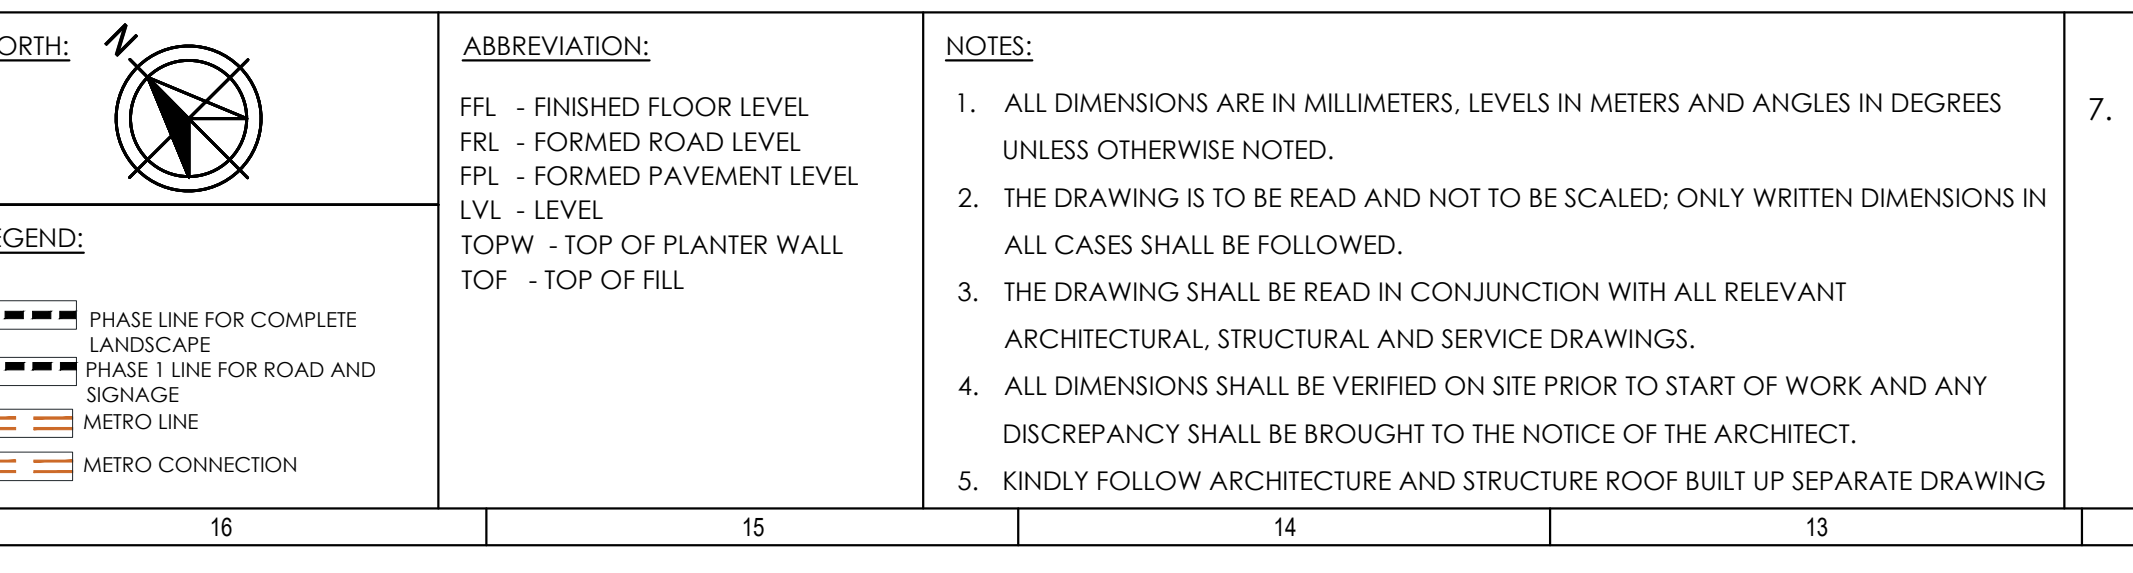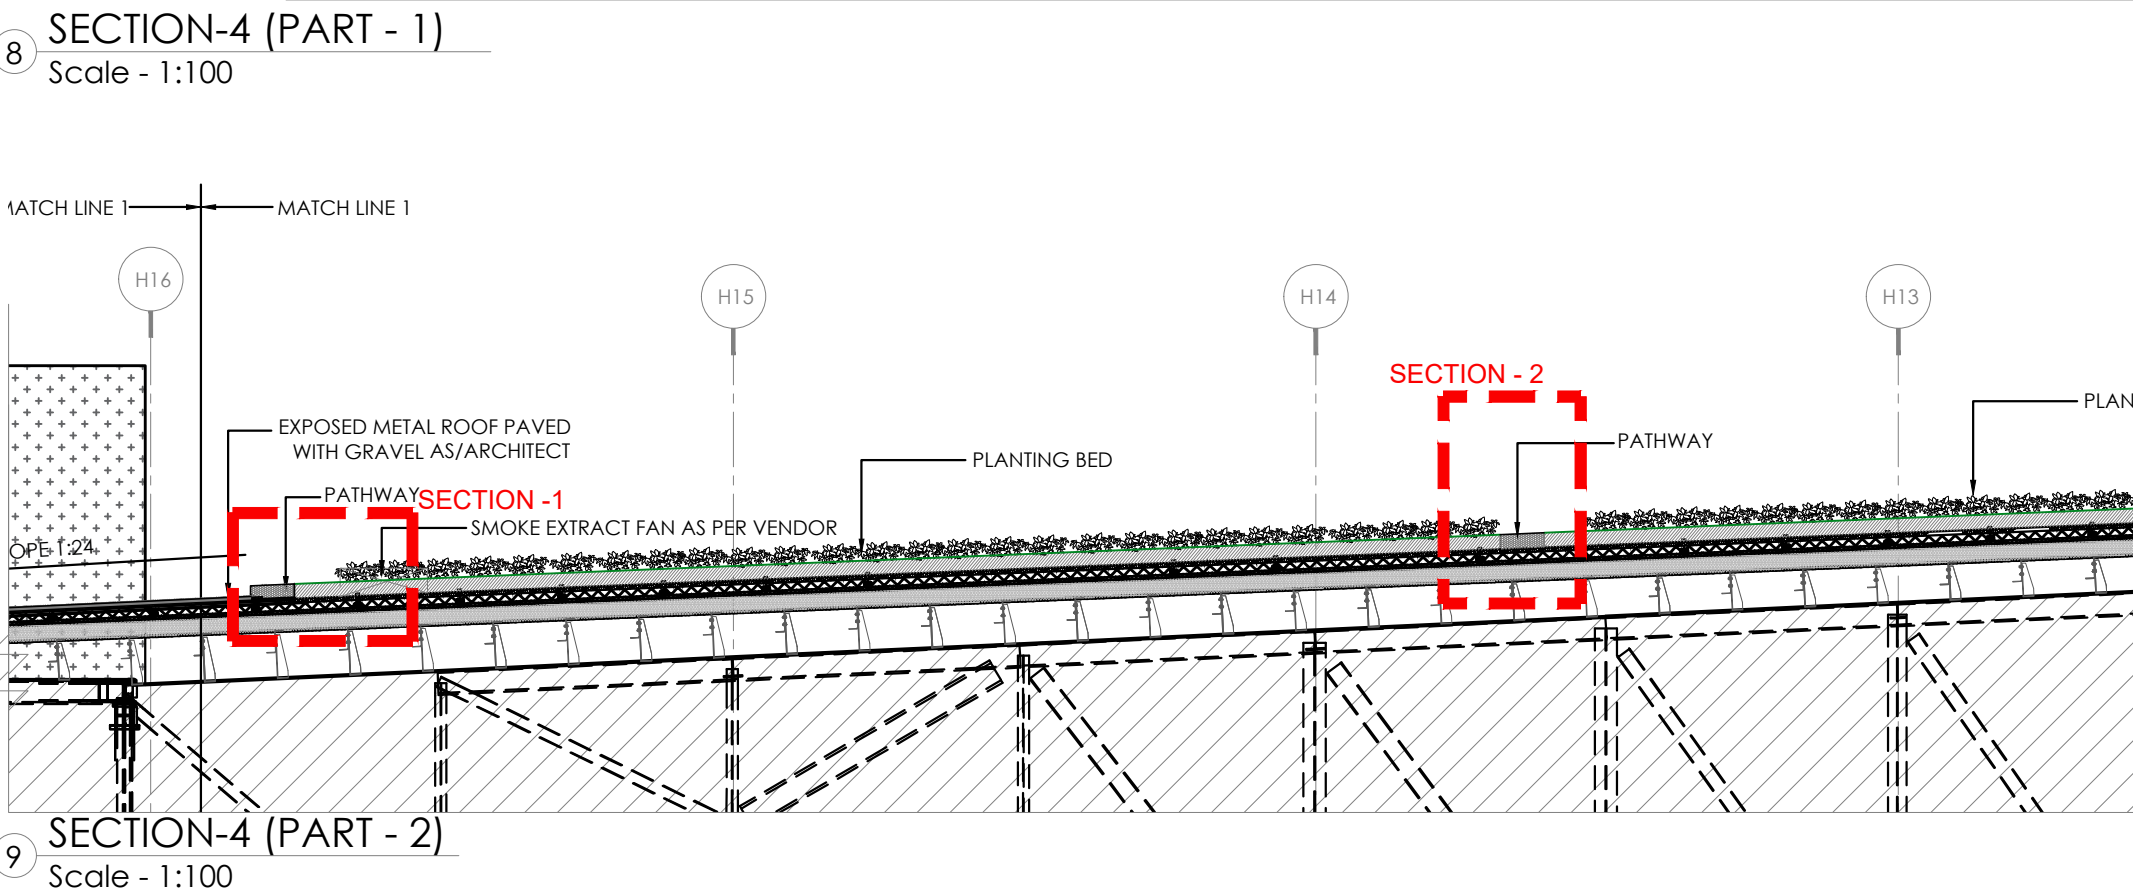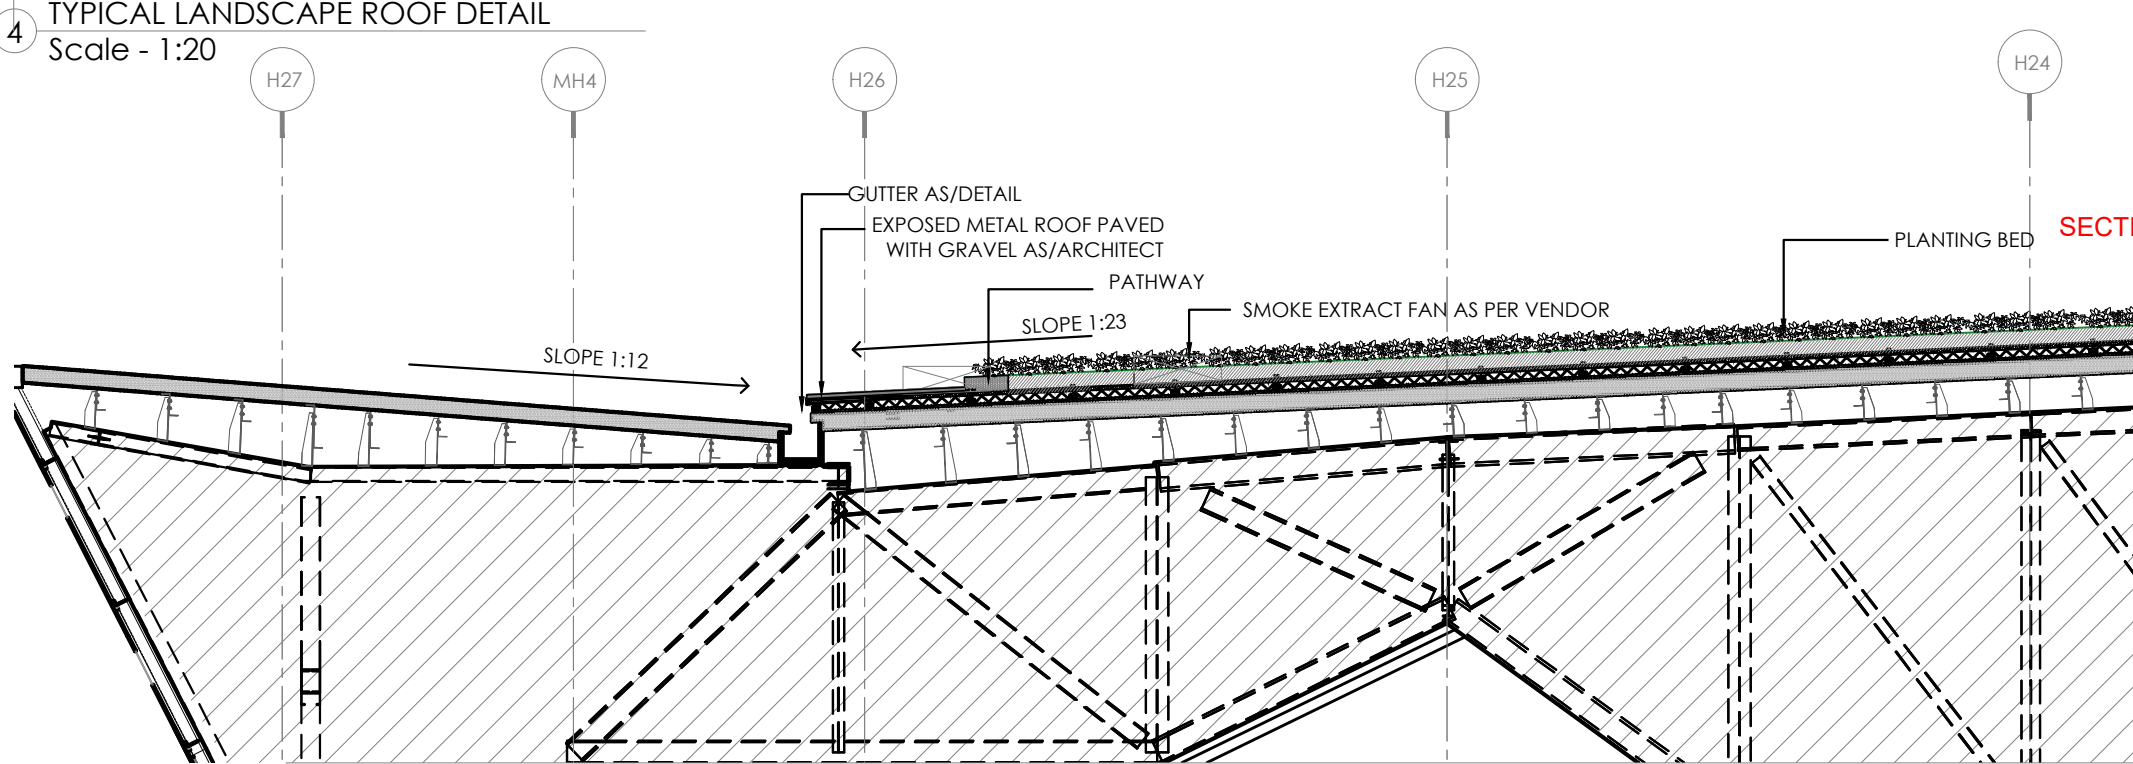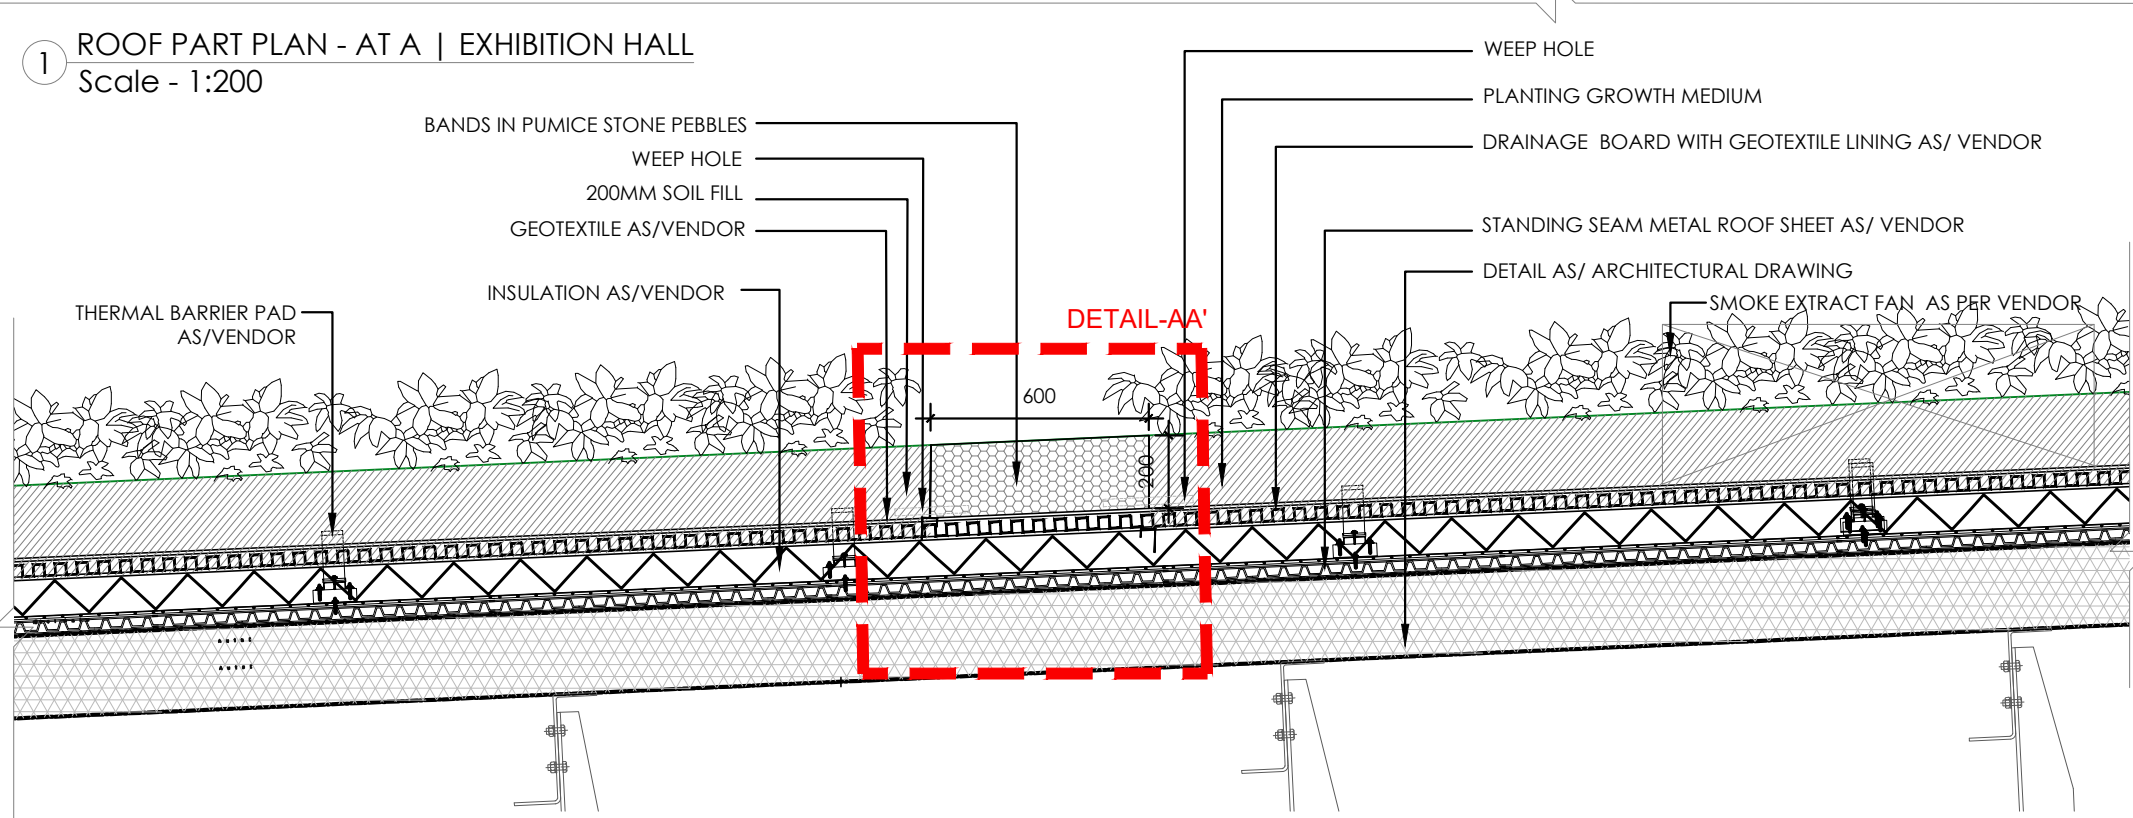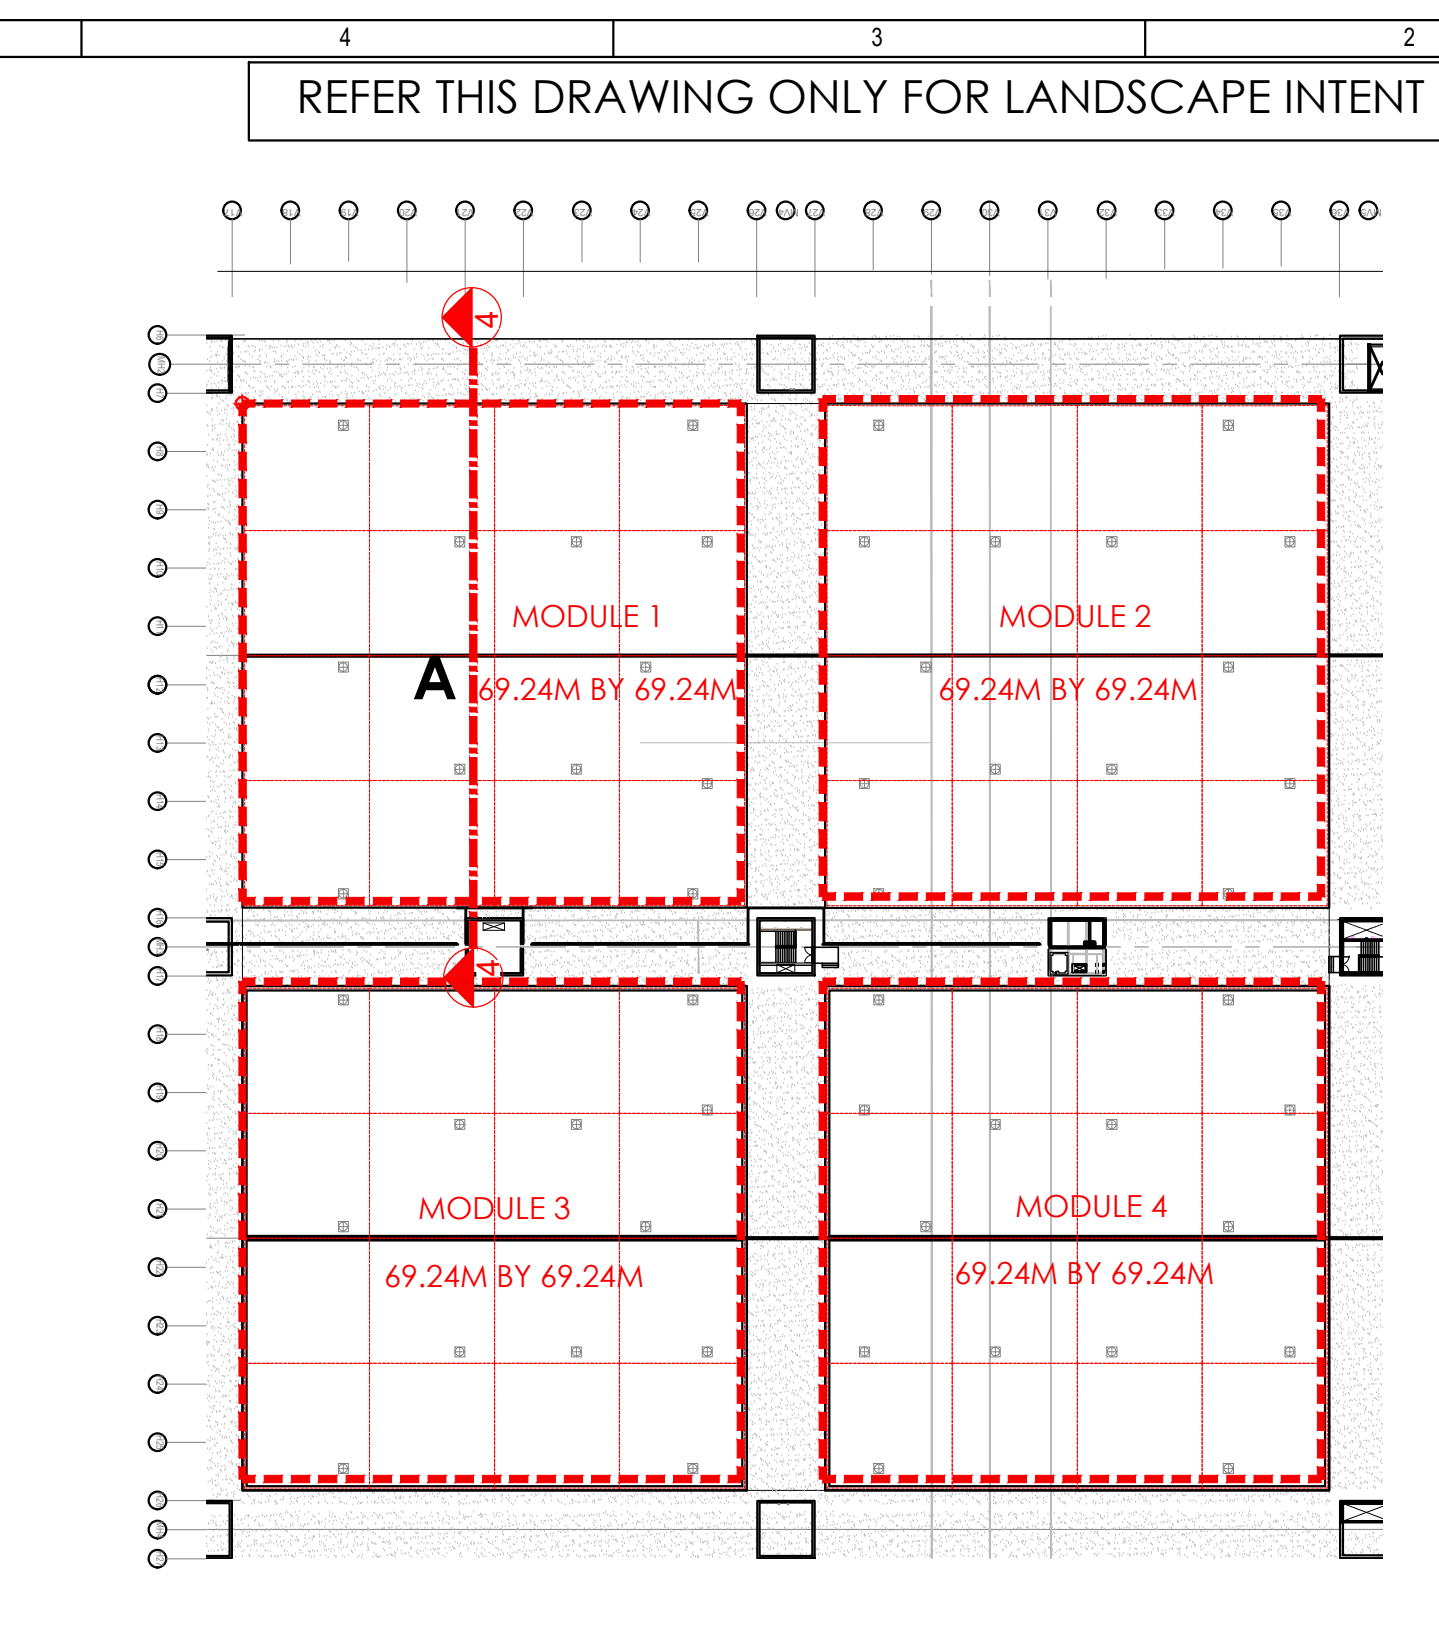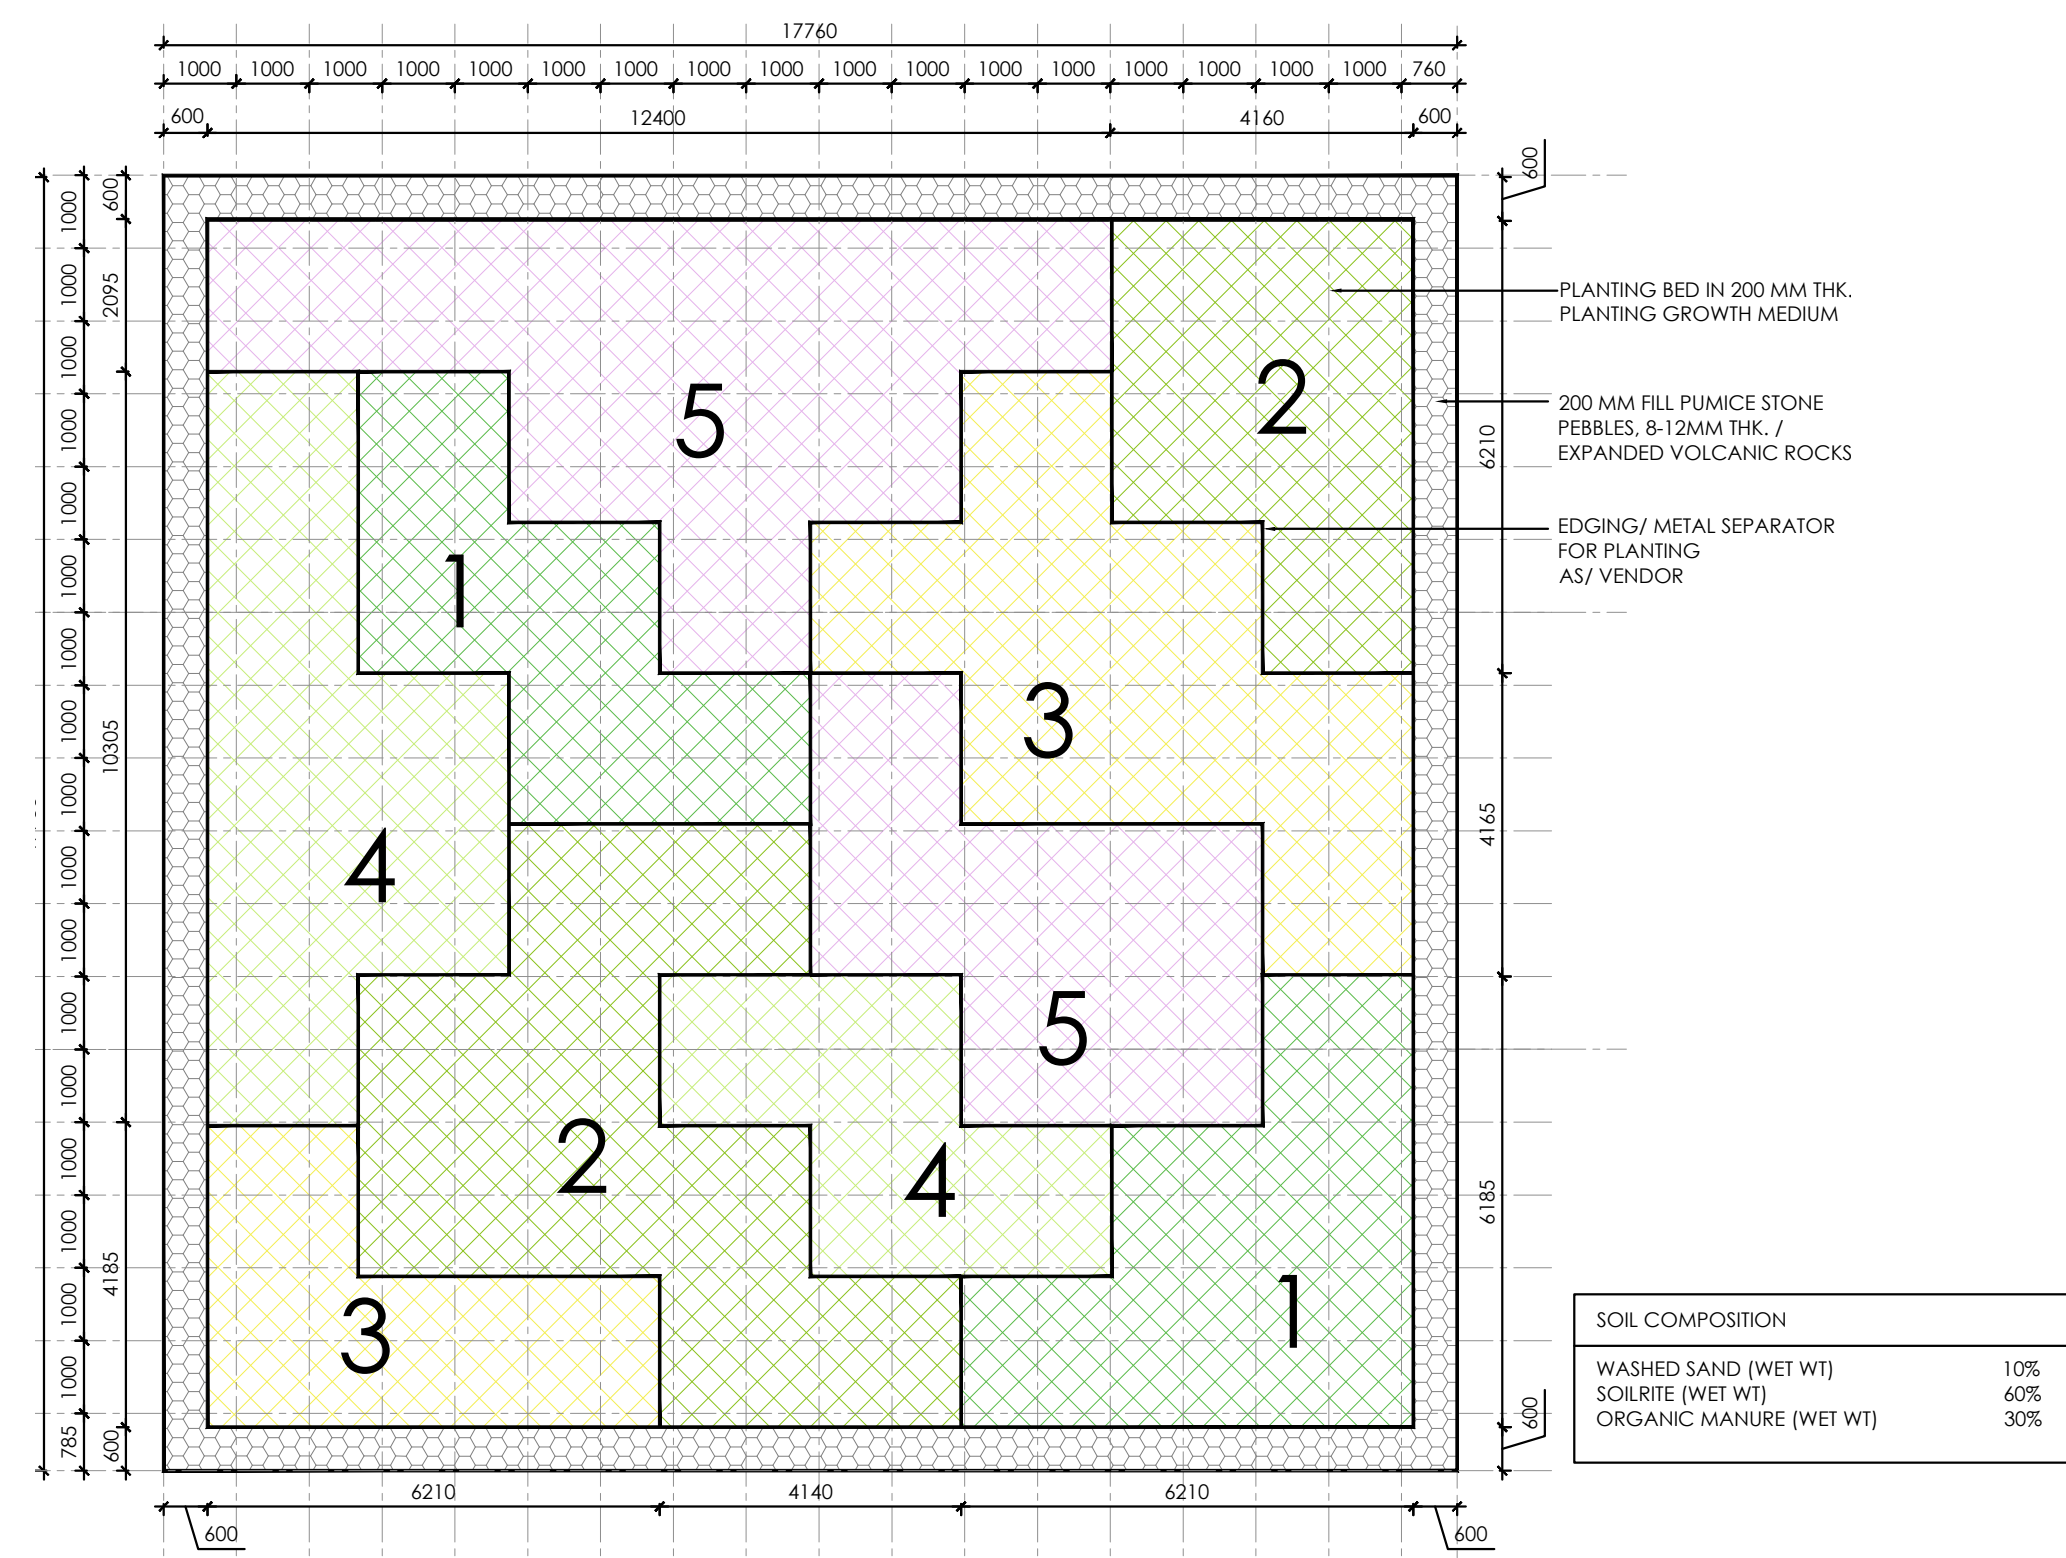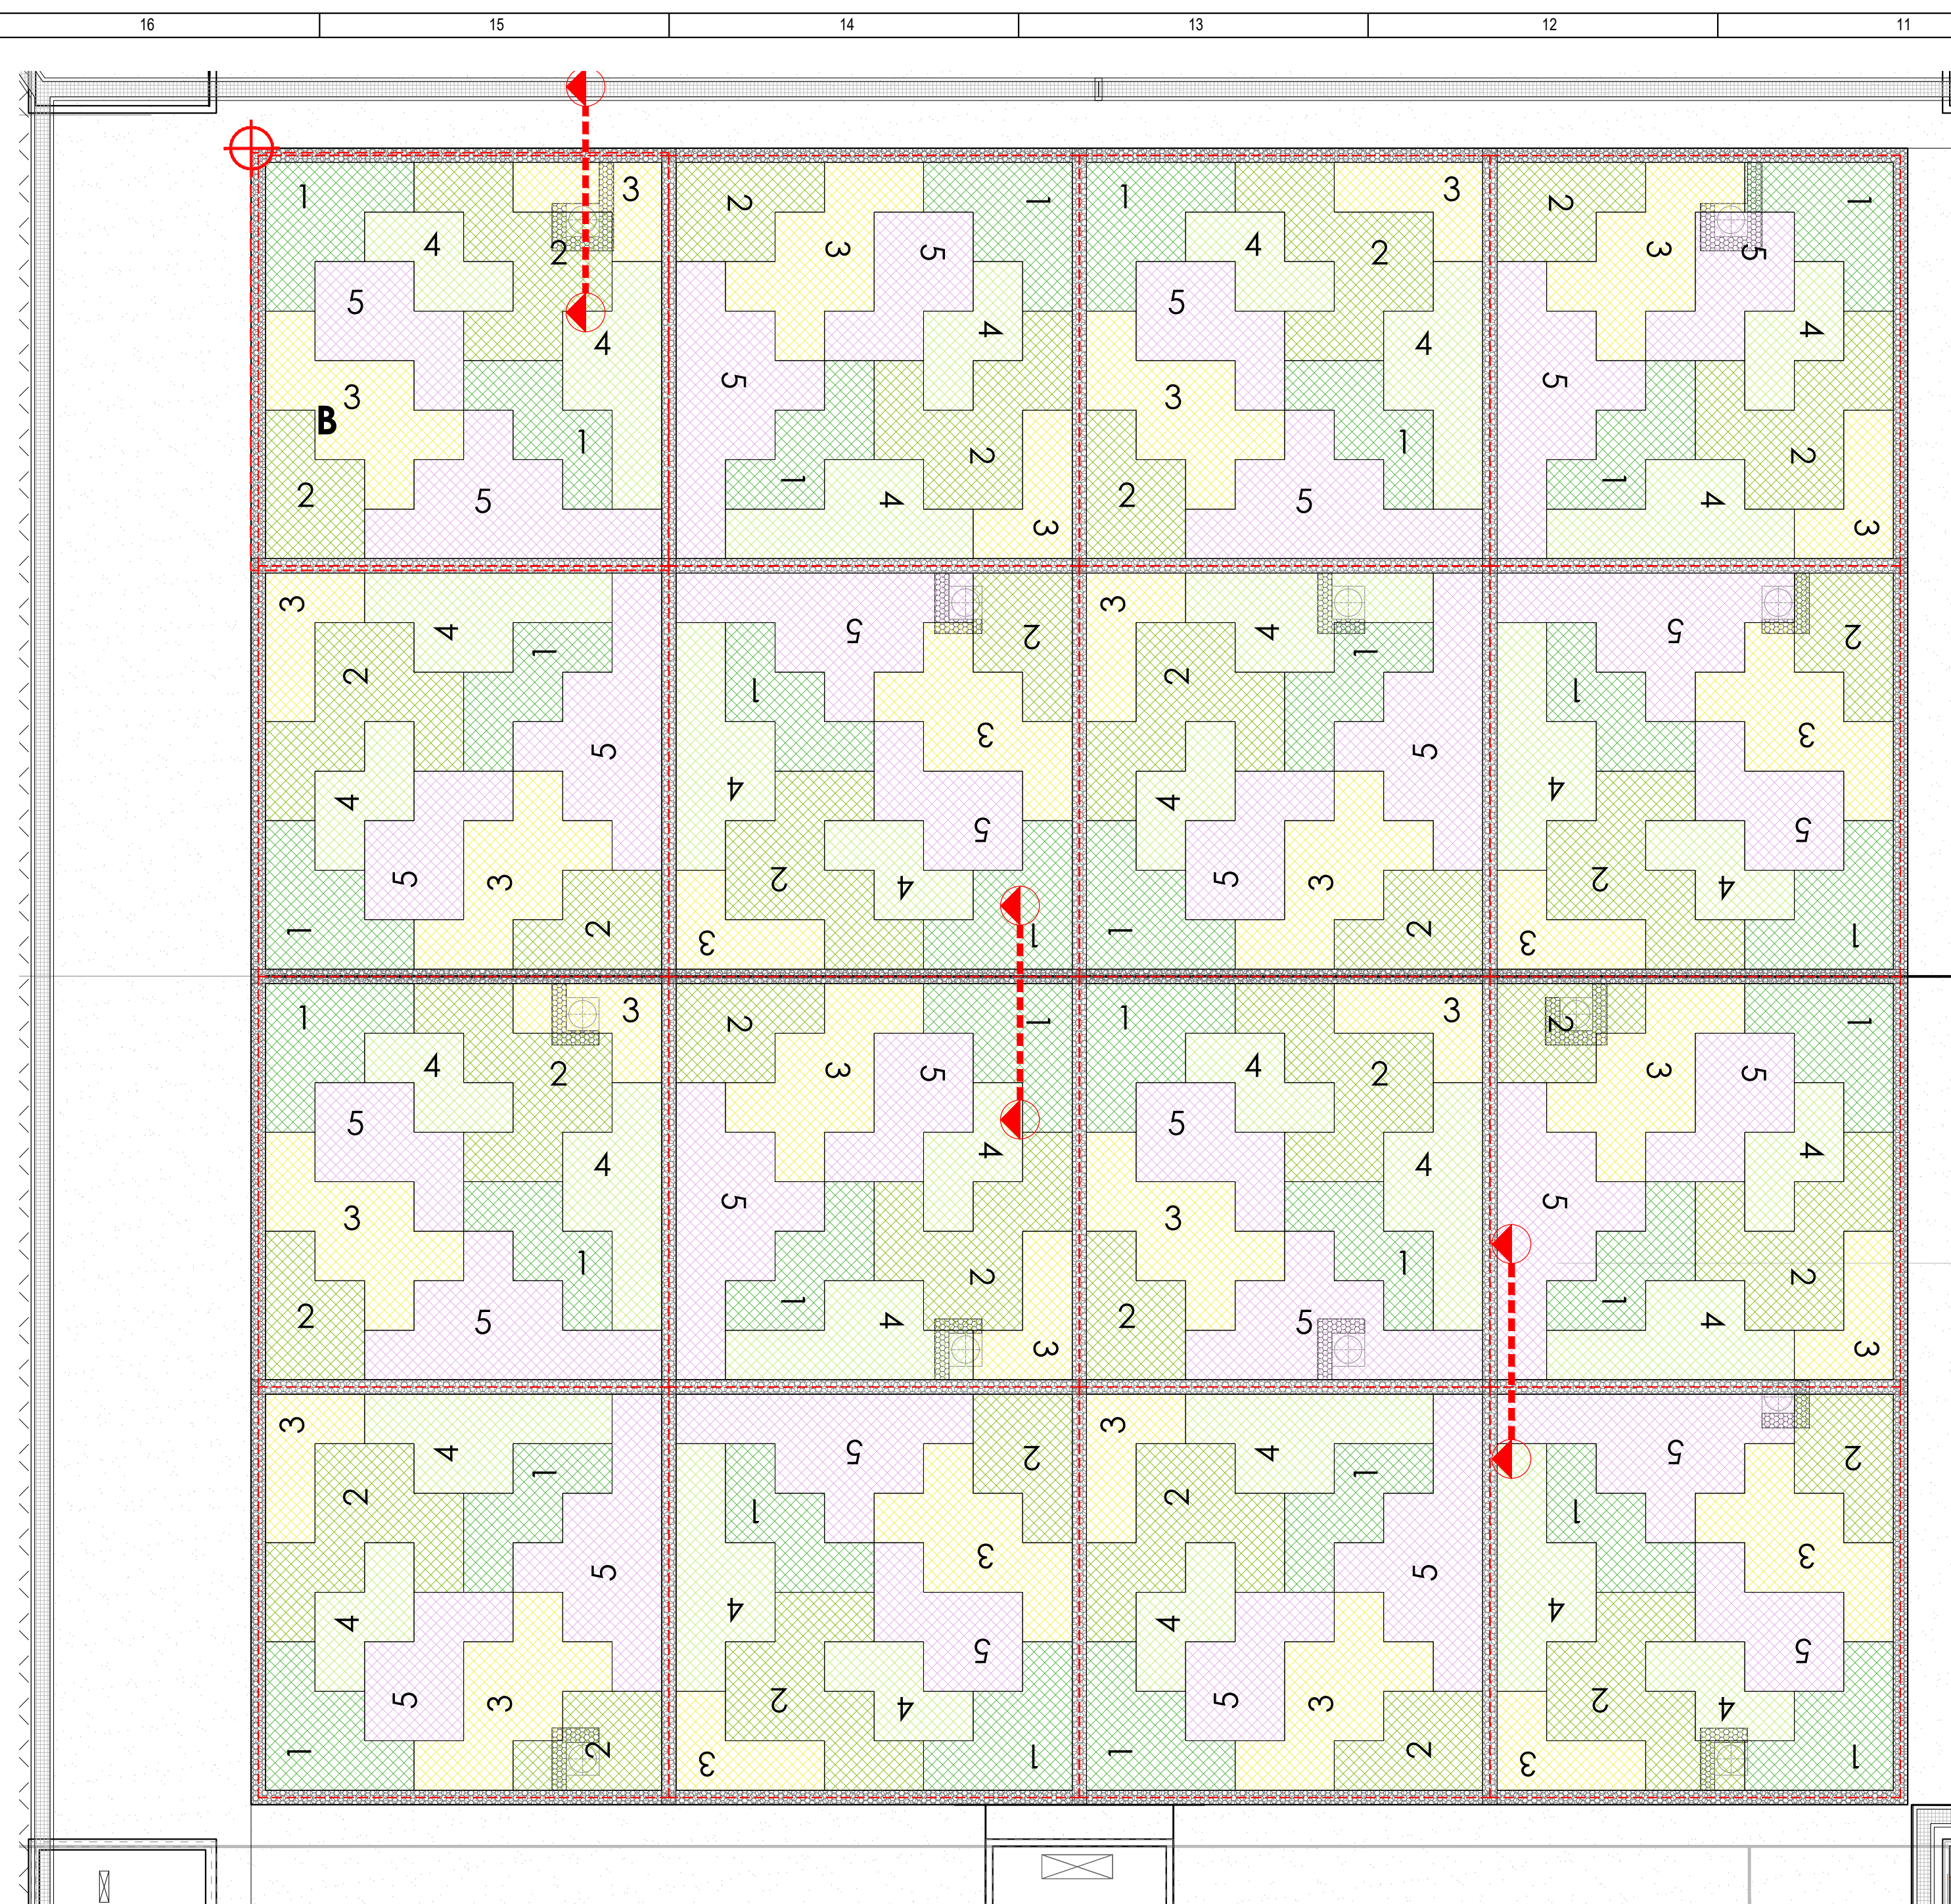

LEGEND:

- PHASE LINE FOR COMPLETE LANDSCAPE
- PHASE LINE FOR ROAD AND SIGNAGE
- METRO LINE
- METRO CONNECTION

ABBREVIATION:

- FFL - FINISHED FLOOR LEVEL
- FRL - FORMED ROAD LEVEL
- FPL - FORMED PAVEMENT LEVEL
- LVL - LEVEL
- TOPW - TOP OF PLANTER WALL
- TOF - TOP OF FILL

NOTES:

- ALL DIMENSIONS ARE IN MILLIMETERS. LEVELS IN METERS AND ANGLES IN DEGREES UNLESS OTHERWISE NOTED.
- THE DRAWING IS TO BE READ AND NOT TO BE SCALED; ONLY WRITTEN DIMENSIONS IN ALL CASES SHALL BE FOLLOWED.
- THE DRAWING SHALL BE READ IN CONJUNCTION WITH ALL RELEVANT ARCHITECTURAL, STRUCTURAL AND SERVICE DRAWINGS.
- ALL DIMENSIONS SHALL BE VERIFIED ON SITE PRIOR TO START OF WORK AND ANY DISCREPANCY SHALL BE BROUGHT TO THE NOTICE OF THE ARCHITECT.
- KINDLY FOLLOW ARCHITECTURE AND STRUCTURE ROOF BUILT UP SEPARATE DRAWING

NOTES:

- REFER DRAWING NUMBER- O17203-A-SP-01-WD-0009-EH1 ROOF PLAN FOR EH1 ARCHITECTURAL ROOF PLAN
- REFER DRAWING NUMBER- O17203-A-SP-02-WD-0009-EH2-ROOF PLAN FOR EH2 ARCHITECTURAL ROOF PLAN
- REFER DRAWING NUMBER- O17203-A-SP-02-WD-0104-EH1-ROOF PLAN-FOR EH1 ROOF GARDEN DETAILS
- REFER DRAWING NUMBER- O17203-A-SP-02-WD-0105-EH2-ROOF PLAN-FOR EH2 ROOF GARDEN DETAILS
- REFER ELECTRICAL EH-1 DRG NO : O17203-E-SP-01-LL-0021,0022, & 0024 FOR TERRACE SERVICES LIGHTING LAYOUT.
- REFER ELECTRICAL EH-2 DRG NO : O17203-E-SP-02-LL-0021,0022,0023 & 0024 FOR TERRACE SERVICES LIGHTING LAYOUT.

DRIP IRRIGATION SYSTEM TO BE USED (IRRIGATION LAYOUT TO BE PROVIDED BY VENDOR)

LANDSCAPE DRAWINGS TO BE READ IN CONJUNCTION WITH ARCHITECTURAL DRAWINGS

Key Plan:

Owner / Employer:

India International Convention & Exhibition Centre Limited
Room No. 624, Ministry of Commerce & Industry,
DPP, Lodhi Brown, New Delhi - 110011, India

Department of Industrial Policy and Promotion Ministry of Commerce & Industry Government of India

Knowledge Partner:

Delhi Mumbai Industrial Corridor Development Corporation
Room No 341 B, 3rd Floor, Huda A-2, Sector 15, Gurgaon, Haryana, India
New Delhi - 110028

Employer's Representative:

Employer Engineer:
Programme Management Consultant (PAC)

AECOM

Preliminary Engineering Architecture Consultants (PEAC)

idm

A-2, Dwarka Sector 15, Block 4, HUDA, New Delhi 110046, India

CPKUREJA

CPKUREJA & ASSOCIATES
New Delhi 110046, India

EPC Contractor:

L&T Construction
Buildings & Factories
New Delhi 110046, India

EPC Contractor's Representative:

Design Consultant:
Engineering Design and Research Center (EDRC)
L&T Construction - Buildings & Factories

Architectural Consultant:
ARCO P
Arco Associates Pvt. Ltd.
A-15, Connaught Place, New Delhi 110048, India

Structural Proof Consultant:
Indian Institute of Technology (IIT) Madras
Sector 25, Dwarka, New Delhi 110046, India

MEP Proof Consultant:
Egis India Consulting Engineers Pvt. Ltd.
Plot No. 44, Sector 32, Institutional Area, Gurgaon, Haryana 122001

ICT Proof Consultant:
CKR Consulting Engineers Pvt. Ltd.
44/1, 3rd Floor, Naraina Road, Subhashpuri Road, Vasant Vihar, New Delhi 110046, India

Certification:

EPC Contractor:

Design Consultant:

Architectural Consultant:

Proof Consultant:

Structural:

MEP:

ICT:

PEAC:

Issued By:
Employer / Employer's Engineer

REVISIONS:

REV	DESCRIPTION	DATE	DESIGN	DRAWN	CHECKED	APPROVED
01	GOOD FOR CONSTRUCTION	16.08.20	RL	TA	RL	PK

Project Name:
DESIGN AND CONSTRUCTION OF INDIA INTERNATIONAL CONVENTION & EXPO CENTRE
SECTOR 25, DWARKA, NEW DELHI, INDIA

Drawing Status:
GOOD FOR CONSTRUCTION

Drawing No:
N 00 1702

Rev. No:
R0

Title:
ROOF GARDEN (EXHIBITION HALL 1 AND 2 - TYPICAL DETAILS)

EDRC DWG No:
O17203-N-SP-00-WD-1702

Scale:
AS SHOWN

Sheet Size:
A0

