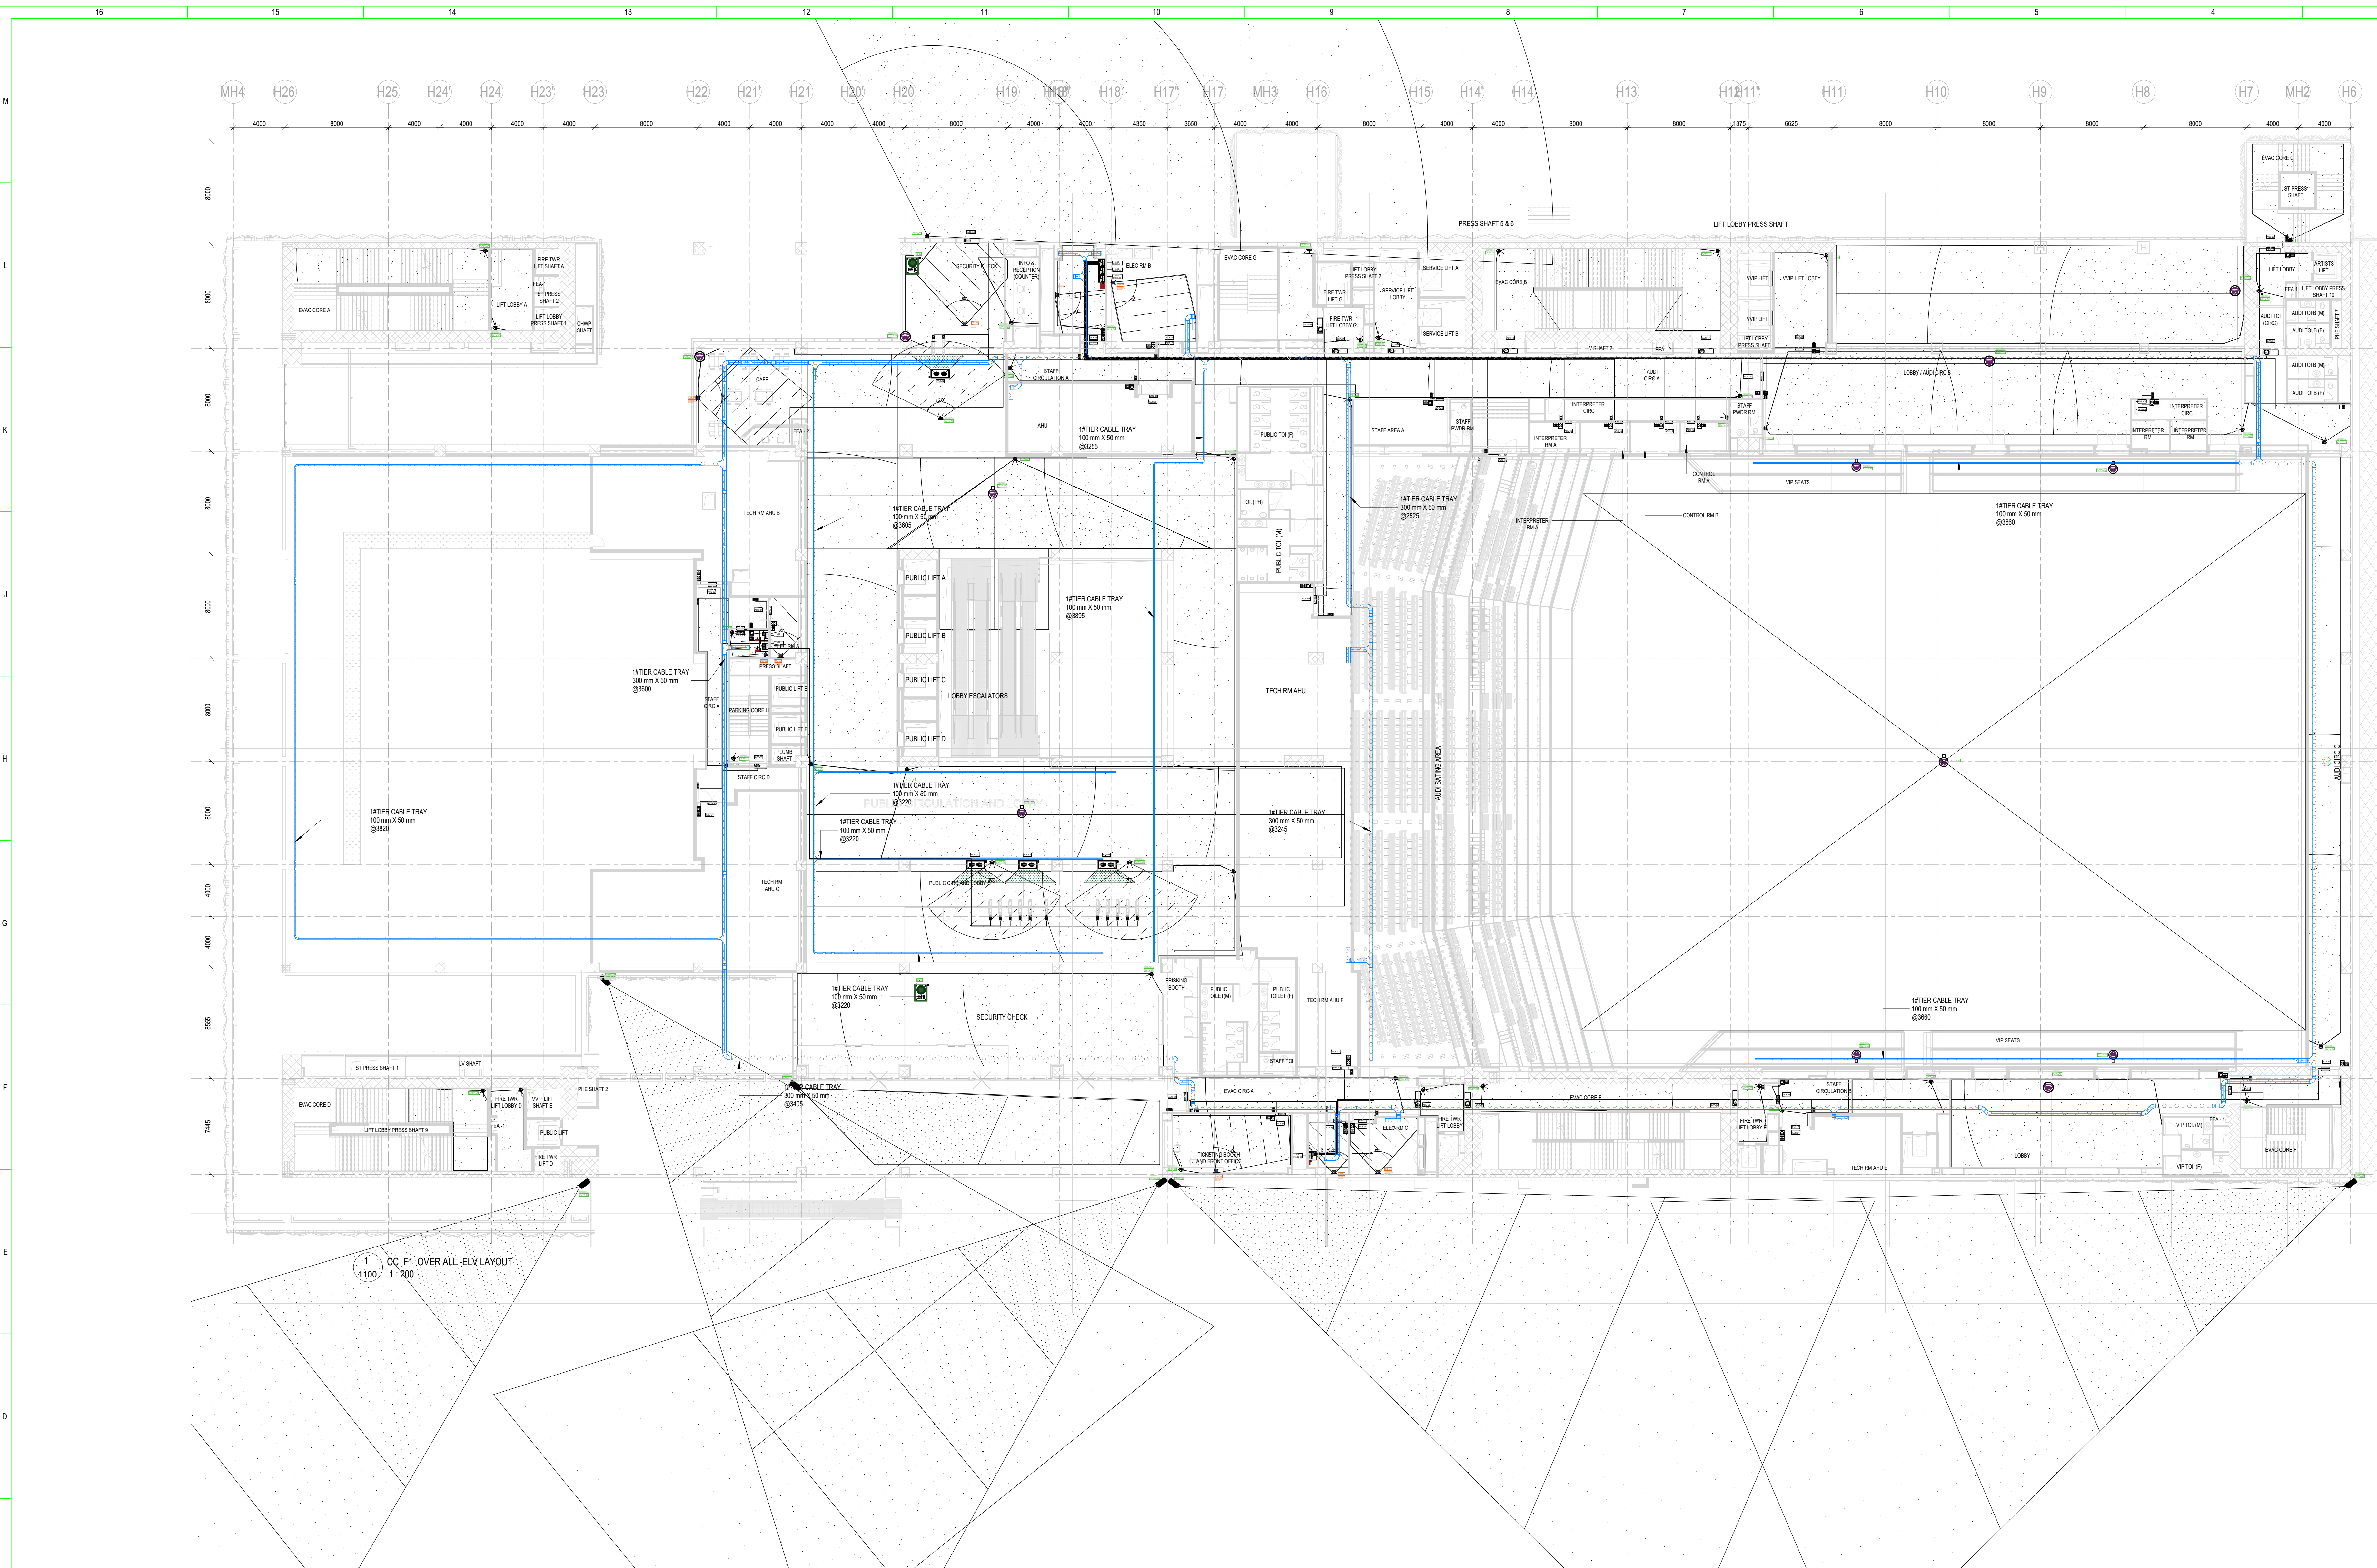




REFERENCE DRAWING

ARCHITECTURE
FLOOR PLANS APPROVED VIA TRANSMITTAL NO EDCR-8&F/017203/01346

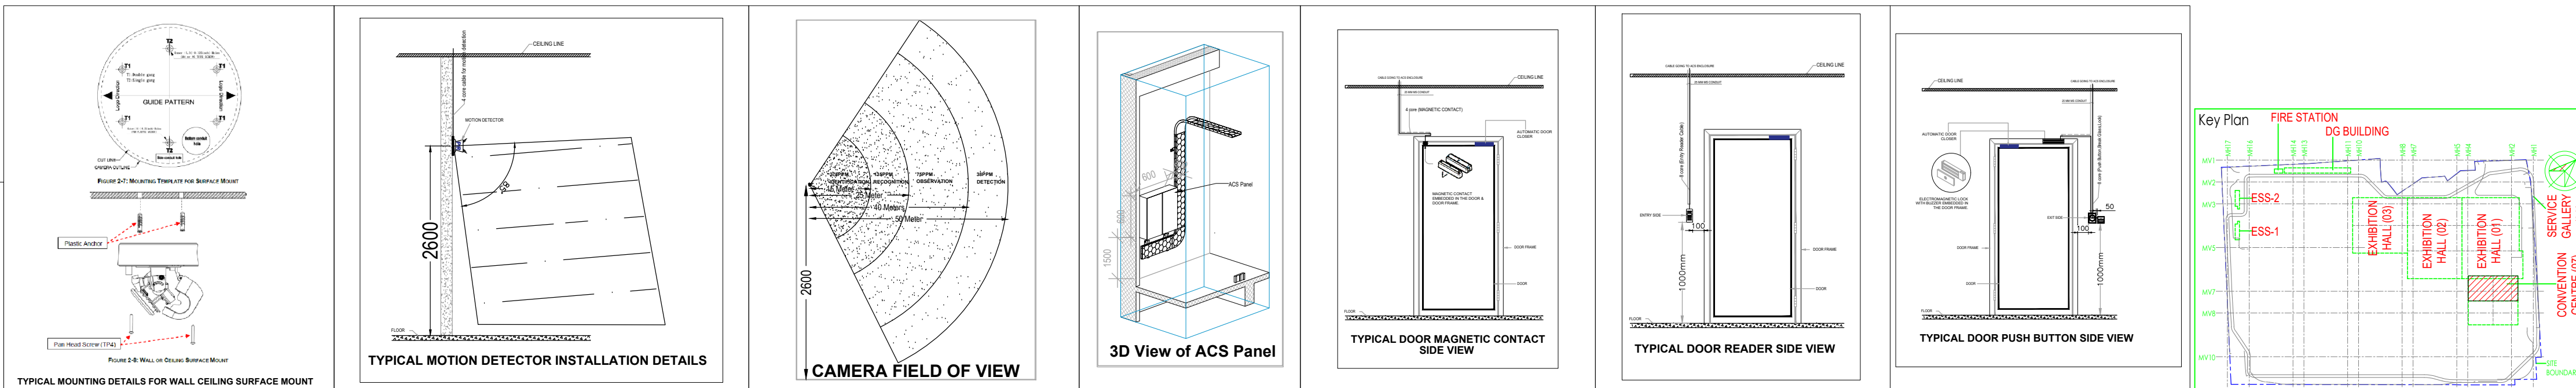
STRUCTURE
017203-C-SP-07-NU-0006 - LAYOUT AND NUMERATION DETAIL OF LEVEL - F2 (+9.220M)

ELECTRICAL
017203-E-SP-07-LL-0028 TO 0032 - CONVENTION CENTER - FIRST FLOOR FF - LIGHTING LAYOUTS
017203-E-SP-07-PL-0138 TO 0140 - CONVENTION CENTER - FIRST FLOOR FF - POWER LAYOUTS
017203-E-SP-07-EE-0208 TO 0242 - CONVENTION CENTER - F0 - ELECTRICAL EQUIPMENT, CABLE TRAY & EARTHING LAYOUT - OVERALL PLAN
017203-F-SP-07-PL-0013 - CONVENTION CENTRE - FF - OVER ALL PLAN LAYOUT OF WETRISER CUM DOWNCOMER, AUTOMATIC SPRINKLER SYSTEM AND PORTABLE FIRST AID FIRE EXTINGUISHERS
017203-F-SP-07-FA-0014 - CONVENTION CENTRE - FF - OVER ALL PLAN LAYOUT OF INTEGRATED INTELLIGENT ADDRESSABLE FIRE DETECTION & ALARM SYSTEM AND PHOTO LUMINESCENT SAFETY SIGNAGES
017203-V-SP-07-AC-1004,2004,3004,4004,5004 & 6004 - CONVENTION CENTRE FIRST FLOOR FF - HVAC EQUIPMENT DUCTING AND PIPING LAYOUT
017203-U-SP-07-IP-0021 TO 0024 - PLUMBING SYSTEM LAYOUT - FIRST FLOOR FF - TOILET WATER SUPPLY LAYOUT

ELV
017203-L-SP-07-LE-5100 - CONVENTION CENTER-FIRST FLOOR-STRIPTR ROOM LAYOUT
017203-L-SP-07-DV-2100 - CONVENTION CENTER-FIRST FLOOR OVERALL DATA AND VOICESYSTEM LAYOUT
017203-L-SP-07-LV-1111/1120/1133/1144 - FIRST FLOOR-ELV SYSTEM ZONE LAYOUT
FOR SECURITY CHECK EQUIPMENT/TURNSTILES
REFER DRAWING NO - 017203-L-SP-07-LV-6100-FIRST FLOOR

- GENERAL NOTE**
- ALL DIMENSIONS ARE IN MILLIMETER UNLESS OTHERWISE SPECIFIED.
 - EXACT ROUTING SHALL BE DECIDED AT SITE IN CONSULTATION WITH ENGINEERING IN CHARGE TO SUIT SITE CONDITIONS.
 - MS CONDUIT USED FOR OPEN APPLICATION.
 - THIS DRAWING IS ONLY INDICATIVE AND MAY VARY ACCORDING TO SITE CONDITION AND REQUIREMENT.
 - 50% SPARE IS MAINTAINED IN CONDUIT.
- CCTV & ACS SYSTEM**
- IP POINT HAS TO BE MADE AVAILABLE NEAR EACH CAMERA. REFER DATA VOICE LAYOUT-017203-L-SP-07-DV-2100.
 - THE CCTV CAMERA VIEW ANGLE TO BE SET AS PER THE COVERAGE LOCATION.
 - ALL SCHEMATICS DRAWING SHALL BE SUBMITTED SEPARATELY.
 - IP POINT HAS TO BE MADE AVAILABLE NEAR EACH ACS CONTROLLER. REFER DATA VOICE LAYOUT-017203-L-SP-07-DV-2100.
- IP TALK BACK SYSTEM**
- CAT6A, 4 PAIR TWISTED PAIR UTPP CABLES SHALL BE USED TO CONNECT WITH NEAREST AVAILABLE IP POINT.

ACS LEGENDS		CCTV LEGENDS	
SYMBOL	DESCRIPTION	SYMBOL	DESCRIPTION
1	IP TALK BACK SYSTEM	1	IP TALK BACK SYSTEM
2	IP TALK BACK SYSTEM	2	IP TALK BACK SYSTEM
3	IP TALK BACK SYSTEM	3	IP TALK BACK SYSTEM
4	IP TALK BACK SYSTEM	4	IP TALK BACK SYSTEM
5	IP TALK BACK SYSTEM	5	IP TALK BACK SYSTEM
6	IP TALK BACK SYSTEM	6	IP TALK BACK SYSTEM
7	IP TALK BACK SYSTEM	7	IP TALK BACK SYSTEM
8	IP TALK BACK SYSTEM	8	IP TALK BACK SYSTEM
9	IP TALK BACK SYSTEM	9	IP TALK BACK SYSTEM
10	IP TALK BACK SYSTEM	10	IP TALK BACK SYSTEM
11	IP TALK BACK SYSTEM	11	IP TALK BACK SYSTEM
12	IP TALK BACK SYSTEM	12	IP TALK BACK SYSTEM
13	IP TALK BACK SYSTEM	13	IP TALK BACK SYSTEM
14	IP TALK BACK SYSTEM	14	IP TALK BACK SYSTEM
15	IP TALK BACK SYSTEM	15	IP TALK BACK SYSTEM
16	IP TALK BACK SYSTEM	16	IP TALK BACK SYSTEM
17	IP TALK BACK SYSTEM	17	IP TALK BACK SYSTEM
18	IP TALK BACK SYSTEM	18	IP TALK BACK SYSTEM
19	IP TALK BACK SYSTEM	19	IP TALK BACK SYSTEM
20	IP TALK BACK SYSTEM	20	IP TALK BACK SYSTEM



Owner / Employer

India International Convention & Exhibition Centre Limited
Room No. 42A, Ministry of Commerce & Industry, DPT, 15002, New Delhi, India

Department of Industrial Policy and Promotion, Ministry of Commerce & Industry, Government of India

Knowledge Partner

Delhi Mumbai Industrial Corridor Development Corporation
Room No. 301 & 302, 3rd Floor, 1st Block, Diplomatic Enclave, SEE Convent, New Delhi - 110021

Employer's Representative

Programme Management Consultant (PMC)

AECOM

Preliminary Engineering Architecture Consultants (PEAC)

idom **CPKUREJA**

A-1, De Montfort, de B. Street, 4, New Delhi, Delhi 110016, India

EPC Contractor

L&T Construction
Buildings & Factories
New Delhi, Delhi 110048, India

EPC Contractor's Representatives

Design Consultant
Engineering Design and Research Center (EDRC)
L&T Construction - Buildings & Factories

Architectural Consultant
ARCO
New Delhi, Delhi 110048, India

Structural Proof Consultant

Indian Institute of Technology (IIT) Madras
Sector 1, Chennai, Tamil Nadu, India

MEP Proof Consultant

Egis India Consulting Engineers Pvt. Ltd.
101 No. 4, Sector 12, Industrial Area, Opp. Jindal Solutions, Gurgaon, Haryana 122001

ICT Proof Consultant

CR Consulting Engineers Pvt. Ltd.
4/11, 3rd Floor, Naraina Arcade, Subhash Chandra Road, Naraina Circle, New Delhi, Delhi 110028

Certification

EPC Contractor

Design Consultant

Architectural Consultant

Proof Consultant

MEP **ICT**

PEAC

Issued by:
Employer / Employer's Engineer

NO	REVISION	DATE	BY	SS	MSK	GHR
1	ISSUED AS GOOD FOR CONSTRUCTION	30.01.20	BVH	SS	MSK	GHR

Revisions

ARCHITECTURE	RPS				
STRUCTURAL	PPPP				
ELECTRICAL	PPPP				
ELV SYSTEM	GG				
HVAC	GG				

CHECKED BY: SSKH DATE: 30.01.20

EPC Contractor

L&T Construction
Buildings & Factories

JOB No: 017203

Project Name
DESIGN AND CONSTRUCTION OF INDIA INTERNATIONAL CONVENTIONAL & EXPO CENTRE
SECTOR 25, DOWRAJ, NEW DELHI, INDIA

Drawing Status
GOOD FOR CONSTRUCTION (GFC)

Drawing No
L 07 1100 R0

Title
CONVENTION CENTRE-FIRST FLOOR-OVER ALL ELV SYSTEM LAYOUT

EDRC DWG NO: 017203-L-SP-07-LV-1100

Scale
AS INDICATED

Sheet Size
A0

017203-L-07-1100-CONVENTION CENTRE-FIRST FLOOR-OVER ALL ELV SYSTEM LAYOUT

This drawing is the property of L&T Construction. All EDCR-8&F/017203/01346 is the property of L&T Construction. All EDCR-8&F/017203/01346 is the property of L&T Construction. All EDCR-8&F/017203/01346 is the property of L&T Construction.



NO	ISSUED AS GOOD FOR CONSTRUCTION	8.01.20	BVH	SS	MSC	GNR
REV	DESCRIPTION	DATE	DSGN	DRWN	CHKD	APPD
Revisions						
	ARCHITECTURE		FPS			
	STRUCTURAL		PPNG			
	ELECTRICAL		PHE			
	ELV SYSTEM		GS			
	HVAC		GEOTECH.			
CHECKED BY	SIGN	DATE	CHECKED BY	SIGN	DATE	

EPC Contractor
 **L&T Construction**
Buildings & Factories
 JOB No : O17203

Project Name
DESIGN AND CONSTRUCTION OF INDIA
INTERNATIONAL CONVENTIONAL & EXPO CENTRE
SECTOR 25, DWARKA, NEW DELHI, INDIA

Drawing Status

GOOD FOR CONSTRUCTION (GFC)

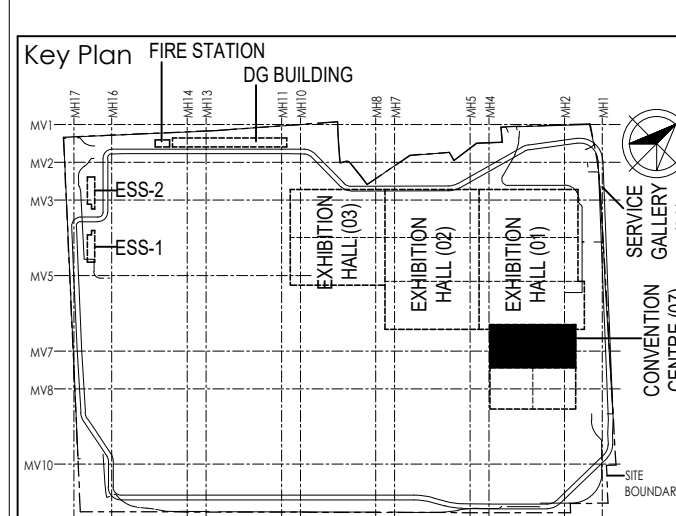
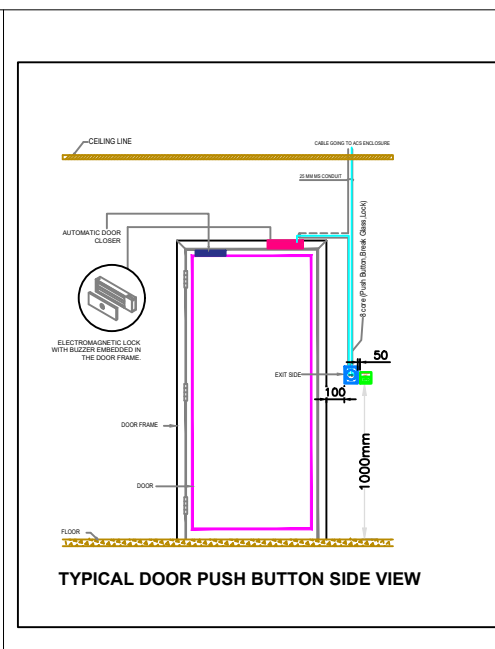
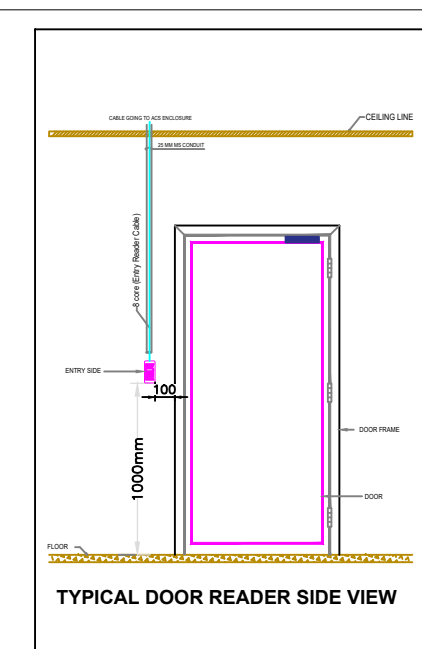
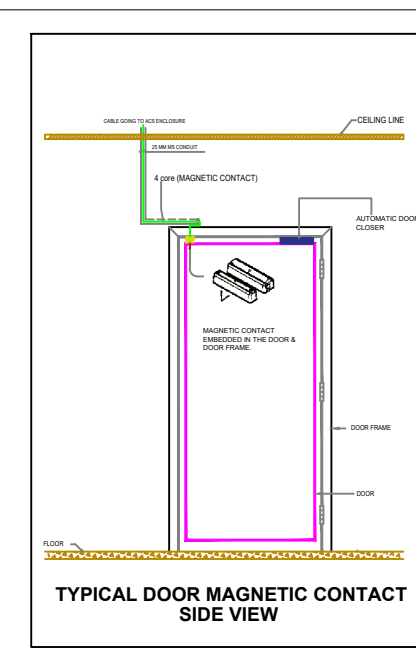
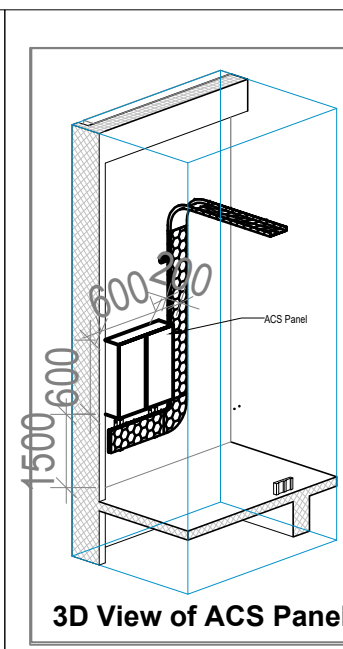
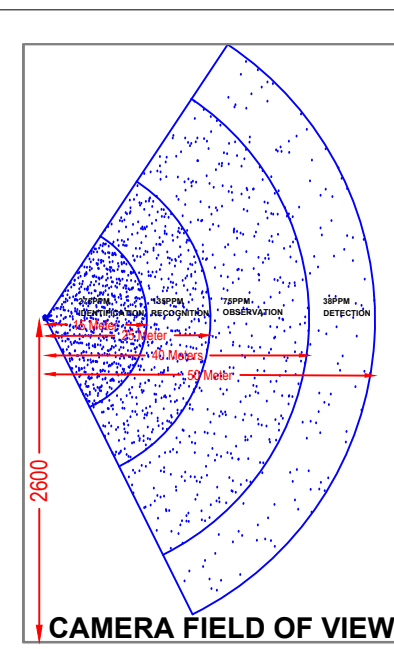
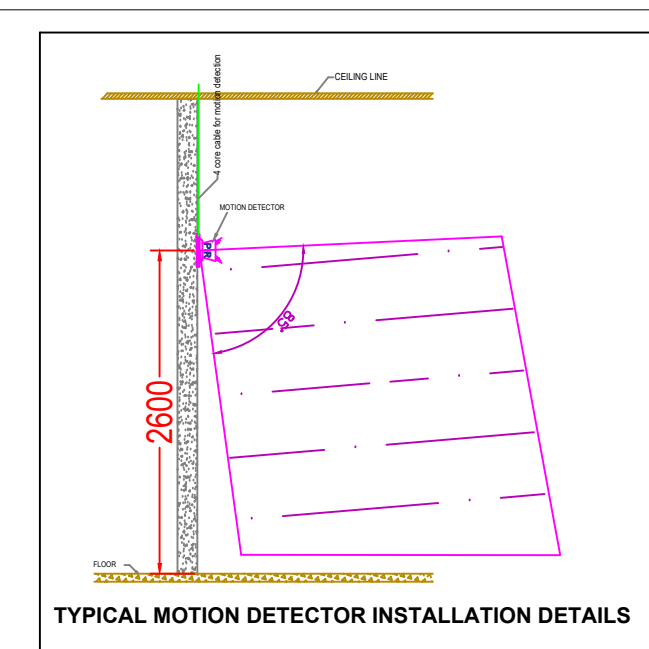
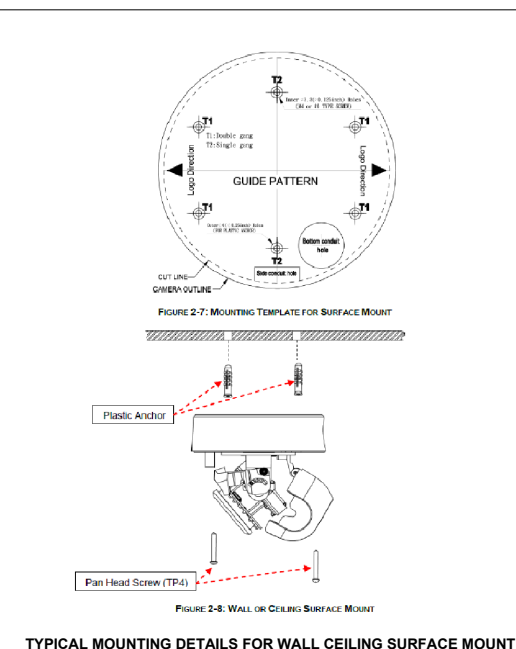
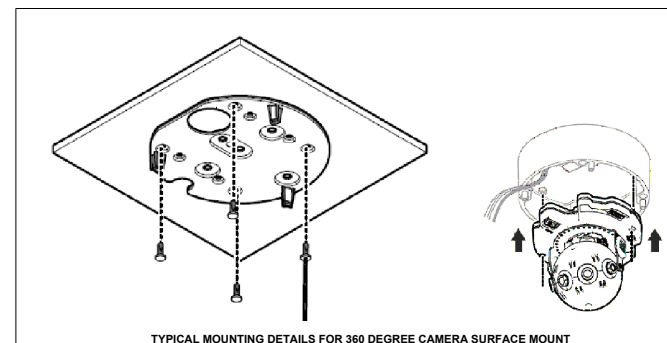
Drawing No	Rev. No
L 07 1200	R0

Title :
CONVENTION CENTER-2F-OVERALL ELV
SYSTEM LAYOUT

EDRC DWG No : O17203-L-SP-07-LV-1200	Scale AS INDICATED	Sheet Size A0
---	-----------------------	------------------

017203 - L - 07 - 1203 (CONVENTION CENTER-2F-OVERALL ELV. SYSTEM LAYOUT)

1 CC 3F OVER ALL - ELV LAYOUT
1300 1:200

[illegible]

REFERENCE DRAWING

ARCHITECTURE
FLOOR PLANS APPROVED VIA TRANSMITTAL NO EDRG-B&G/17023031346

STRUCTURE
OT1023-C-SP-07-01-008 - LAYOUT AND NUMERATION DETAIL OF LEVEL - F4 (18.520M)

ELECTRICAL
OT1023-C-SP-07-01-L0046 - CONVENTION CENTER - THIRD FLOOR 3F - LIGHTING LAYOUTS
OT1023-C-SP-07-01-0154 - CONVENTION CENTER - THIRD FLOOR 3F - ELECTRICAL LAYOUTS
OT1023-C-SP-07-01-0258 - CONVENTION CENTER 3F - ELECTRICAL EQUIPMENT, CABLE TRAY & EARTHING LAYOUT - OVERALL PLAN
OT1023-C-SP-07-01-0019 - CONVENTION CENTER - 3F - OVERALL PLAN LAYOUT OF WETRISER CUP DOWNCOMER, AUTOMATIC SPRINKLER SYSTEM AND PORTABLE FIRST-AID FIRE EXTINGUISHERS
OT1023-C-SP-07-01-0020 - CONVENTION CENTER 3F - OVERALL PLAN LAYOUT OF INTEGRATED INTELLIGENT ADDRESSABLE FIRE DETECTION & ALARM SYSTEM AND PHOTOLUMINESCENT SAFETY SIGNAGES

Mechanical
OT1023-V-SP-07-01-0026 - CONVENTION CENTER THIRD FLOOR 3F - HVAC EQUIPMENT DUCTING AND PIPING LAYOUT
OT1023-V-SP-07-01-0070 TO 0083 - PLUMBING SYSTEM THIRD FLOOR 3F - TOILET WATER SUPPLY LAYOUT

GENERAL NOTE

1. ALL DIMENSIONS ARE IN MILLIMETER UNLESS OTHERWISE SPECIFIED.
2. EXACT ROUTING SHALL BE DECIDED AT SITE IN CONSULTATION WITH ENGINEERING IN CHARGE TO SUIT SITE CONDITIONS.
3. MS CONDUIT USED FOR POWER APPLICATION.
4. THIS DRAWING IS ONLY INDICATIVE AND MAY VARY ACCORDING TO SITE CONDITION AND REQUIREMENT.
5. 50% SPARE IS MAINTAINED IN CONDUIT.
6. CCTV & ACS SYSTEM
7. IP POINT HAS TO BE MADE AVAILABLE NEAR EACH CAMERA. REFER DATA VOICE LAYOUT-017203A-SP-07-DV-230
8. THE CCTV CAMERA NEED TO BE CONNECT AS PER THE WIRING LOCATION.
9. ALL SCHEMATICS DRAWING SHALL BE SUBMITTED SEPARATELY.
10. IP POINT HAS TO BE MADE AVAILABLE NEAR EACH ACS CONTROLLER. REFER DATA VOICE LAYOUT-017203A-SP-07-DV-230
11. IP TAP
12. CAT6A 4 PAIR TWISTED PAIR UTP/CABLES SHALL BE USED TO CONNECT WITH NEAREST AVAILABLE IP POINT

RD	ISSUED FOR GFC					
		31.01.20	BYH	SS	MSK	GNE
REV	DESCRIPTION	DATE	DSGN	DRWN	CHKD	APPR
Revisions						
ARCHITECTURE			FFS			
STRUCTURAL			PIPING			
ELECTRICAL			PHE			
ELV SYSTEM			GS			
HVAC			GEOTECH.			
CHECKED BY	SIGN	DATE	CHECKED BY	SIGN	DATE	

EPC Contractor



JOB No : O1720

Project Name	DESIGN AND CONSTRUCTION OF INDIA INTERNATIONAL CONVENTIONAL & EXPO CENTRE SECTOR 25,DWARKA,NEW DELHI,INDIA
--------------	--

Drawing Status
GOOD FOR CONSTRUCTION (GFC)

Drawing No			Rev. No
L	07	1300	R0

Title :

CONVENTION CENTER-3F-OVER ALL ELV SYSTEM LAYOUT

EDRC DWG No : O17203-L-SP-07-LV-1300	Scale AS INDICATED	Sheet Size A0
---	-----------------------	------------------

[illegible]



RD	ISSUED FOR GFC					
REV	DESCRIPTION	DATE	DSGN	DRWN	CHKD	APPD
		3.02.20	BVH	SS	MSK	GMR
Revisions						
ARCHITECTURE			PPS			
STRUCTURAL			PIPING			
ELECTRICAL			PHE			
ELV SYSTEM			GS			
HVAC			GEOTECH.			
CHECKED BY	SIGN	DATE	CHECKED BY	SIGN	DATE	

EPC Contractor

 **L&T Construction**
Buildings & Factories



JOB No : O17203

Project Name
DESIGN AND CONSTRUCTION OF INDIA
INTERNATIONAL CONVENTIONAL & EXPO CENTRE
SECTOR 25,DWARKA,NEW DELHI,INDIA

Drawing Status

GOOD FOR CONSTRUCTION (GFC)

Drawing No	Rev. No
L 07 1700	R0

Title :

CONVENTION CENTER-7F-OVER ALL ELV
SYSTEM LAYOUT

EDRC DWG No.:	Scale:	Sheet Size:

EDRC DWG NO:	Score	Sheet Size
O17203-L-SP-07-LV-1700	AS INDICATED	A0

REFERENCE DRAWING
ARCHITECTURE
FLOOR PLANS APPROVED VIA TRANSMITTAL NO EPRC-68F/017203/01346
STRUCTURE
017203-SP-07-NU-0012 - LAYOUT AND NUMERATION DETAIL OF LEVEL - 7F (±27.90M)
ELECTRICAL
017203-SP-07-LL-0026 - CONNECTION CENTER - SEVENTH FLOOR 7F - LIGHTING LAYOUT
017203-SP-07-LL-0180 - CONNECTION CENTER - SEVENTH FLOOR 7F - POWER LAYOUT
017203-SP-07-ELE-0028 - CONNECTION CENTER 7F - ELECTRICAL EQUIPMENT, CABLE TRAY & CONNECTION LAYOUT
017203-SP-07-PL-0001 - CONNECTION CENTER 7F - OVER ALL PLAIN LAYOUT OF WETRISUM CUM DOWNCOMER, AUTOMATIC SPRINKLER SYSTEM AND PORTABLE FIRST-AID FIRE EXTINGUISHERS
017203-SP-07-FA-0032 - CONNECTION CENTER - 7F - OVER ALL PLAIN LAYOUT OF INTEGRATED INTELLIGENT FIRE DETECTION & ALARM SYSTEM AND PHOTOVOLTAIC-INDUCED SAFETY SIGNAGES
HVAC
017203-SP-07-AC-0030 - CONNECTION CENTRE SEVENTH FLOOR 7F - HVAC EQUIPMENT DUCTING AND SUPPLY LAID
PHE
017203-SP-07-PO-0043 to 0045 - PLUMBING SYSTEM LAYOUT - SEVENTH FLOOR 7F - TOILET WATER PIPING LAYOUT

GENERAL NOTE:

1. ALL DIMENSIONS ARE IN MILLIMETER UNLESS OTHERWISE SPECIFIED.
2. EXACT ROUTING SHALL BE DECIDED AT THE SITE IN CONSULTATION WITH ENGINEER.
3. MS CONDUIT USED FOR OPEN APPLICATION.
4. THIS DRAWING IS ONLY INDICATIVE AND MAY VARY ACCORDING TO SITE CONDITION AND REQUIREMENT.
5. 10% SPARE IS MAINTAINED IN CONDUIT.

CCTV & ACS SYSTEM

1. THE CAMERA HAS TO BE MADE AVAILABLE NEAR EACH CAMERA REFER DATA VOICE LAUNCH-V0172933-SP-07-DV-270.
2. THE CCTV CAMERA VIEW ANGLE TO BE SET AS PER THE COVERAGE LOCATION.
3. ALL SCHEMATICS DRAWING SHALL BE SUBMITTED SEPARATELY.
4. POINT HAS TO BE MADE AVAILABLE NEAR EACH ACS CONTROLLER REFER DATA VOICE LAUNCH-V0172933-SP-07-DV-270.

IP TALK BACK SYSTEM

1. THE WIRELESS WIRE MISTED PAIR (U/TP) CABLES SHALL BE USED TO CONNECT WITH NEAREST AVAILABLE IP POINT

[illegible]

CCTV LEGENDS		
	INDOOR/OUTDOOR FIXED CAMERA (Model: P-FLD-30, Model No.: MPF21-1050)	MOUNTING HEIGHT: 2.0M-2.5M
	OUTDOOR BULLET CAMERA (Model: P-FLD-30, Model No.: MPF21-1050)	MOUNTING HEIGHT: 2.0M-2.5M
	INDOOR/OUTDOOR 360 DEG CAMERA (Model: P-FLD-30, Model No.: MPF21-1050)	MOUNTING HEIGHT: 2.0M-2.5M
	INDOOR/OUTDOOR 360 DEG ROTARY DOME CAMERA (Model: P-FLD-30, Model No.: MPF21-1050)	MOUNTING HEIGHT: 2.0M-2.5M
	PTZ/PTC (CCTV)	MOUNTING HEIGHT: 2.0M-2.5M
OTHER YENIDOR ELEMENT		
	24 Port Ethernet Port	
	UPS Power Supply Unit (220V 5 AMP)	

FIGURE 2-2: Illustration of the alignment of the Balance of Mount

Technical drawing of a road cross-section. The drawing shows a road surface with a width of 2600mm, a shoulder of 100mm, and a curb of 100mm. The road surface is labeled 'ROAD SURFACE', the shoulder is labeled 'SHOULDER', and the curb is labeled 'CURB'. The drawing is a cross-section view, showing the road surface, shoulder, and curb in profile. The road surface is a flat line, the shoulder is a sloped line, and the curb is a vertical line. The dimensions are indicated by arrows and numbers.

1702303-F-SP-07-FA-0032 - CONVENTION CENTRE - 7F ADDRESSABLE
FIRE DETECTION & ALARM SYSTEM AND PHOTOLUMINESCENT
HVC
1702303-V-SP-07-AC-0030 - CONVENTION CENTRE SE
PNE
1702303-U-SP-07-IP-0043 to 0045 - PLUMBING SYSTEM

[illegible][illegible]

017203 - L - 07 - 1700 (CONVENTION CENTER-7F-OVER ALL ELV SYSTEM LAYOUT)



NO	ISSUED AS GOOD FOR CONSTRUCTION	31.01.20	BYH	SS	MSK	GAR
REV	DESCRIPTION	DATE	DSGN	DRWN	CHKD	APPD
Revisions						
ARCHITECTURE			PPS			
STRUCTURAL			PPMPG			
ELECTRICAL			PHE			
ELV SYSTEM			GIS			
HVAC			GEOTECH.			
CHECKED BY	SGM	DATE	CHECKED BY	SGM	DATE	

BFC Contractor  L&T Construction <i>Buildings & Factories</i>			
JOB No : 017203			
Project Name			
DESIGN AND CONSTRUCTION OF INDIA INTERNATIONAL CONVENTIONAL & EXPO CENTRE			
SECTOR 25 DWARKA, NEW DELHI,INDIA			
Drawing Status			
GOOD FOR CONSTRUCTION (GFC)			
Drawing No		Rev. No	
L	07	1902	R0
Title :			
CONVENTION CENTRE-BASEMENT 1-OVER ALL ELV SYSTEM LAYOUT			
EDRC DWG No :		Scale	Sheet Size
017203-L-SP-07-LV-1902		AS INDICATED	A0

1017203 - 1902 - 1 (CONVENTION CENTRE-BASEMENT 1-OVER ALL ELV SYSTEM LAYOUT)