


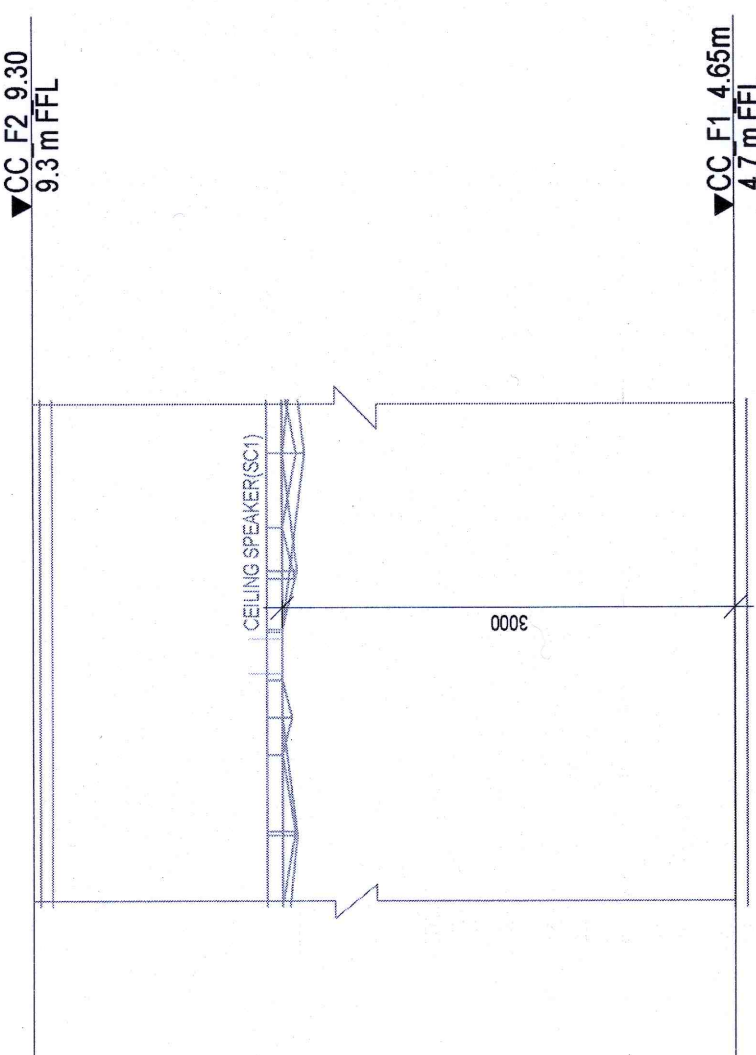


NOTE: THE FOLLOWING INFORMATION IS NOT TO BE REPRODUCED OR TRANSMITED IN ANY FORM OR BY ANY MEANS, ELECTRONIC OR MECHANICAL, INCLUDING PHOTOCOPYING, RECORDING, OR BY ANY INFORMATION STORAGE AND RETRIEVAL SYSTEM, WITHOUT PERMISSION IN WRITING FROM THE U.S. GOVERNMENT PRINTING OFFICE.

LEGENDS						
S.NO	SYMBOL	DEVICE ID	TELEPHONE SPEC	DESCRIPTION	MOUNTING HEIGHT	QTY
1		5C2	94	#1 LOW PROFILE 1 WAY	CEILING MOUNTED	02 Nos
2		5C1	94	HIGH PROFILE 8" CEILING S/N	CEILING MOUNTED	07 Nos
3		DS10		PAGING STATION	DESK MOUNTED	03 Nos
4		CMC	100	NOISE CANCELLATION MICROPHONE	CEILING MOUNTED	02 Nos
5		EIK		EQUIPMENT RACK	FLOOR MOUNTED	02 Nos

[illegible]


A SECTION A
3054 1 : 50

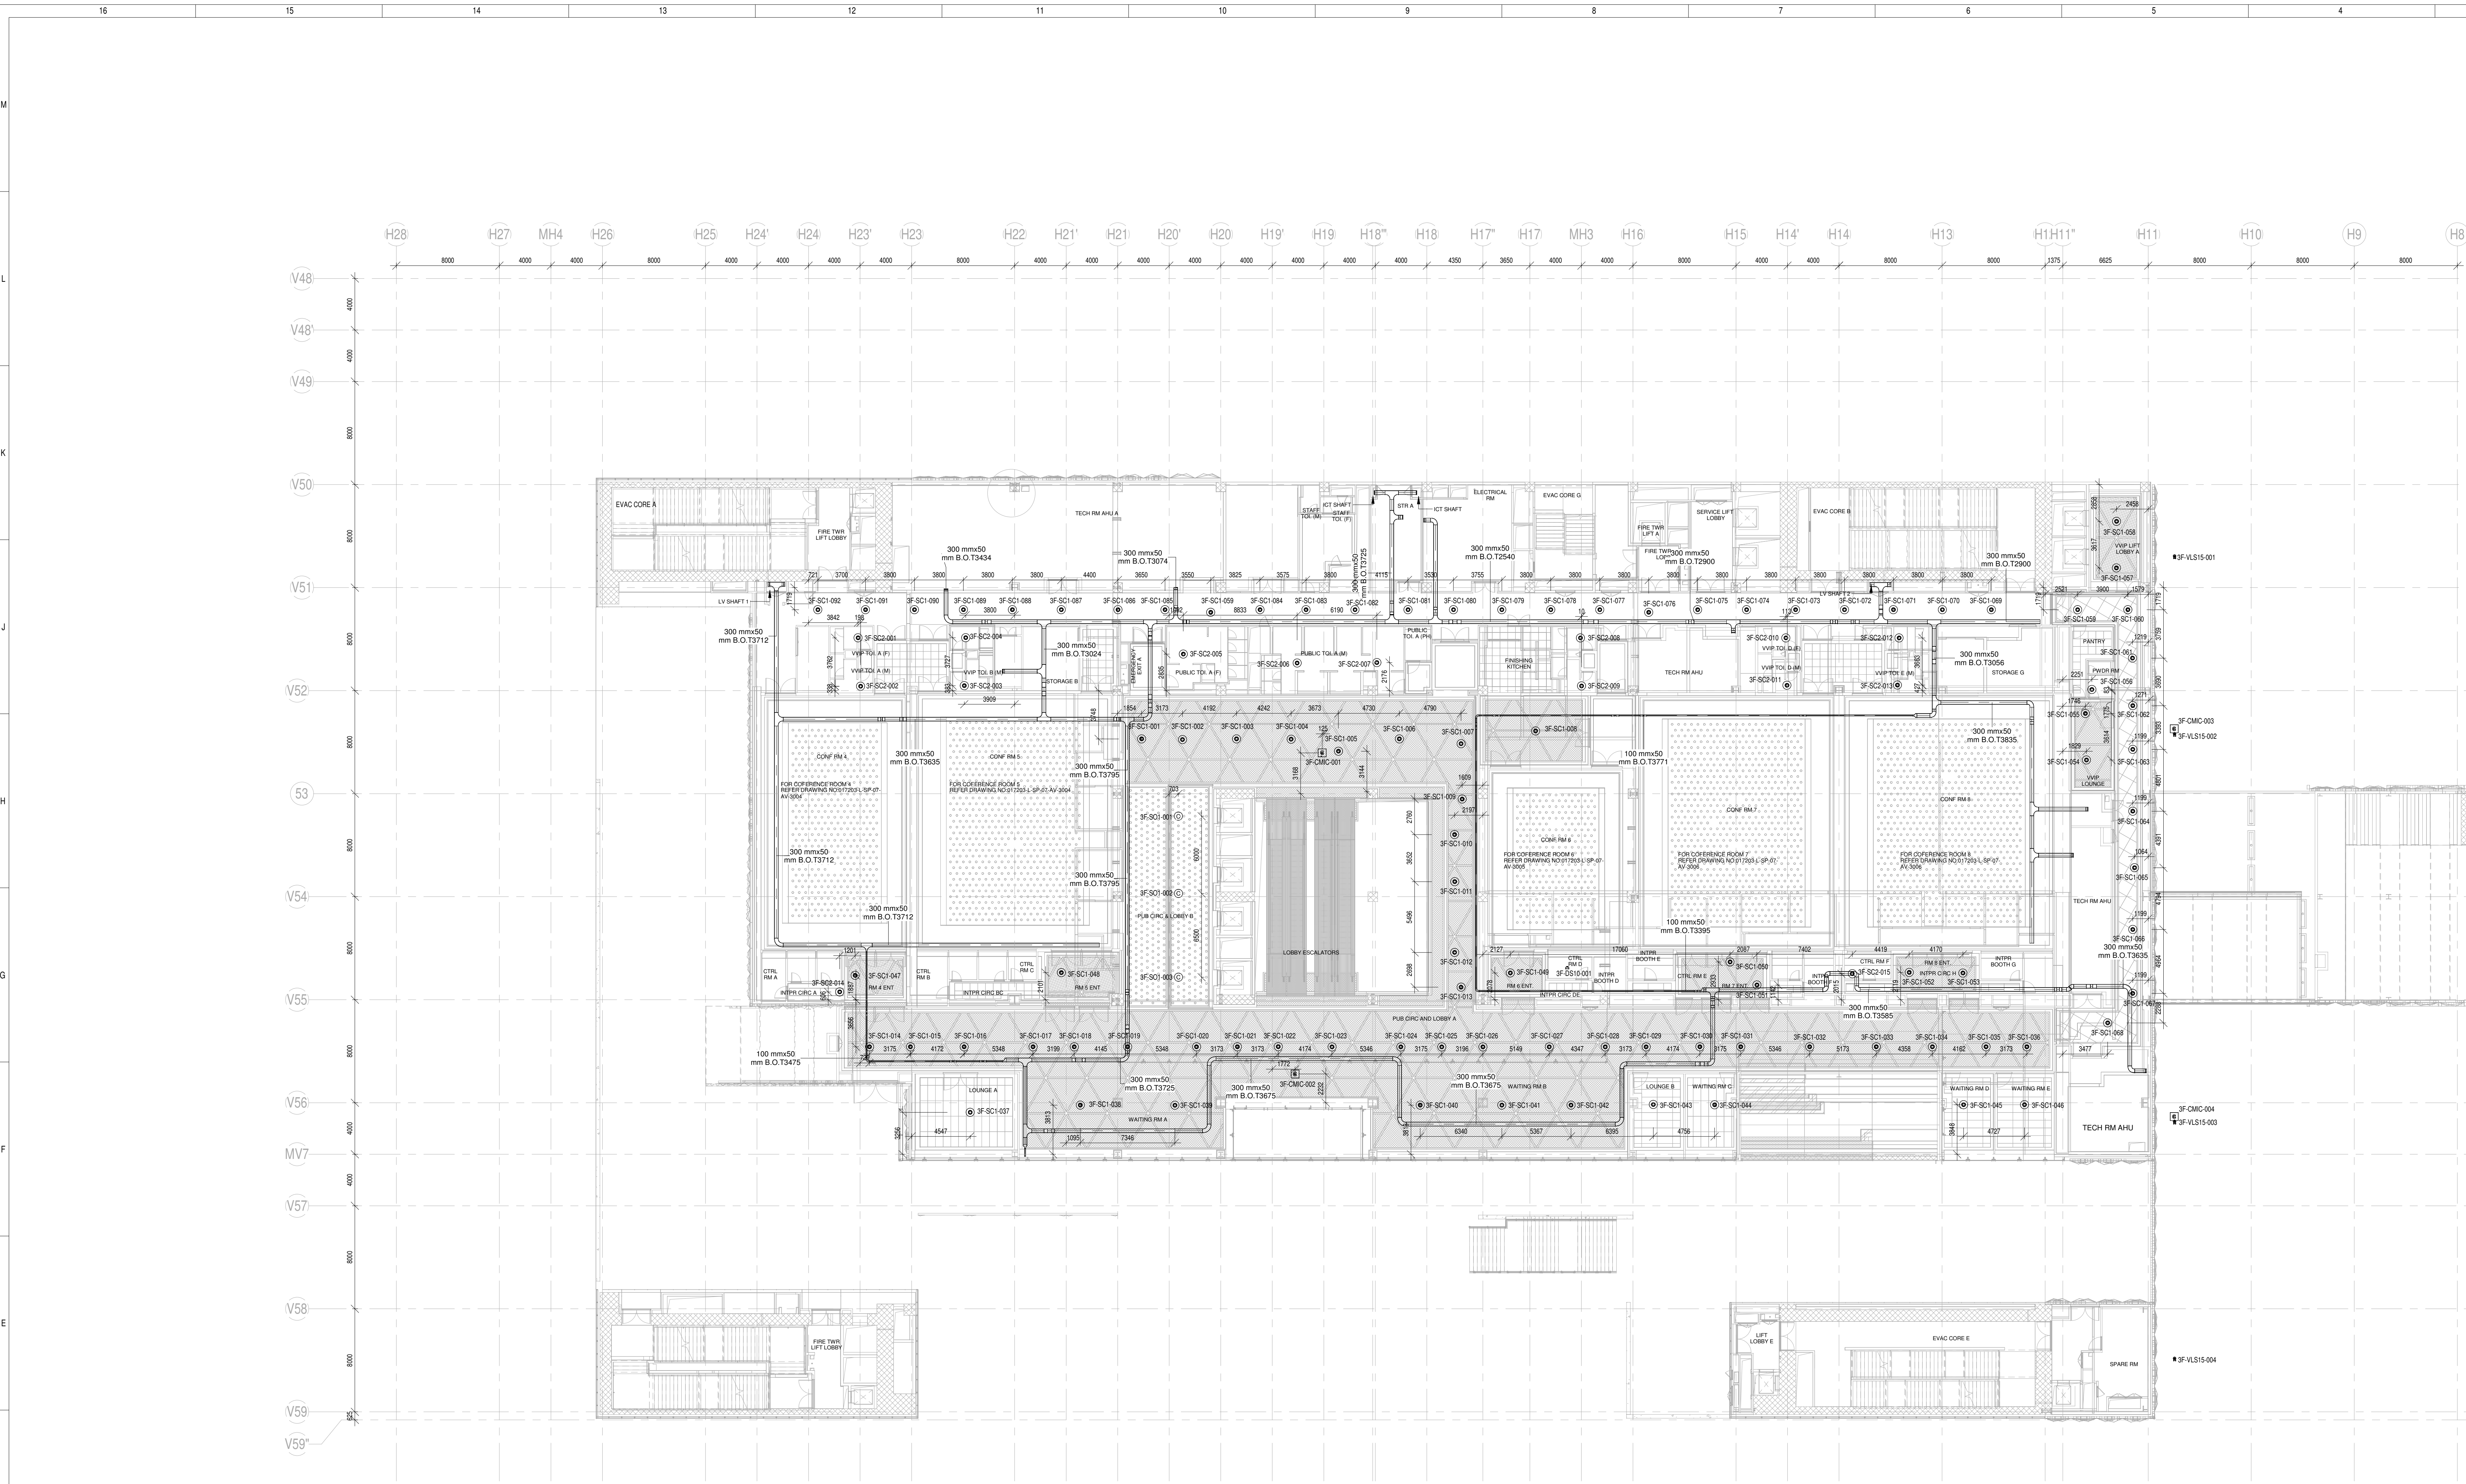

1 CC_F3_BGM PLAN LAYOUT
3056/ 1 : 200

- NOTES**
- GENERAL**
1. ALL DIMENSIONS ARE IN MILLIMETER UNLESS OTHERWISE SPECIFIED
 2. EXACT ROUTING SHALL BE DECIDED AT SITE IN CONSULTATION WITH ENGINEERING IN CHARGE TO SUIT SITE CONDITIONS
 3. PVC CONDUIT SHALL BE USED FOR EMBEDDED APPLICATION AND MS CONDUIT USED FOR OPEN APPLICATION
 4. CONDUITS SHALL BE CONCEALED IN WALL/CEILING IN NON-FALSE CEILING AREA
 5. SUSPENDED CONDUITS ARE TO BE USED IF MORE THAN 3 CONDUITS RUN IN PARALLEL
 6. CONDUITS SHOULD BE EQUIPPED WITH A PULL CORDS WITH SUITABLE TENSION POWER
 7. PULL BOXES WITH SUITABLE SIZE SHOULD BE PROVIDED IN ALL PVC CONDUIT SECTIONS THAT ARE CONTAINING MORE THAN TWO 90 DEGREE BENDS
 8. ALL DEVICES LOCATIONS AND ORIENTATION ARE INDICATIVE. EXACT LOCATION SHALL BE SHOWN IN THE CSM SHOP DRAWING
 9. THE EXACT CONDUIT/TRAY ROUTING SHALL BE DECIDED AT SITE IN CONSULTATION WITH THE ENGINEER IN CHARGE TO SUIT LEVEL AND SITE CONDITION
 10. A MINIMUM SEPARATION DISTANCE 30MM SHALL BE MAINTAINED BETWEEN ICT CABLEING
 11. THIS DRAWING IS ONLY INDICATIVE AND MAY VARY ACCORDING TO SITE CONDITION AND REQUIREMENT
 12. PATHWAYS (CABLE TRAY/RACEWAY CONDUITS)
 13. THE SHOWN BGM SPEAKERS LOCATIONS ARE INDICATIVE AND HEAT MAP ANALYSIS REPORT MUST BE GENERATED BY OEM/VENDOR AT SHOP DRAWING STAGE TO MAINTAIN UNIFORM SPL LEVEL OF 85 dba +/- 3 db HEADROOM

AUDIO EQUIPMENTS LEGEND						
SR.NO	SYMBOL	DEVICE ID	Tender Spec. No.	DESCRIPTION	MOUNTING HEIGHT	QTY.
1		SC2	96	4" Low Profile 2 way Ceiling SPK.	CEILING MOUNTED	15
2		SC1	94	High Profile 5" Ceiling SPK.	CEILING MOUNTED	92
3		CMIC	109	Noise Compensation Microphone	CEILING MOUNTED	4
4		SO1		Pendent Speaker	CEILING MOUNTED	3
5		DS10		PAGING STATION	DESK MOUNTED	01
6		VLS 15		PASSIVE COLOUMN ARRAY LOUD SPEAKER	2400 FROM FFL	04

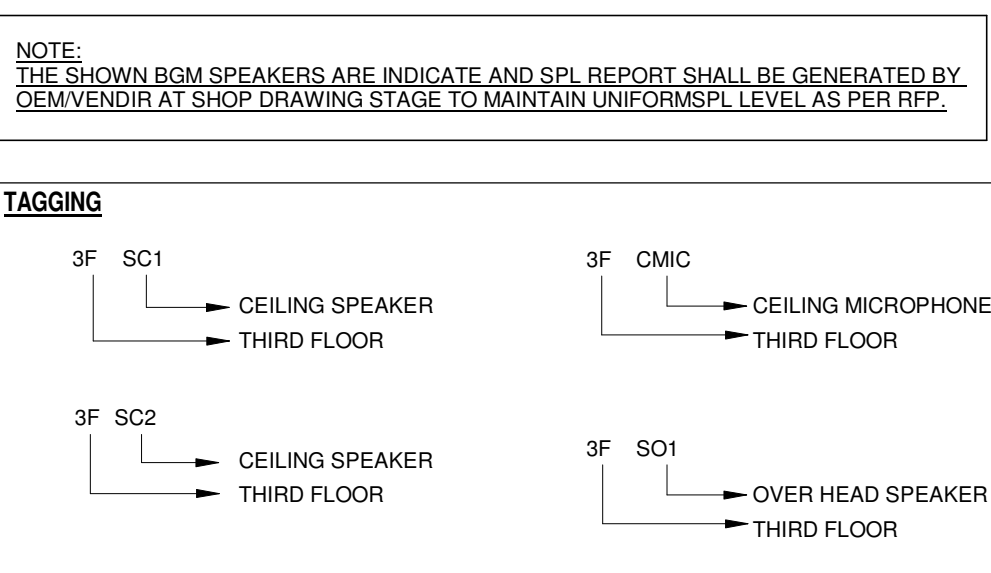

REFERENCE DRAWING

ARCHITECTURE
FLOOR PLANS APPROVED VIA TRANSMITTAL NO EDRC-8&F/017203/01346

STRUCTURE
017203-C-SP-07-NU-0007 - LAYOUT AND NUMERATION DETAIL OF LEVEL - F4 (+18.520M)

ELECTRICAL
017203-E-SP-07-LL-0046 - CONVENTION CENTER - THIRD FLOOR 3F - LIGHTING LAYOUTS
017203-E-SP-07-PL-0154 - CONVENTION CENTER - THIRD FLOOR 3F - POWER LAYOUTS
017203-E-SP-07-EE-0056 - CONVENTION CENTER - 3F - ELECTRICAL EQUIPMENT, CABLE TRAY & EARTHING LAYOUT - OVERALL PLAN


ELV
017203-L-SP-07-LV-1300 - CONVENTION CENTER - 3F - OVER ALL ELV SYSTEM LAYOUT

FPS
017203-F-SP-07-PL-0019 - CONVENTION CENTRE - 3F - OVER ALL PLAN LAYOUT OF WETTING CUM DOWNCOMER, AUTOMATIC SPRINKLER SYSTEM AND PORTABLE FIRST AID FIRE EXTINGUISHERS

FIRE
17203-F-SP-07-FA-0020 - CONVENTION CENTRE - 3F - OVER ALL PLAN LAYOUT OF INTEGRATED INTELLIGENT ADDRESSABLE FIRE DETECTION & ALARM SYSTEM AND PHOTOLUMINESCENT SAFETY SIGNAGES

HVAC
017203-V-SP-07-AC-0026 CONVENTION CENTRE THIRD FLOOR 3F - HVAC EQUIPMENT DUCTING AND PIPING LAYOUT

PHE
017203-U-SP-07-IP-0027 to 0030 - PLUMBING SYSTEM LAYOUT - THIRD FLOOR 3F - TOILET WATER SUPPLY LAYOUT

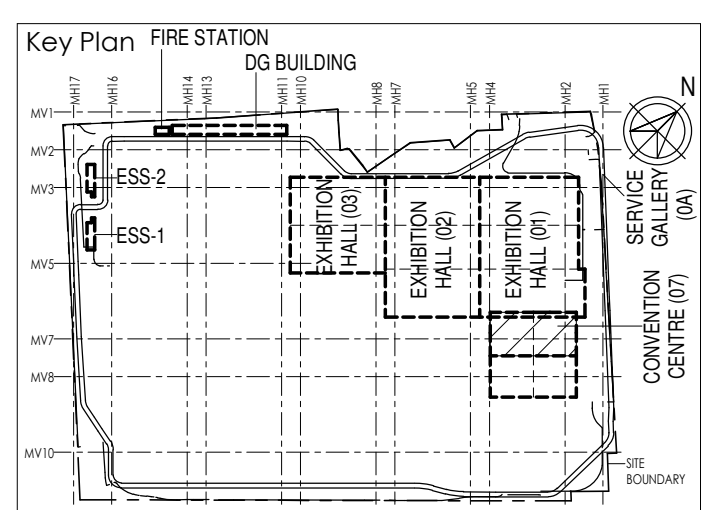

Owner / Employer

India International Convention & Exhibition Centre Limited
Room No. 424, Ministry of Commerce & Industry
DPP, Jayaprakash, New Delhi - 110011, India

Department of Industrial Policy and Promotion Ministry of Commerce & Industry Government of India

Knowledge Partner

Delhi Mumbai Industrial Corridor Development Corporation
Room No. 341 B, 3rd Floor, India Park, Diplomatic Enclave, 268 Chanayapuri, New Delhi - 110021

Employer's Representative

Programme Management Consultant (PMC)

AECOM

Preliminary Engineering Architecture Consultants (PEAC)

idom **CPKUREJA**
Av. Del Marqués de E. Borja, 4, No. 1, Ashraf Road Building, Green Park, 28049 Madrid, Spain New Delhi, Delhi 110016, India

EPC Contractor

L&T Construction
Building & Factories
Mount Poonamallee Road, Monroopolis, P.O. Box 197, Chennai - 600 089

EPC Contractor's Representatives

Design Consultant
Engineering Design and Research Center (EDRC)
L&T Construction - Buildings & Factories

Architectural Consultant
ARCO
Arcop Associates Pvt. Ltd., A-13, Park Road, Sector 16, New Delhi, Delhi 110048, India

Structural Proof Consultant
Indian Institute of Technology (IIT) Madras
Sankar Patel Rd, Opposite to C.I.L. Apsara, Chennai, Tamil Nadu 600036

MEP Proof Consultant
Egis India Consulting Engineers Pvt. Ltd.
Plot No. 44, Sector 12, Institutional Area, Opp. Zenith Solutions, Gurgaon, Haryana 122001

ICT Proof Consultant
CR Consulting Engineers Pvt. Ltd.
K471, 3rd Floor, Hazratganj Arcade, Subodhganj Road, Nehruplace Circle, Bhopal, Madhya Pradesh - 462004

Certification

EPC Contractor

Design Consultant

Architectural Consultant

Proof Consultant

Structure	MEP	ICT

PEAC

Issued by:
Inspector / Inspector's Engineer

NO	ISSUED AS GOOD-FOR CONSTRUCTION	07.03.20	BY	SS	MSK	GNR
REV	DESCRIPTION	DATE	DSGN	DRWN	CHKD	APPD

Revisions

ARCHITECTURE	FPS				
STRUCTURAL	PEAC				
ELECTRICAL	MSK				
ELV SYSTEM	SS				
HVAC	GEORCH				

CHECKED BY: SIGN DATE CHECKED BY: SIGN DATE

EPC Contractor

L&T Construction
Building & Factories

JOB No : 017203

Project Name
DESIGN AND CONSTRUCTION OF INDIA INTERNATIONAL CONVENTIONAL & EXPO CENTRE SECTOR 25, DOWARKA, NEW DELHI, INDIA

Drawing Status
GOOD FOR CONSTRUCTION (GFC)

Drawing No
L 07 3056 R0

Rev. No

Title :
CONVENTION CENTER-THIRD FLOOR BACKGROUND MUSIC LAYOUT


EDRC DWG No :
017203-L-SP-07-PA-3056

Scale
AS INDICATED


Sheet Size
A0

017203-L-SP-07-3056 (THIRD FLOOR BGM PLAN LAYOUT)

This drawing is the property of L&T Construction. All EDRCs and drawings are to be submitted to the Employer for approval. No part of this drawing is to be reproduced or transmitted in any form or by any means electronic or mechanical, including photocopying, recording, or by any information storage or retrieval system, without prior permission in writing from L&T Construction.

 


NOTE:
THE SHOWN BQM SPEAKERS ARE INDICATE AND SPL REPORT SHALL BE GENERATED BY
QEM/VENDOR AT SHOP DRAWING STAGE TO MAINTAIN UNIFORMSPL LEVEL AS PER RFP.

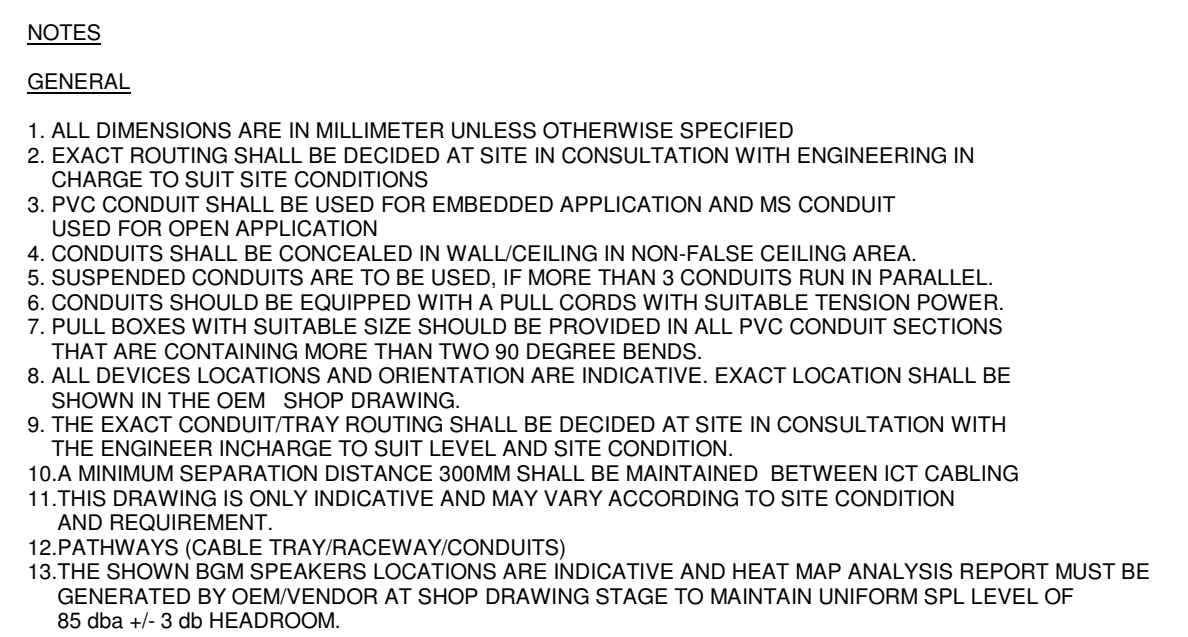[illegible]

Title : CONVENTION CENTER-FOURTH FLOOR
BACKGROUND MUSIC LAYOUT

EDRC DWG No : O17203-L-SP-07-PA-3057	Scale	Sheet Size
	AS INDICATED	A0

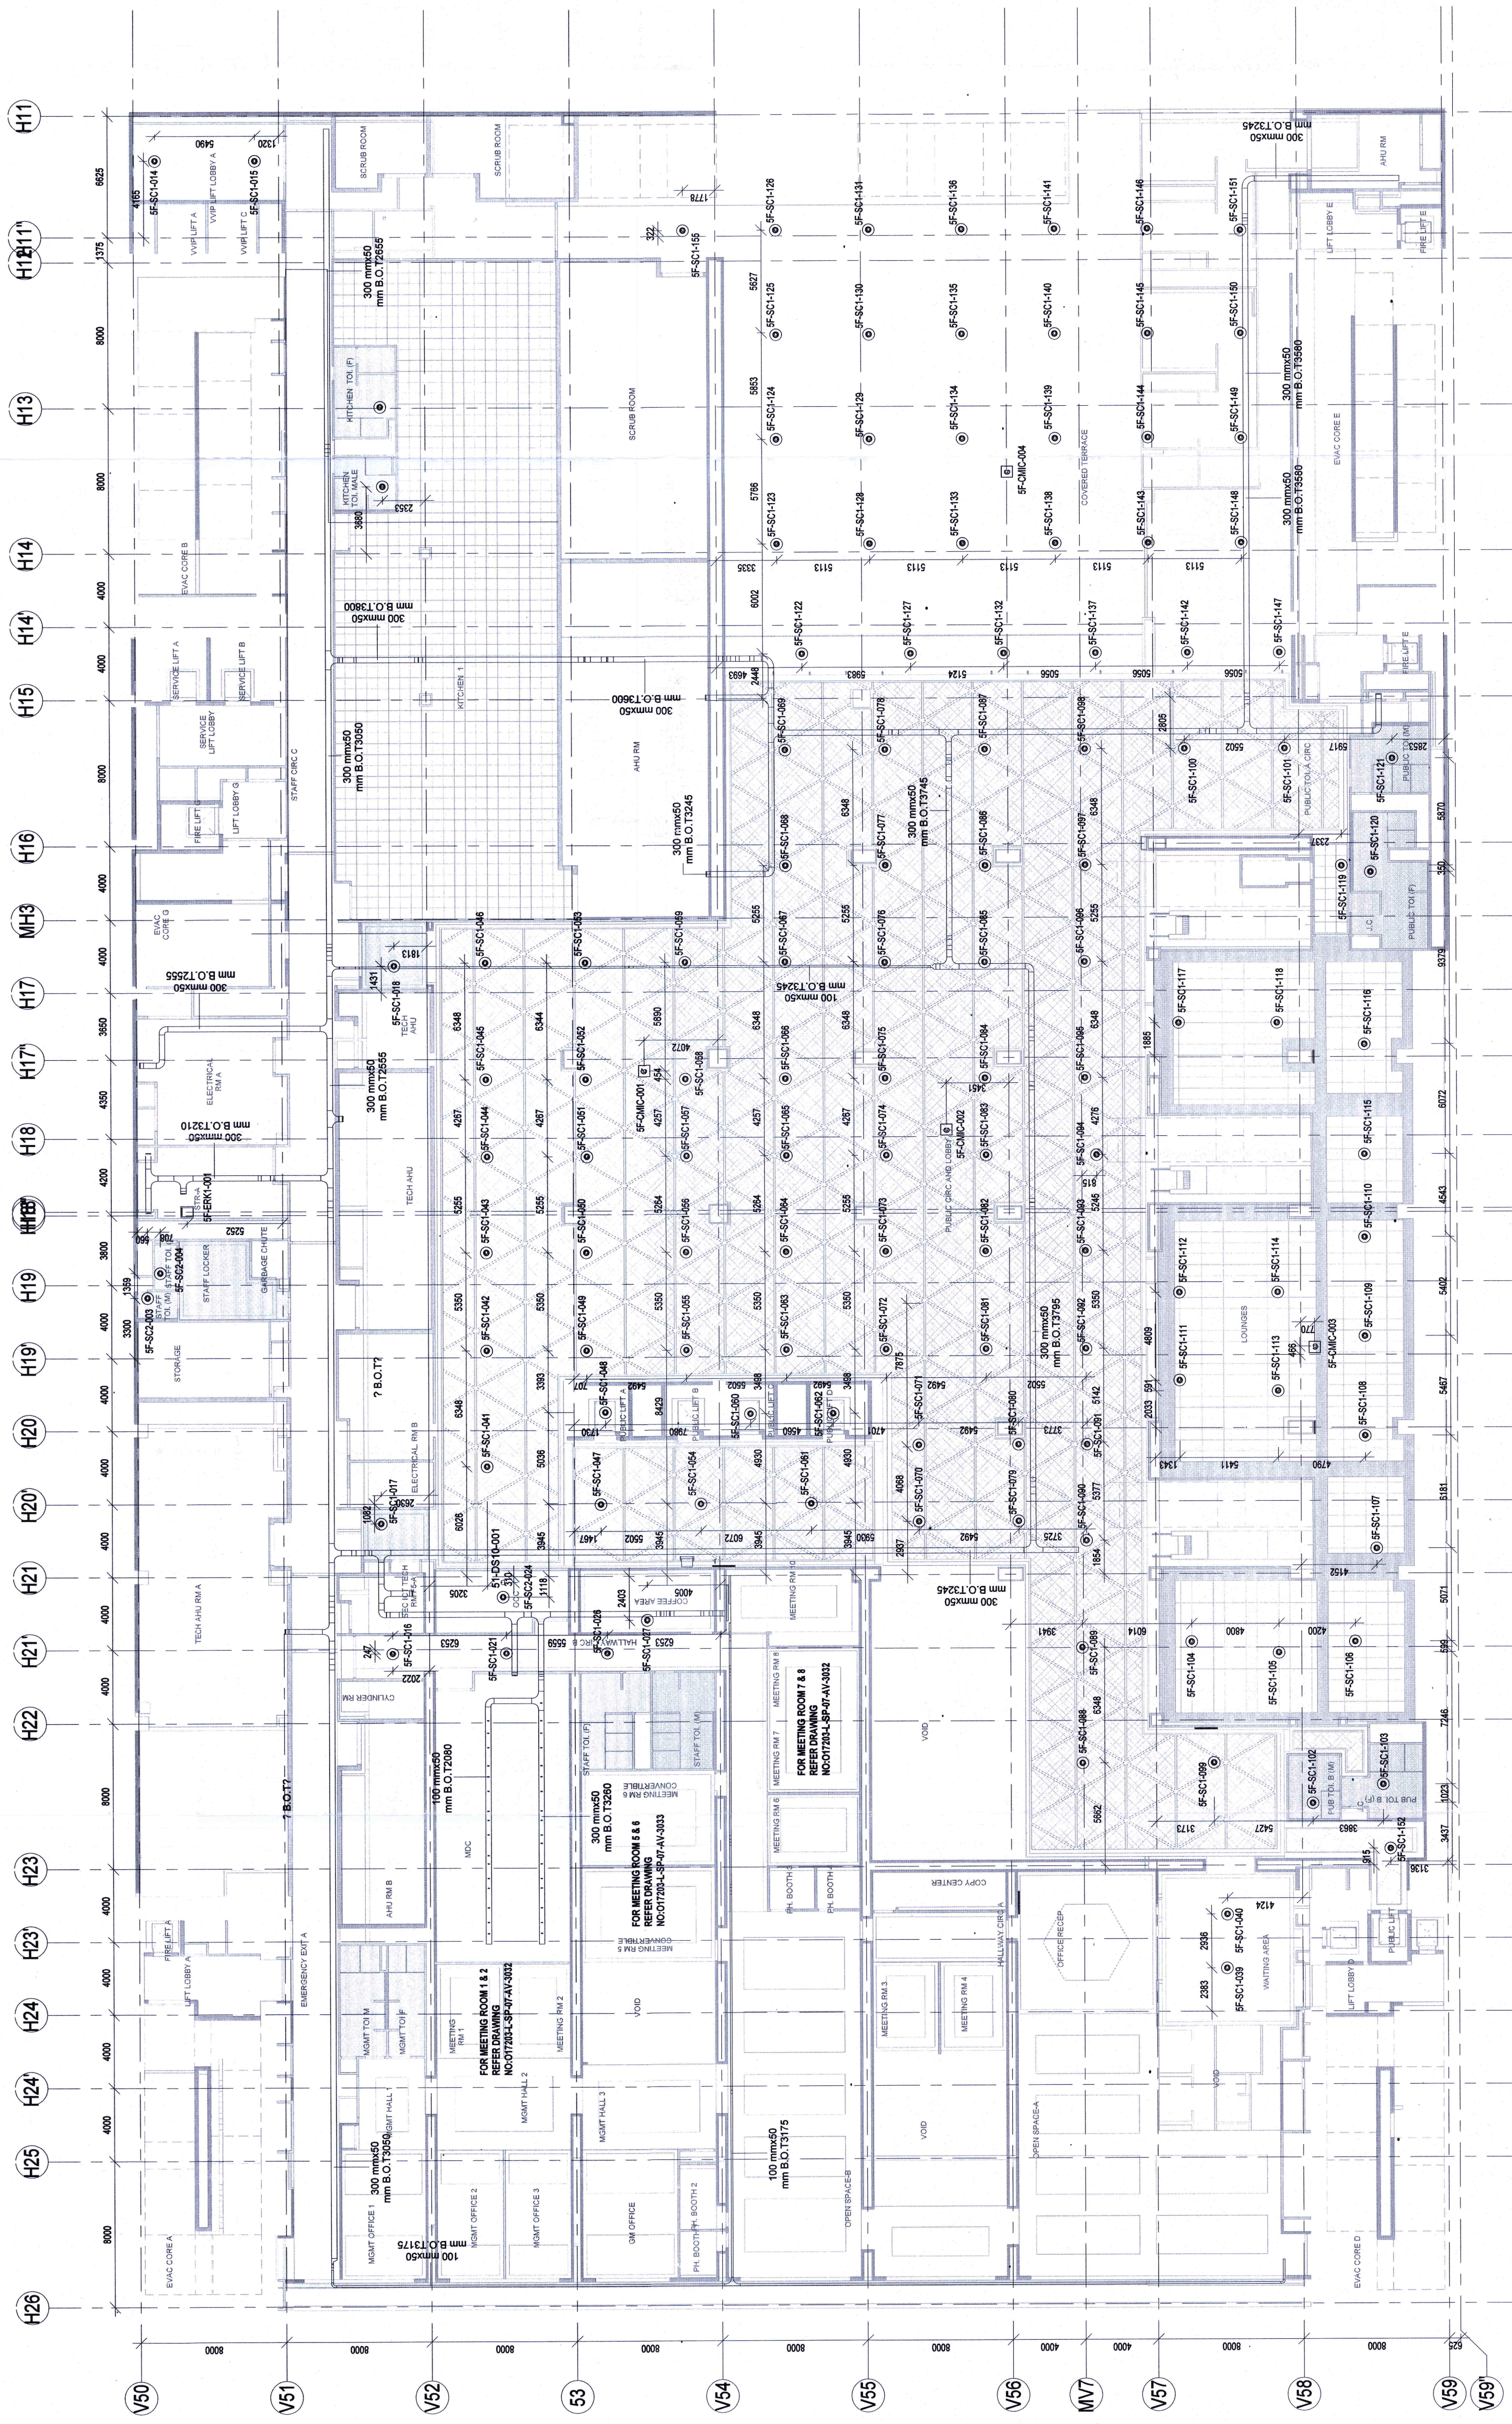

1 CC F5_BGM PLAN LAYOUT
3058 1:200

AUDIO EQUIPMENT'S LEGEND			QTY.
S/N	SYMBOL/DEVICE	DESCRIPTION	MOUNTING HEIGHT
1		4" Low Profile 2 way Ceiling SPK.	CEILING MOUNTED
2		High Profile 5" Ceiling SPK.	CEILING MOUNTED
3		Noise Compensation Microphone	CEILING MOUNTED
4		EQUIPMENT RACK	FLOOR MOUNTED
5		PAGING STATION	DESK MOUNTED

TAGGING

CC 5F S01 → CEILING SPEAKER
→ 4TH FLOOR
→ CONVENTION CENTER

CC 5F S02 → CEILING SPEAKER
→ 5TH FLOOR
→ CONVENTION CENTER

CC 5F CMC → CEILING MICROPHONE
→ CONVENTION CENTER


NOTE:
THE SHOWN BGM SPEAKERS ARE INDICATE AND SPL REPORT SHALL BE GENERATED BY
CONVENOR AT SHOP DRAWING STAGE TO MAINTAIN UNIFORM SPL LEVEL AS PER RFP.

NOTES

- [illegible]

REFERENCE DRAWING

- [illegible]

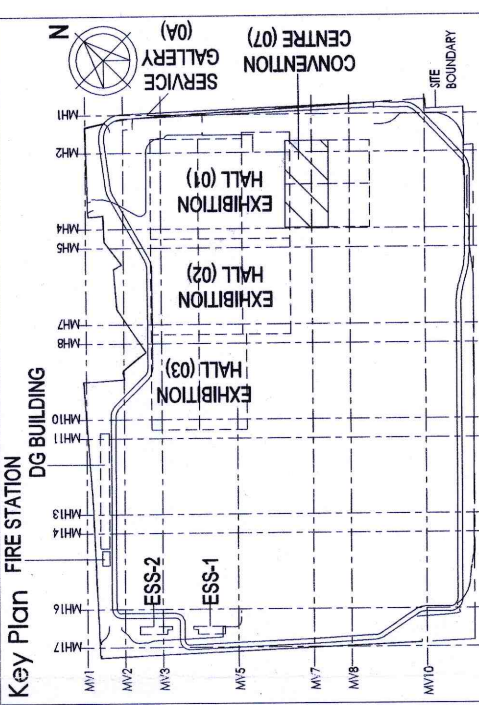[illegible]

Project Name
DESIGN AND CONSTRUCTION OF INDIA
INTERNATIONAL CONVENTIONAL & EXPO CENTRE
SECTOR 25, DWARKA, NEW DELHI, INDIA


GOOD FOR CONSTRUCTION (GFC)

L	07	3058	R0
---	----	------	----

Title: _____

CONVENTION CENTER-FIFTH FLOOR BACKGROUND MUSIC LAYOUT

EDRC DWG No : Q17203-L-SP-07-PA-3058	Scale AS INDICATED	Sheet Size A0
---	-----------------------	------------------

 

TAGGING

The diagram illustrates the tag locations for three different areas. For CC 7F SC1, tags are located on the ceiling speaker, seventh floor, and convention center. For CC 7F SC2, tags are located on the ceiling speaker, seventh floor, and convention center. For CC 7F ERK, tags are located on the equipment rack, seventh floor, and convention center.

CC 7F SC1

- CEILING SPEAKER
- SEVENTH FLOOR
- CONVENTION CENTER

CC 7F SC2

- CEILING SPEAKER
- SEVENTH FLOOR
- CONVENTION CENTER

CC 7F ERK

- EQUIPMENT RACK
- SEVENTH FLOOR
- CONVENTION CENTER

NOTE:
THE SHOWN BGM SPEAKERS ARE INDICATE AND SPL REPORT SHALL BE GENERATED BY
OEM/VENDIR AT SHOP DRAWING STAGE TO MAINTAIN UNIFORMSPL LEVEL AS PER RFP.

GENERAL

1. ALL DIMENSIONS ARE IN MILLIMETER UNLESS OTHERWISE SPECIFIED
2. EXACT ROUTING SHALL BE DECIDED AT SITE IN CONSULTATION WITH ENGINEERING IN CHARGE TO SUIT SITE CONDITIONS
3. PVC CONDUIT SHALL BE USED FOR EMBEDDED APPLICATION AND MS CONDUIT SHALL BE USED FOR OPEN APPLICATION
4. CONDUITS SHALL BE CONCEALED IN WALL/CILING IN NON-FALSE CEILING AREA
5. SUSPENDED CONDUIT SHALL BE USED IN MORE THAN 3 CONDUITS/RUN IN PANEL
6. CONDUITS SHOULD BE EQUIPPED WITH A PULL CORUS WITH SUITABLE TENSION POWER
7. PULL BODIES WITH SUITABLE SIZE SHOULD BE PROVIDED IN ALL PVC CONDUIT SECTIONS
8. ALL CONDUITS SHALL BE MARKED WITH IDENTIFICATION TAGS
9. ALL DEVICES LOCATIONS AND ORIENTATION ARE INDICATIVE. EXACT LOCATION SHALL BE AS PER THE DRAWING
10. THE EXACT CONDUIT/RATING ROUTING SHALL BE DECIDED AT SITE IN CONSULTATION WITH THE ENGINEER INCHARGE TO SUIT LEVEL AND SITE CONDITION
11. THE ROUTING SHALL BE IN ACCORDANCE WITH THE STANDARD BETWEEN ICT CABLEING AND TELECOM
12. THIS DRAWING IS ONLY INDICATIVE AND MAY VARY ACCORDING TO SITE CONDITION AND REQUIREMENT
13. PATHWAYS: (CABLE TRAY/CHANNELS)

REFERENCE DRAWING

ARCHITECTURE
FLOOR PLANS APPROVED VIA TRANSMITTAL NO EDRC-B&F/O17203/01346

STRUCTURE
017203-C-SP-07-NU-0007 - LAYOUT AND NUMERATION DETAIL OF LEVEL - F4 (+18.520M)


ELECTRICAL
017203-E-SP-07-LL-0048 - CONVENTION CENTER - THIRD FLOOR 3F - LIGHTING LAYOUTS
017203-E-SP-07-PL-0154 - CONVENTION CENTER - THIRD FLOOR 3F - POWER LAYOUTS
017203-E-SP-07-EE-0258 -CONVENTION CENTER -3F- ELECTRICAL EQUIPMENT, CABLE TRAY & EARTHIN LAYOUT - OVERALL PLAN

ELV
017203-L-SP-07-LV-1700 - CONVENTION CENTER -7F- OVER ALL ELV SYSTEM LAYOUT

FFS
017203-F-SP-07-PL-0019 -CONVENTION CENTRE - 3F - OVER ALL PLAN: LAYOUT OF WETRISER CUM DOWNCOMER,
AUTOMATIC SPRINKLER SYSTEM AND PORTABLE FIRST-AID FIRE EXTINGUISHERS
17203-F-SP-07-FA-0020 - CONVENTION CENTRE - 3F- OVER ALL PLAN: LAYOUT OF INTEGRATED INTELLIGENT ADDRESS
FIRE DETECTION & ALARM SYSTEM AND PHOTOLUMINESCENT SAFETY SIGNAGES

HVAC
017203-V-SP-07-AC-0026 CONVENTION CENTRE THIRD FLOOR 3F - HVAC EQUIPMENT DUCTING AND PIPING LAYOUT

PHE
017203-U-SP-07-IP-0070 to 0073 - PLUMBING SYSTEM LAYOUT -THIRD FLOOR 3F- TOILET WATER SUPPLY LAYOUT

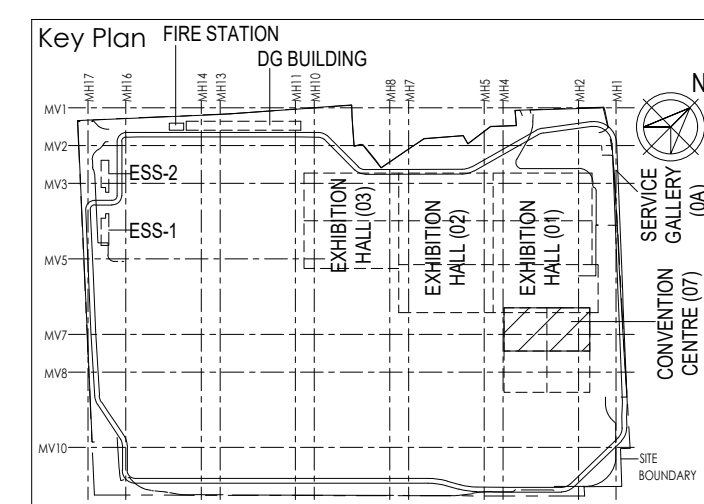

RO	ISSUED AS GOOD FOR CONSTRUCTION					
REV	DESCRIPTION	DATE	DSCN	DRWN	CHKD	APPR
Revisions						
ARCHITECTURE			PPS			
STRUCTURAL			PIPPING			
ELECTRICAL			PHE			
ELV SYSTEM			G/S			
HVAC			GEOTECH.			
CHECKED BY	SIGN	DATE	CHECKED BY	SIGN	DATE	

EPC Contractor



JOB No : O17203

Project Name
DESIGN AND CONSTRUCTION OF INDIA
INTERNATIONAL CONVENTIONAL & EXPO CENTRE
SECTOR 25,DWARKA,NEW DELHI,INDIA

GOOD FOR CONSTRUCTION (GFC)

Drawing No			Rev. No
L	07	3060	R0


Title

CONVENTION CENTER-SEVENTH FLOOR
BACKGROUND MUSIC LAYOUT


EDRC DWG No :

Scale	Sheet Size
-------	------------

01/200 L 31 07/17/2000

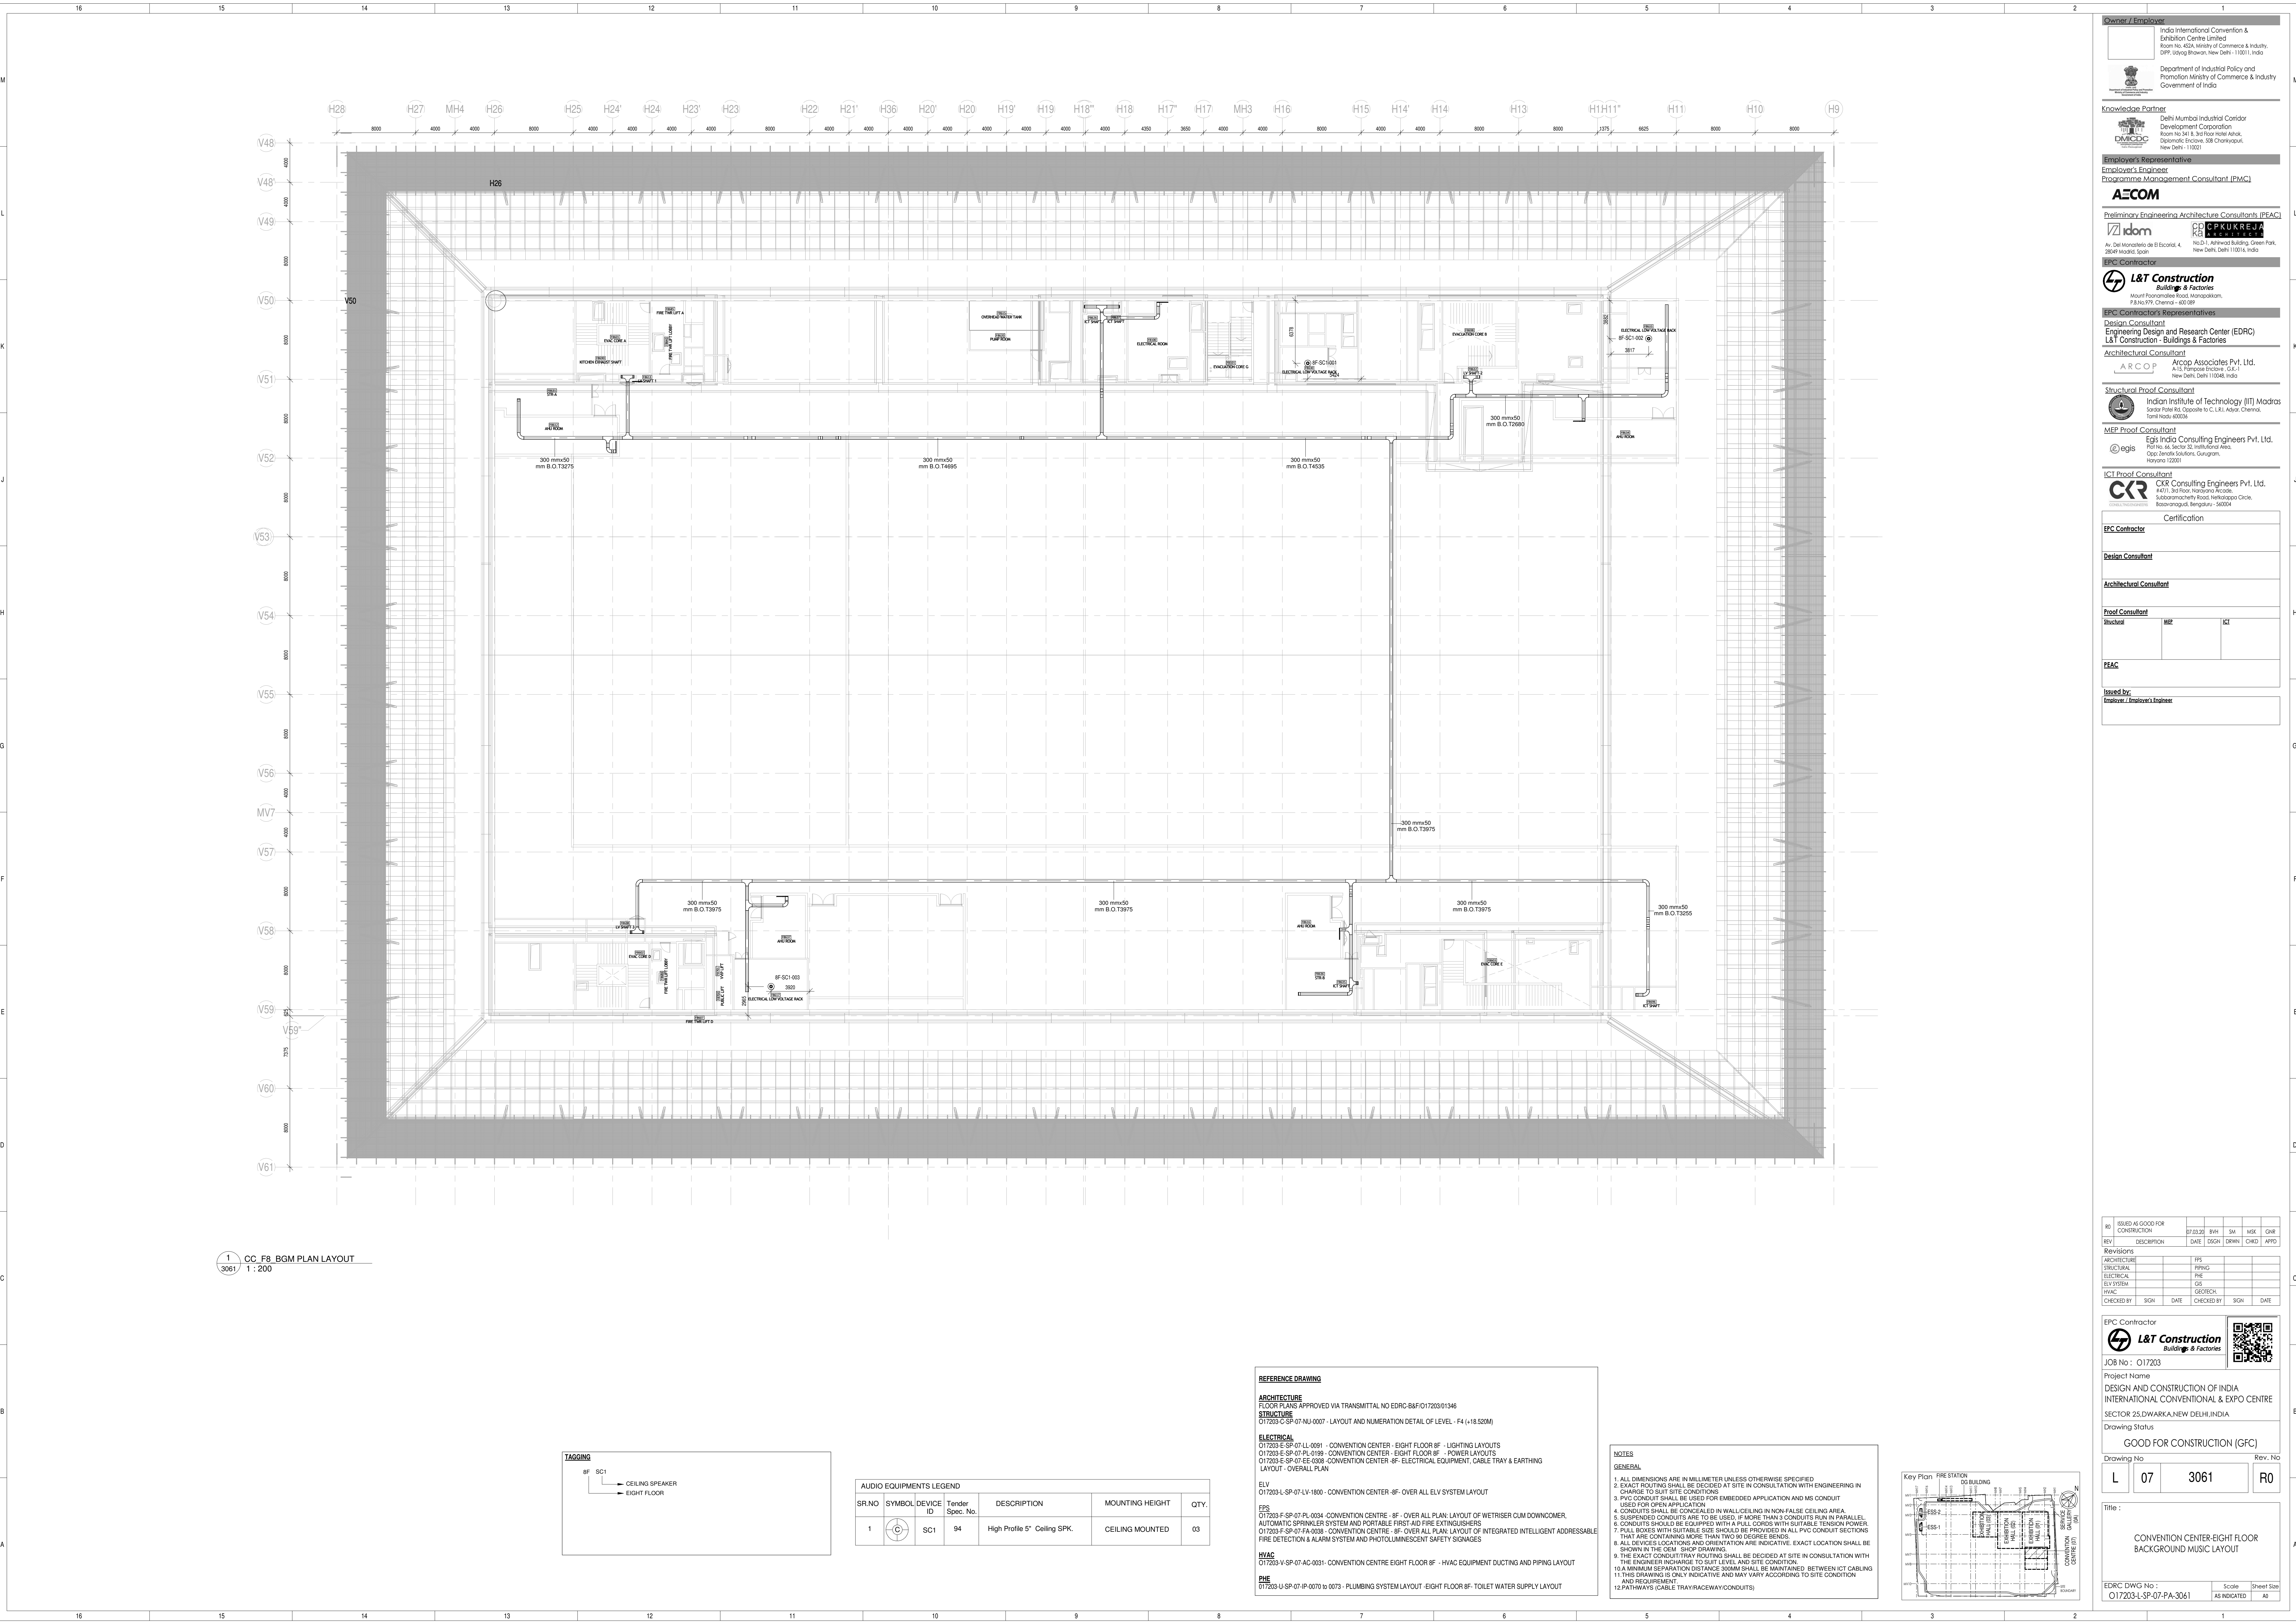

1 CC_F8_BGM PLAN LAYOUT
3061 1 : 200

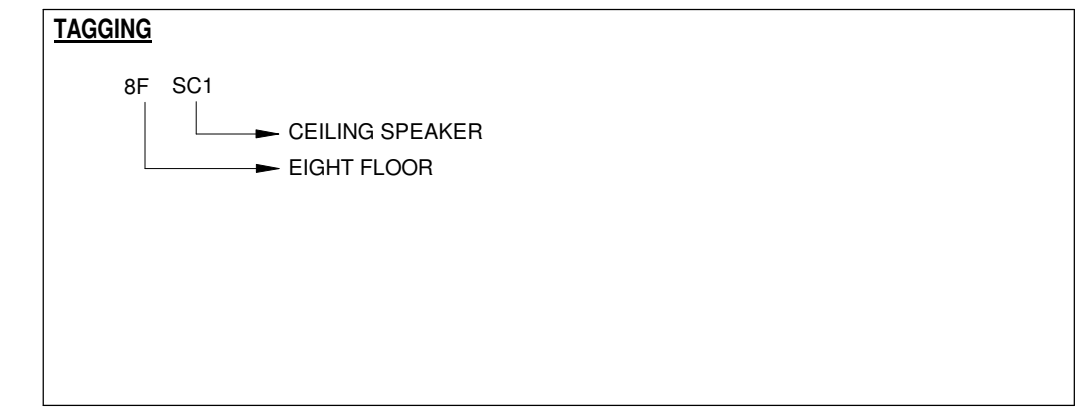

AUDIO EQUIPMENTS LEGEND						
SR.NO	SYMBOL	DEVICE ID	Tender Spec. No.	DESCRIPTION	MOUNTING HEIGHT	QTY.
1		SC1	94	High Profile 5" Ceiling SPK.	CEILING MOUNTED	03

REFERENCE DRAWING

ARCHITECTURE
FLOOR PLANS APPROVED VIA TRANSMITTAL NO EDRC-B&F/017203/01346

STRUCTURE
017203-C-SP-07-NJ-0007 - LAYOUT AND NUMERATION DETAIL OF LEVEL - F4 (-18.520M)

ELECTRICAL
017203-E-SP-07-LL-0091 - CONVENTION CENTER - EIGHT FLOOR 8F - LIGHTING LAYOUTS
017203-E-SP-07-PL-0198 - CONVENTION CENTER - EIGHT FLOOR 8F - POWER LAYOUTS
017203-E-SP-07-EE-0008 - CONVENTION CENTER - 8F - ELECTRICAL EQUIPMENT, CABLE TRAY & EARTHING LAYOUT - OVERALL PLAN


ELV
017203-L-SP-07-LV-1800 - CONVENTION CENTER - 8F - OVER ALL ELV SYSTEM LAYOUT

FPS
017203-F-SP-07-PL-0004 - CONVENTION CENTRE - 8F - OVER ALL PLAN LAYOUT OF WETRISE CUM DOWNCOMER, AUTOMATIC SPRINKLER SYSTEM AND PORTABLE FIRST-AID FIRE EXTINGUISHERS
017203-F-SP-07-FA-0038 - CONVENTION CENTRE - 8F - OVER ALL PLAN LAYOUT OF INTEGRATED INTELLIGENT ADDRESSABLE FIRE DETECTION & ALARM SYSTEM AND PHOTOLUMINESCENT SAFETY SIGNAGES

HVAC
017203-V-SP-07-AC-0031 - CONVENTION CENTRE EIGHT FLOOR 8F - HVAC EQUIPMENT DUCTING AND PIPING LAYOUT

PHE
017203-U-SP-07-IP-0070 to 0073 - PLUMBING SYSTEM LAYOUT -EIGHT FLOOR 8F- TOILET WATER SUPPLY LAYOUT

- NOTES**
- GENERAL**
- ALL DIMENSIONS ARE IN MILLIMETER UNLESS OTHERWISE SPECIFIED
 - EXACT ROUTING SHALL BE DECIDED AT SITE IN CONSULTATION WITH ENGINEERING IN CHARGE TO SUIT SITE CONDITIONS
 - PVC CONDUIT SHALL BE USED FOR EMBEDDED APPLICATION AND MS CONDUIT USED FOR OPEN APPLICATION
 - CONDUITS SHALL BE CONCEALED IN WALL/CEILING IN NON-FALSE CEILING AREA
 - SUSPENDED CONDUITS ARE TO BE USED IF MORE THAN 3 CONDUITS RUN IN PARALLEL
 - CONDUITS SHOULD BE EQUIPPED WITH A PULL CORDS WITH SUITABLE TENSION POWER
 - PULL BOXES WITH SUITABLE SIZE SHOULD BE PROVIDED IN ALL PVC CONDUIT SECTIONS THAT ARE CONTAINING MORE THAN TWO (2) DEGREE BENDS
 - ALL DEVICES LOCATIONS AND ORIENTATION ARE INDICATIVE. EXACT LOCATION SHALL BE SHOWN IN THE 2D/3D SHOP DRAWING
 - THE EXACT CONDUIT/TRAY ROUTING SHALL BE DECIDED AT SITE IN CONSULTATION WITH THE ENGINEER INCHARGE TO SUIT LEVEL AND SITE CONDITION
 - A MINIMUM SEPARATION DISTANCE 300MM SHALL BE MAINTAINED BETWEEN ICT CABLEING AND REQUIREMENT
 - 12 PATHWAYS CABLE TRAY/CEILING/CONDUITS

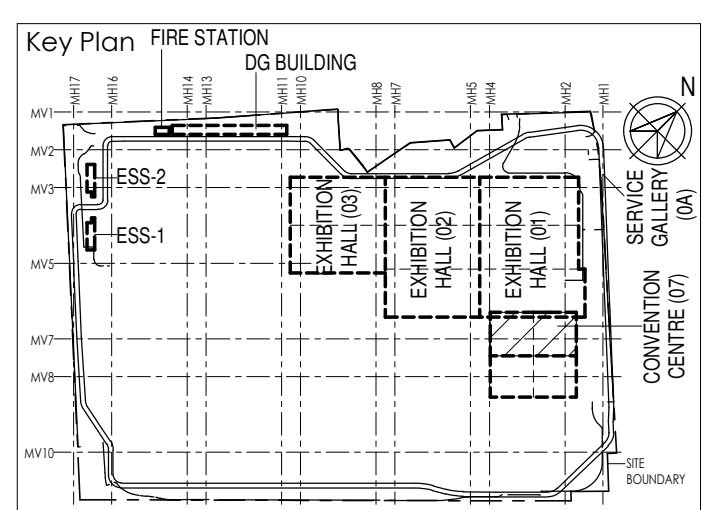

Owner / Employer

India International Convention & Exhibition Centre Limited
Room No. 424, Ministry of Commerce & Industry
DPP, Udyog Bhawan, New Delhi - 110011, India

Department of Industrial Policy and Promotion Ministry of Commerce & Industry Government of India

Knowledge Partner

Delhi Mumbai Industrial Corridor Development Corporation
Room No. 341 B, 3rd floor, India Habitat, Diplomatic Enclave, 268 Chanakyapuri, New Delhi - 110021

Employer's Representative

Employer's Engineer
Programme Management Consultant (PMC)

AECOM

Preliminary Engineering Architecture Consultants (PEAC)

Av. Del Marqués de E. E. 4, 28049 Madrid, Spain
No. 1, Ashwini Building, Green Park, New Delhi, Delhi 110016, India

EPC Contractor

L&T Construction
Building & Factories
Mount Poonamallee Road, Marapakkam, P.O. No. 179, Chennai - 600 089

EPC Contractor's Representatives

Design Consultant
Engineering Design and Research Center (EDRC)
L&T Construction - Buildings & Factories

Architectural Consultant

ARCO Associates Pvt. Ltd.
A-12, Preetam Building, Green Park, New Delhi, Delhi 110048, India

Structural Proof Consultant

Indian Institute of Technology (IIT) Madras
Sanjay Patel Rd, Opposite to C.I.L. Adyar, Chennai, Tamil Nadu 600036

MEP Proof Consultant

Egis India Consulting Engineers Pvt. Ltd.
Plot No. 44, Sector-12, Institutional Area, Opp. Zenith Solutions, Gurgaon, Haryana 122001

ICT Proof Consultant

CR Consulting Engineers Pvt. Ltd.
14/71, 3rd Floor, Hazratganj Arcade, Subodhchandra Road, Nehruplace Circle, Bosewadi, Bangalore - 560004

Certification

EPC Contractor

Design Consultant

Architectural Consultant

Proof Consultant

Structure	MEP	ICT

PEAC

Issued by:
Employer / Employer's Engineer

RD	ISSUED AS GOOD-FOR CONSTRUCTION	07.03.20	BH	SM	MSK	GNR
REV	DESCRIPTION	DATE	DSGN	DRWN	CHKD	APPD

Revisions

ARCHITECTURE	FPS
STRUCTURAL	PEAC
ELECTRICAL	GS
ELV SYSTEM	GS
HVAC	GEORCH

CHECKED BY	SIGN	DATE	CHECKED BY	SIGN	DATE

EPC Contractor

L&T Construction
Building & Factories

JOB No : 017203

Project Name
DESIGN AND CONSTRUCTION OF INDIA INTERNATIONAL CONVENTIONAL & EXPO CENTRE
SECTOR 25, DOWRIKA, NEW DELHI, INDIA

Drawing Status
GOOD FOR CONSTRUCTION (GFC)

Drawing No
L 07 3061 R0

Rev. No

Title :
CONVENTION CENTER-EIGHT FLOOR
BACKGROUND MUSIC LAYOUT


EDRC DWG No :
017203-L-SP-07-PA-3061

Scale
AS INDICATED

Sheet Size
A0

017203-L-SP-07-PA-3061 (P&B) PLAN LAYOUT

This drawing is the property of L&T Construction. All EDRCs and plans are not to be passed on to any person or body, or authorized by us to be used in any way without our prior permission in writing.

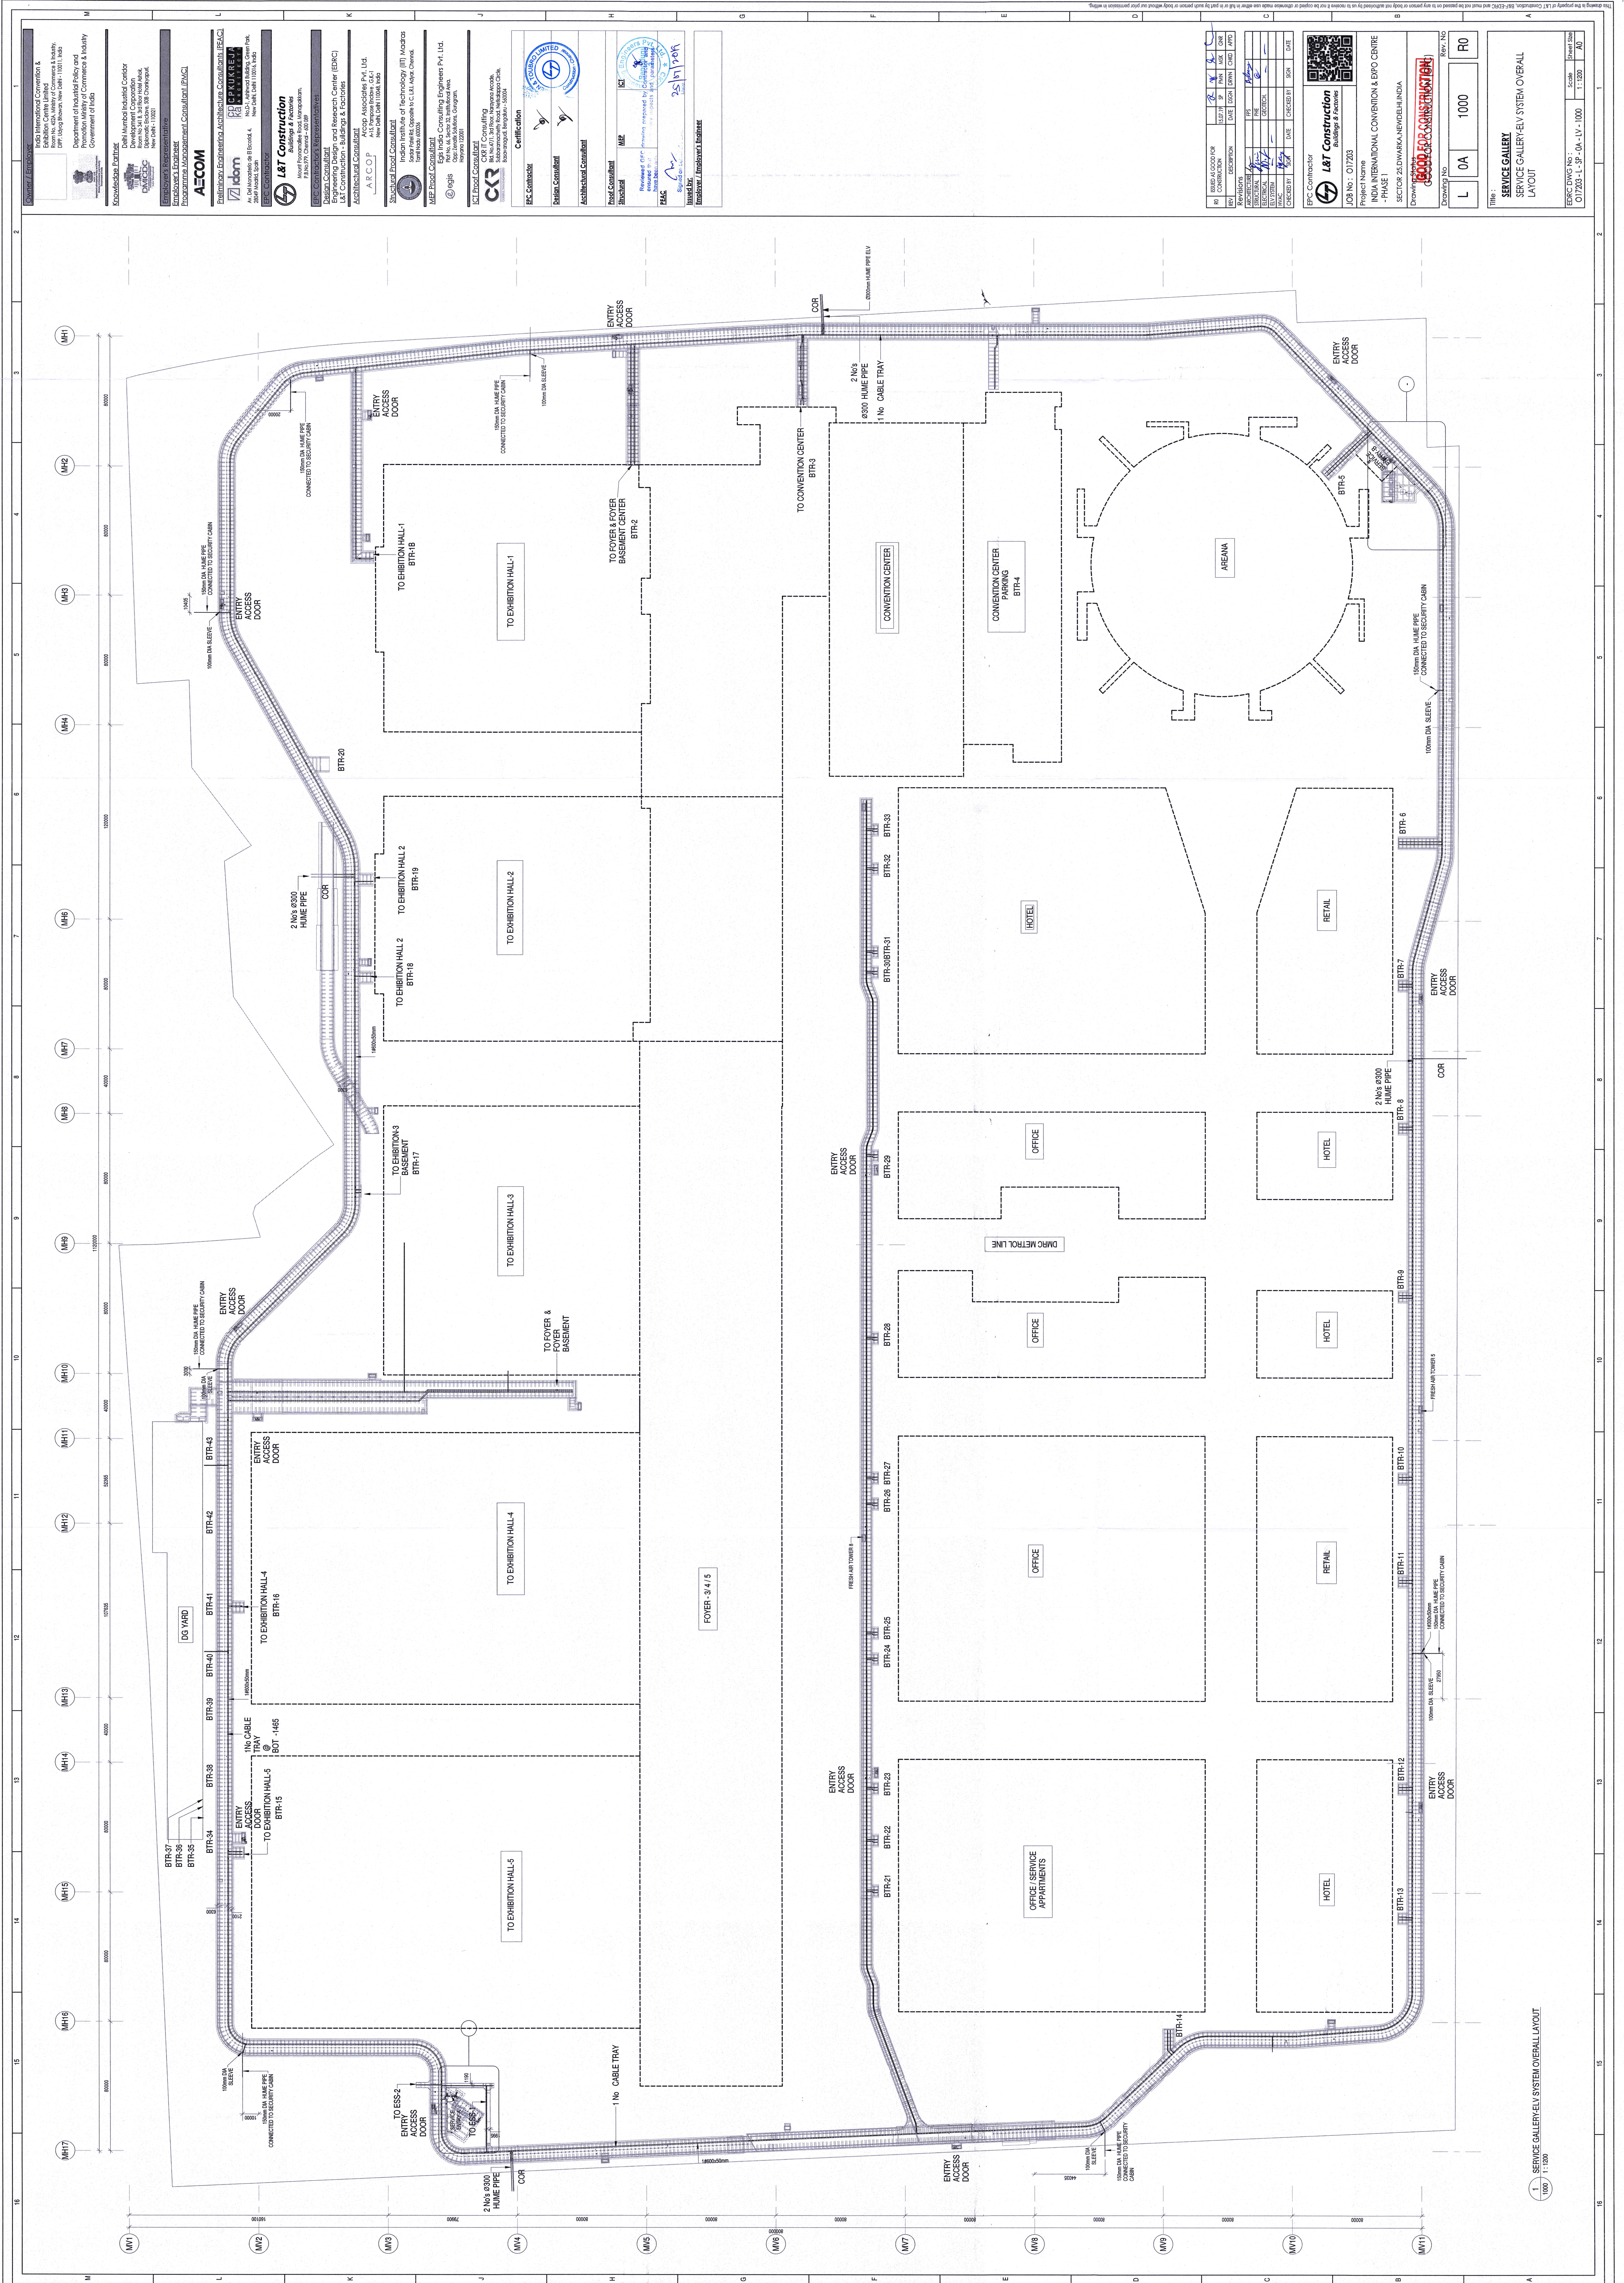

1 SERVICE GALLERY ELEV SYSTEM OVERALL LAYOUT

Client / Employer
Ministry of Commerce & Industry
Government of India

Project Name
India International Convention & Expo Centre
- PHASE I
SECTOR 25 DWARKA, NEW DELHI, INDIA

Drawn By
L&T Construction
Drawing No. 017283-L-3P-0A-UV-1000

Scale
1:1200

Sheet Size
A0

Revision

NO.	DESCRIPTION	DATE	BY	CHKD	APPD
1	ISSUED FOR PERMIT	25/07/2024	...	...	...
2	ISSUED FOR CONSTRUCTION	...	...	...	...

Approval

NO.	DESCRIPTION	DATE	BY	CHKD	APPD
1	ISSUED FOR PERMIT	25/07/2024	...	...	...
2	ISSUED FOR CONSTRUCTION	...	...	...	...

Project Details

Project Name
India International Convention & Expo Centre
- PHASE I
SECTOR 25 DWARKA, NEW DELHI, INDIA

Drawn By
L&T Construction
Drawing No. 017283-L-3P-0A-UV-1000

Scale
1:1200





Sheet Size
A0

Revision

NO.	DESCRIPTION	DATE	BY	CHKD	APPD
1	ISSUED FOR PERMIT	25/07/2024	...	...	...
2	ISSUED FOR CONSTRUCTION	...	...	...	...

Approval

NO.	DESCRIPTION	DATE	BY	CHKD	APPD
1	ISSUED FOR PERMIT	25/07/2024	...	...	...
2	ISSUED FOR CONSTRUCTION	...	...	...	...

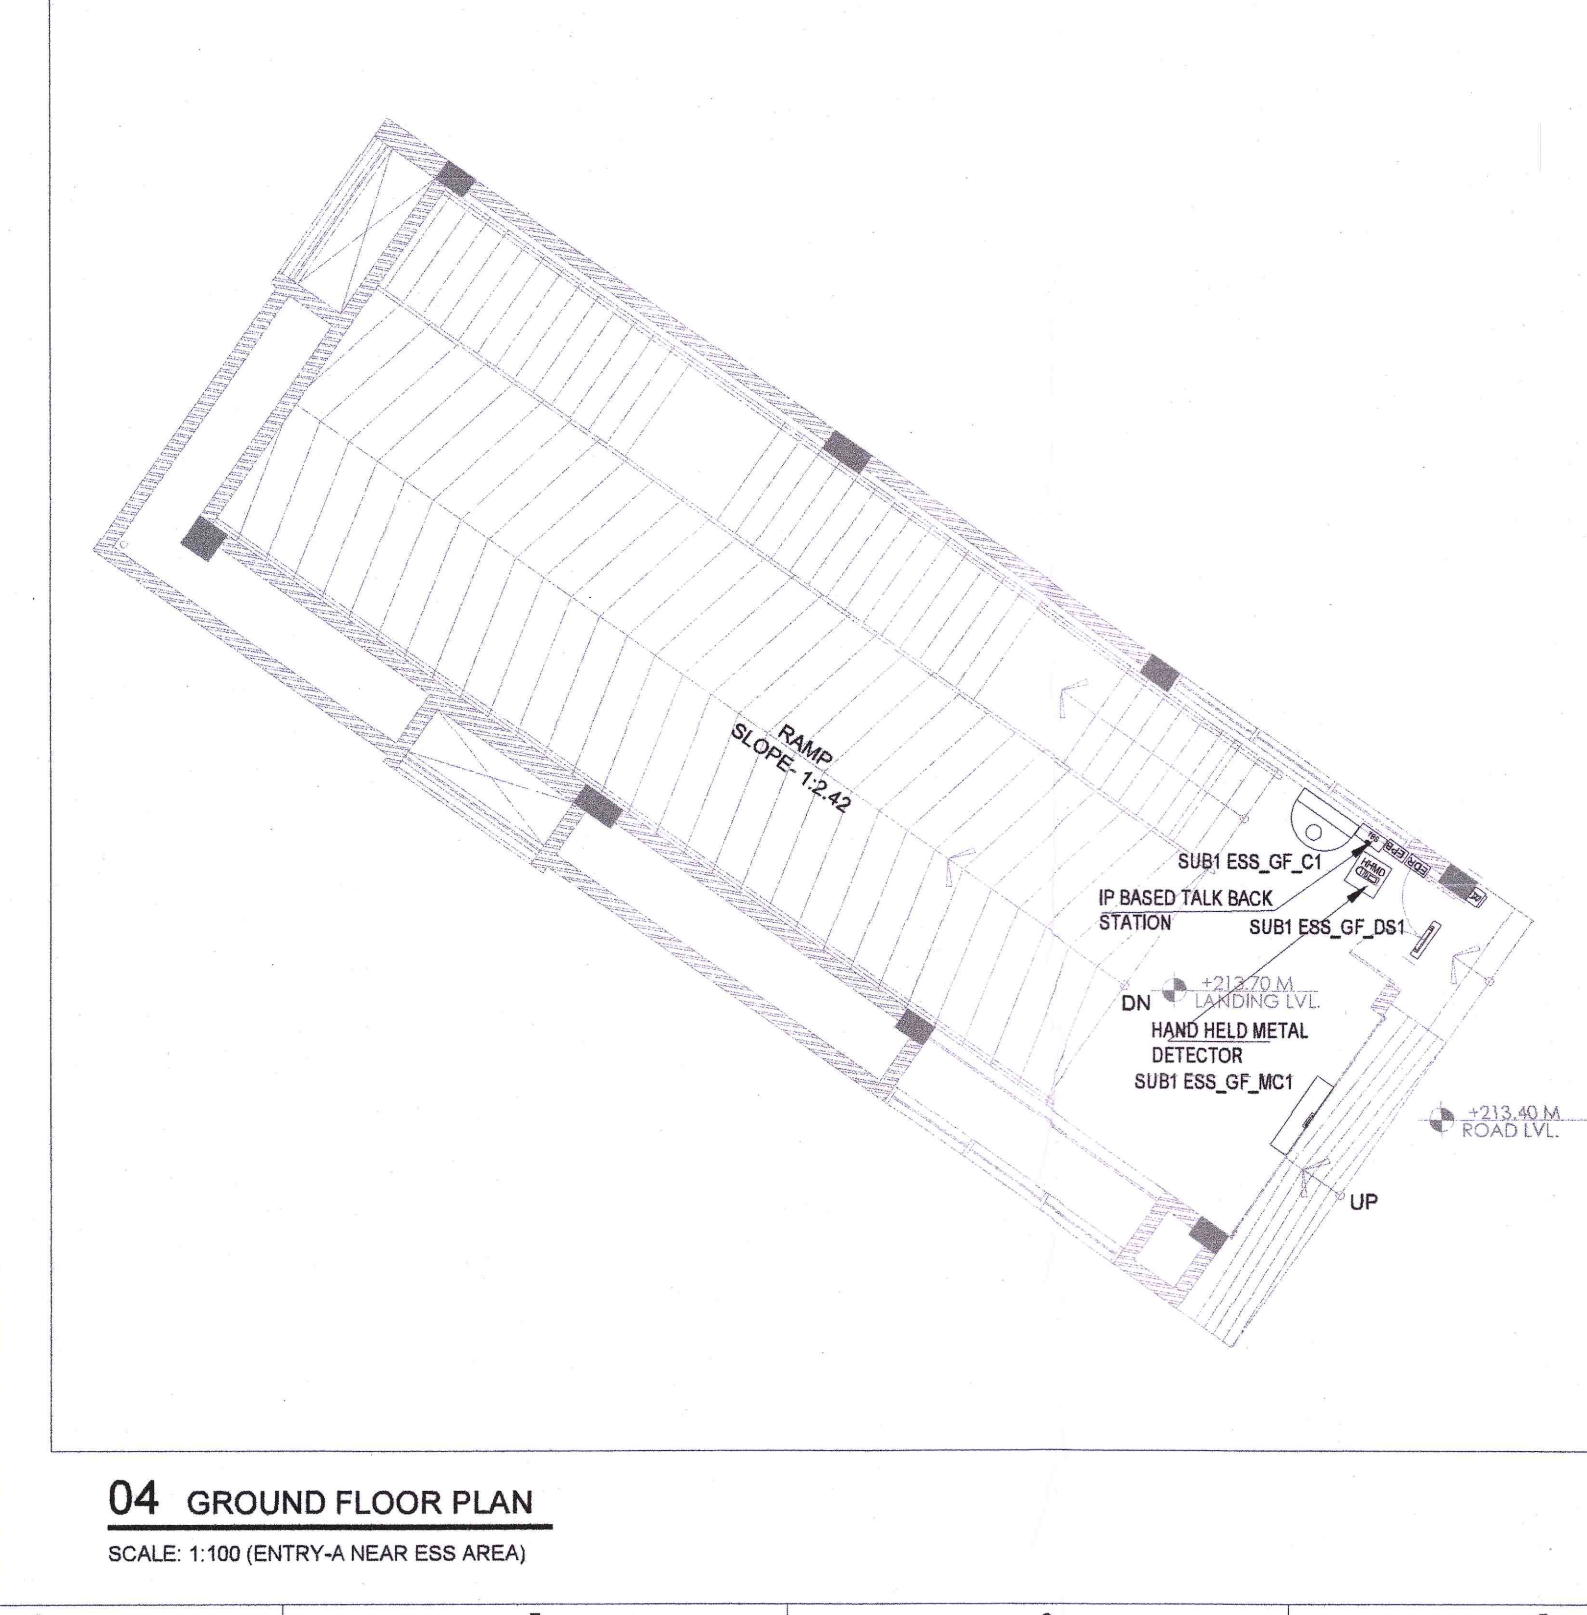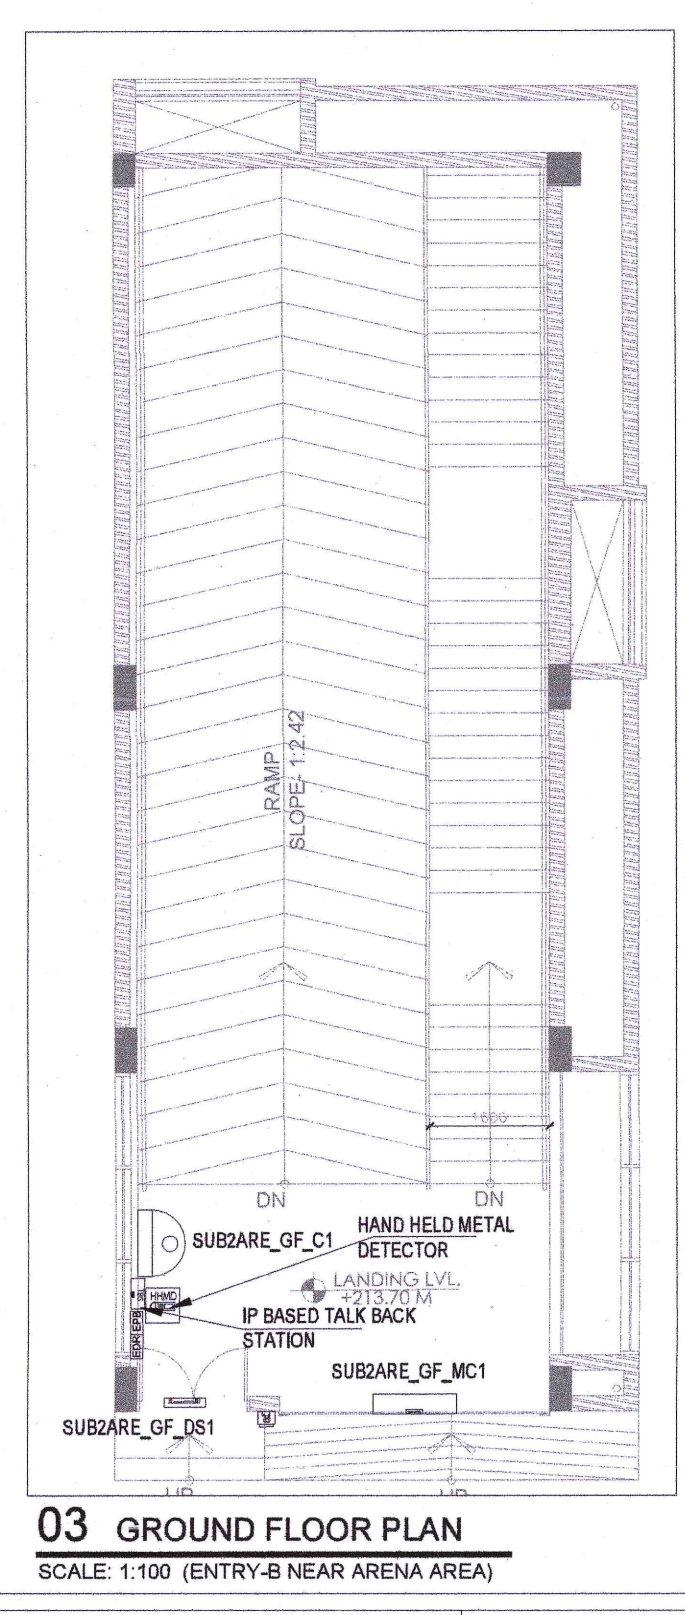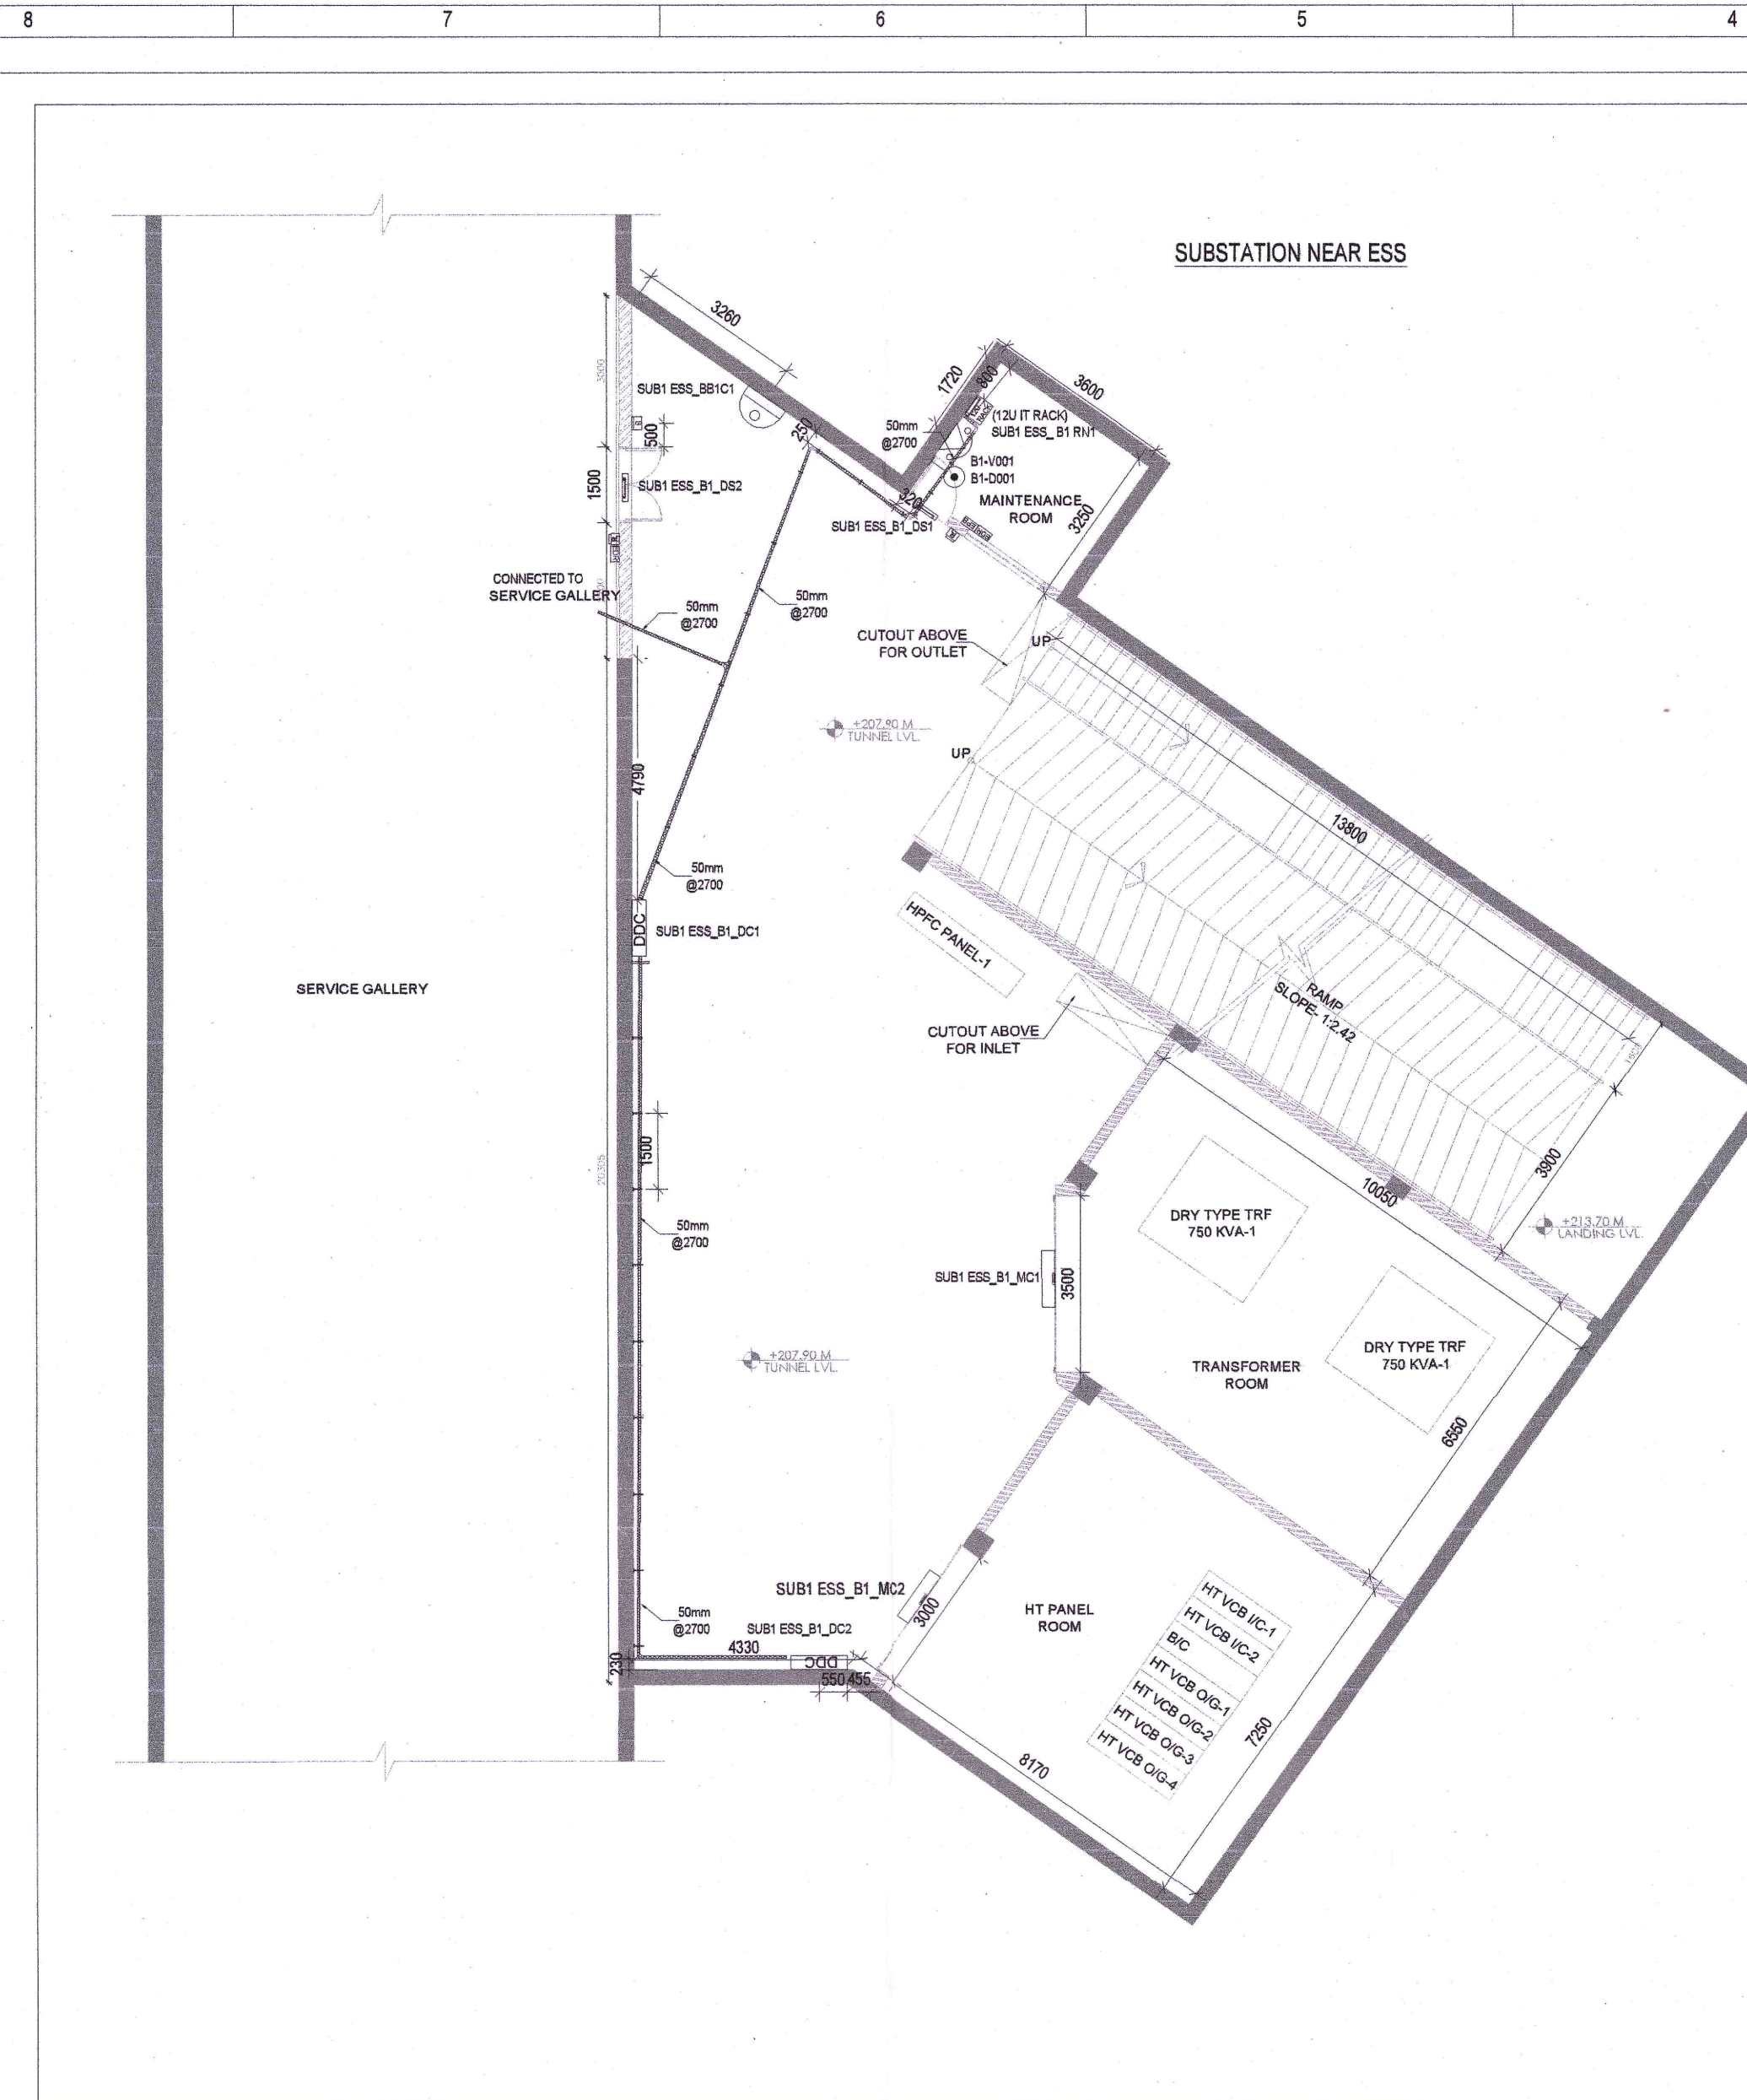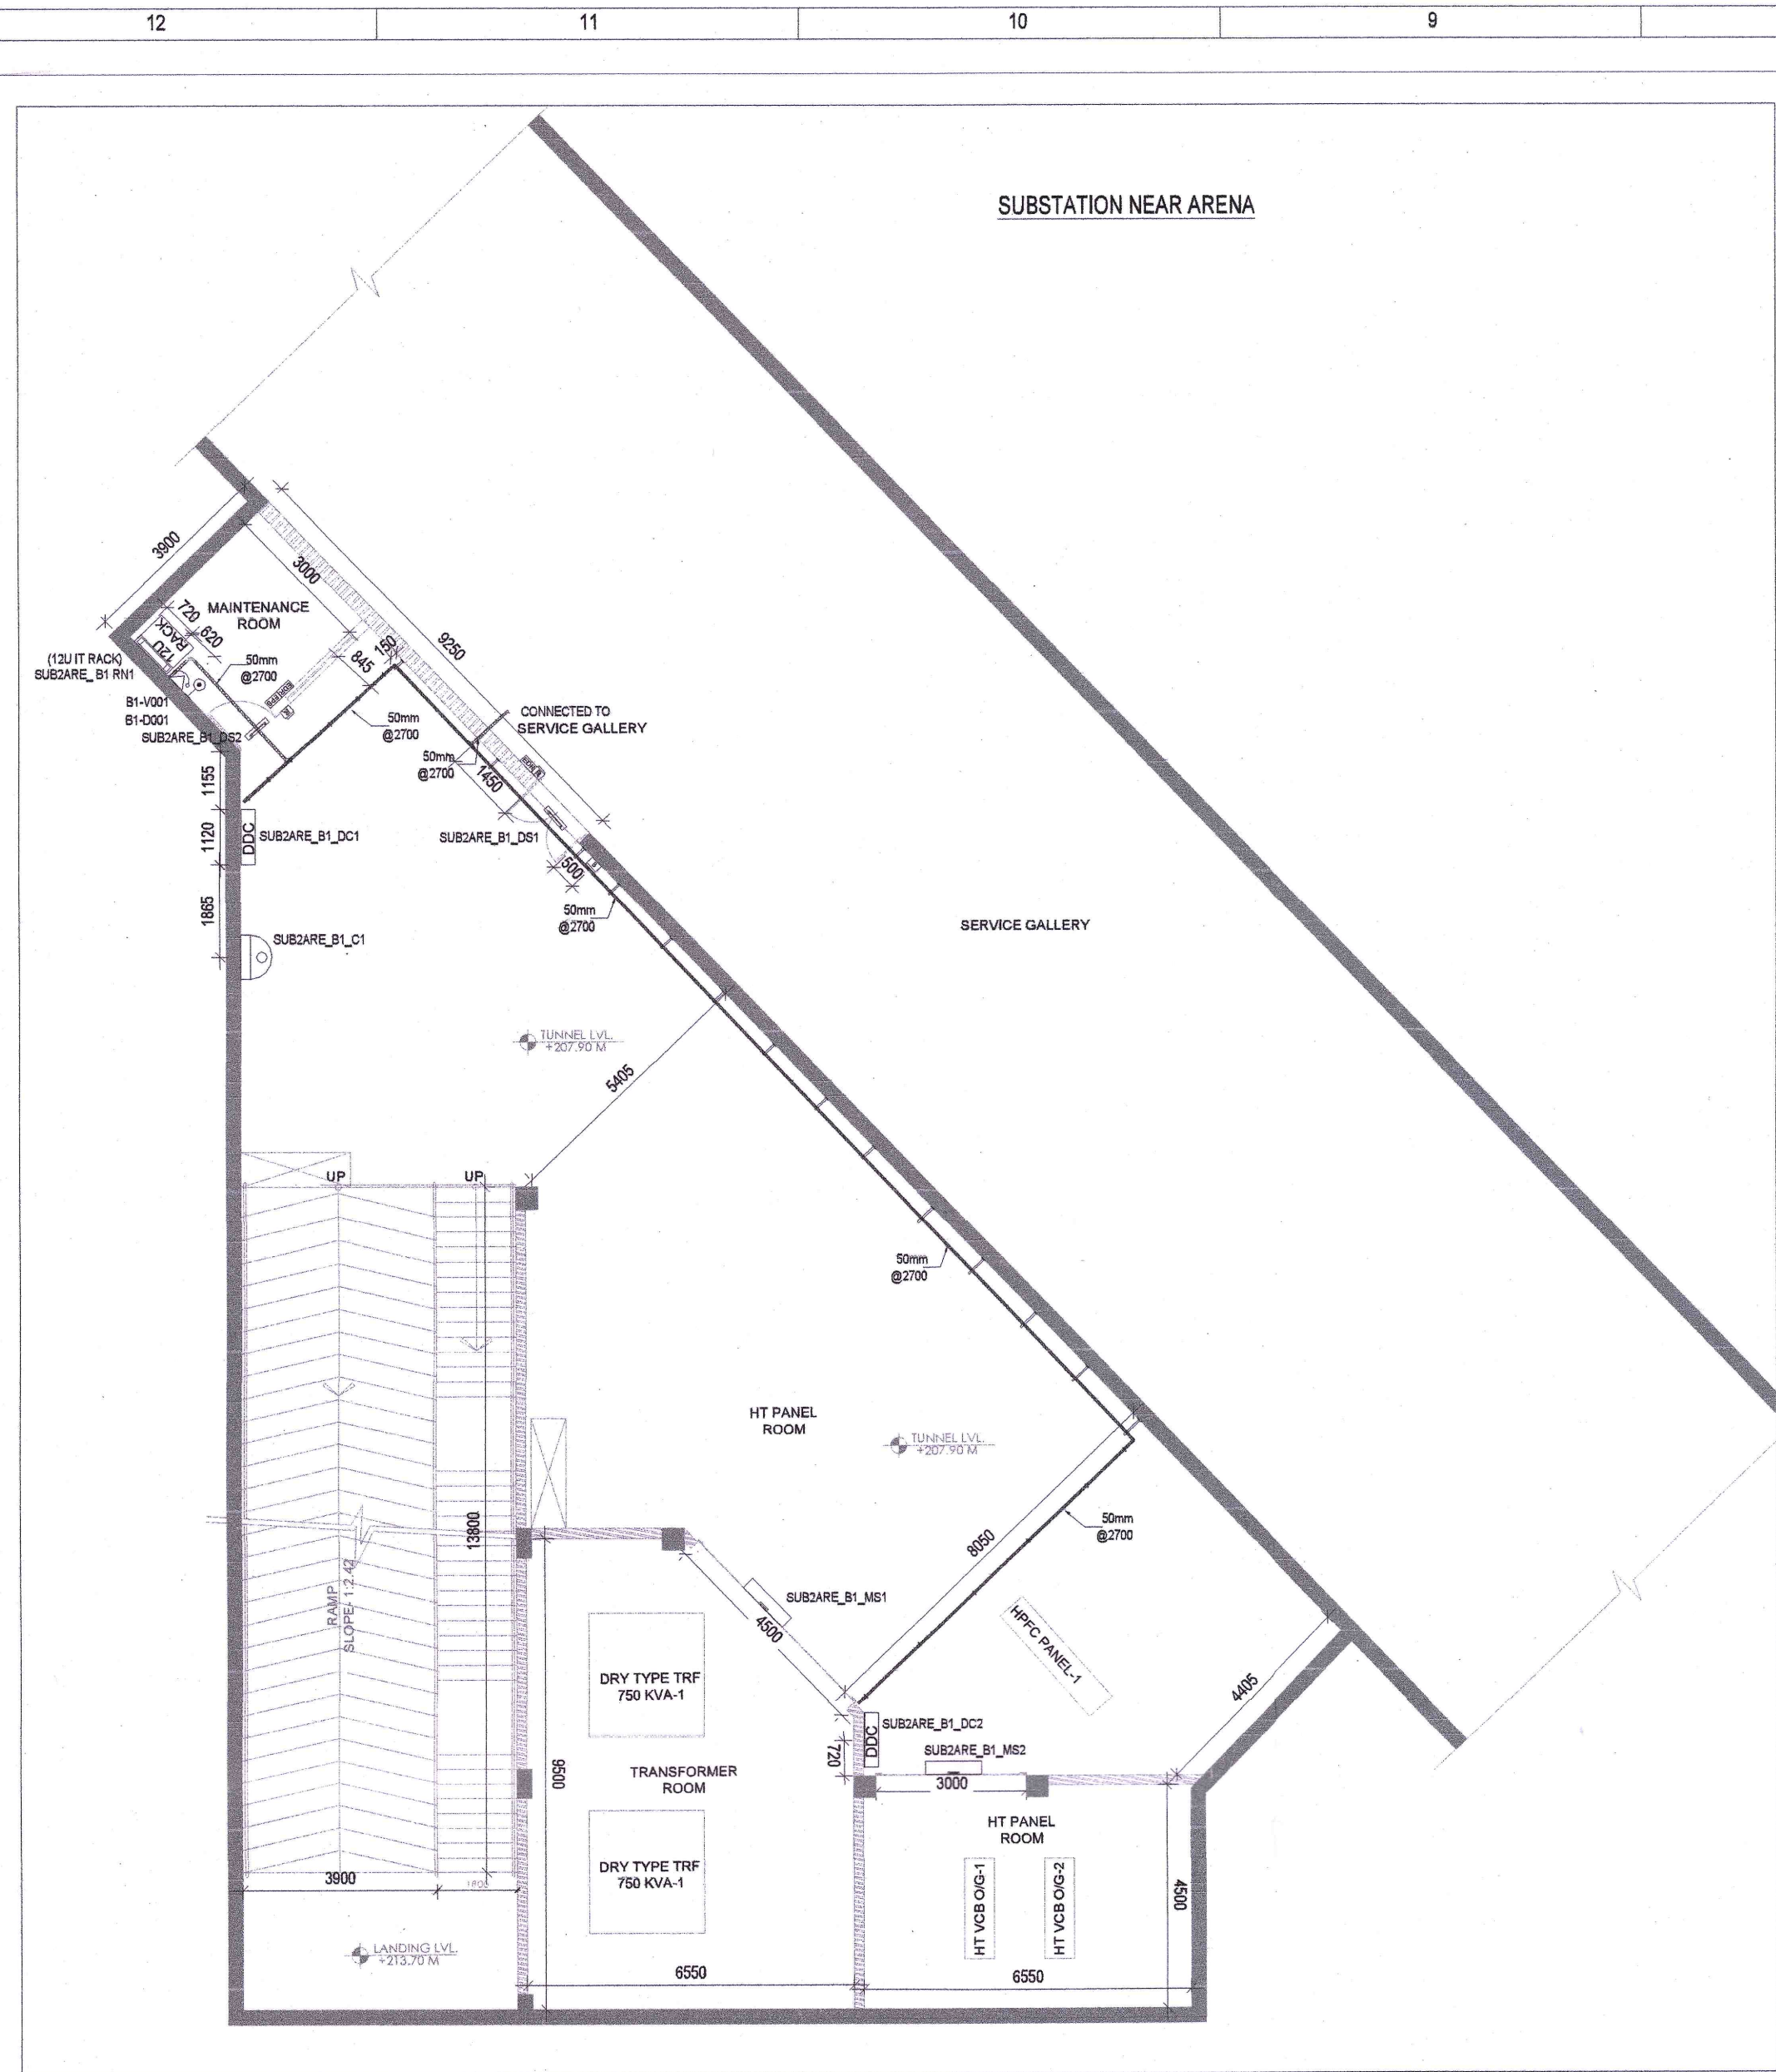

LEGENDS:

SL.NO	SYMBOL	DESCRIPTION	MOUNTING HEIGHT
1	[Symbol]	DATA / VOICE	750mm ABOVE FFL
2	[Symbol]	12 U IT RACK	1200mm ABOVE FFL
3	[Symbol]	DDC PANEL	1500mm COP
4	[Symbol]	DOOR POSITION SENSOR	ON DOOR
5	[Symbol]	EMERGENCY PUSH BUTTON	1000mm ABOVE FFL
6	[Symbol]	EMERGENCY DOOR RELEASE	1000mm ABOVE FFL
7	[Symbol]	MULTI TECHNOLOGY CARD READER	1000mm ABOVE FFL
8	[Symbol]	INDOOR FIXED DOME CAMERA	SURFACE / WALL MOUNTED
9	[Symbol]	MAGNETIC CONTACT VEHICULAR GATE	ON SHUTTER
10	[Symbol]	BOMETRIC READER	1000mm ABOVE FFL
11	[Symbol]	50mm (Wx50mm) METALLIC PERFORATED TYPE CABLE TRAY	MADE OF HOT DIP GALVANIZED SHEETS
12	[Symbol]	IP TALK BACK STATION	1000mm ABOVE FFL
13	[Symbol]	HAND HELD METAL DETECTOR	

NUMBERING DETAIL:

DATA POINT NUMBER	TELEPHONE POINT NUMBER
B1-0001	B1-V001

DDC TAG DETAIL:

FLOOR	BUILDING	DDC
1ST	1	1

DPS TAG DETAIL:

FLOOR	BUILDING	DPS
1ST	1	1

CAMERA TAG DETAIL:




FLOOR	BUILDING	CAMERA NUMBER
1ST	1	1

RN TAG DETAIL:

FLOOR	BUILDING	RACK NUMBER
1ST	1	1

DATA & VOICE SOCKETS FACE PLATE DETAIL:

SYMBOL	QUARD	DUAL	BLANK
[Symbol]	-	1	1
[Symbol]	-	1	1
[Symbol]	-	1	1

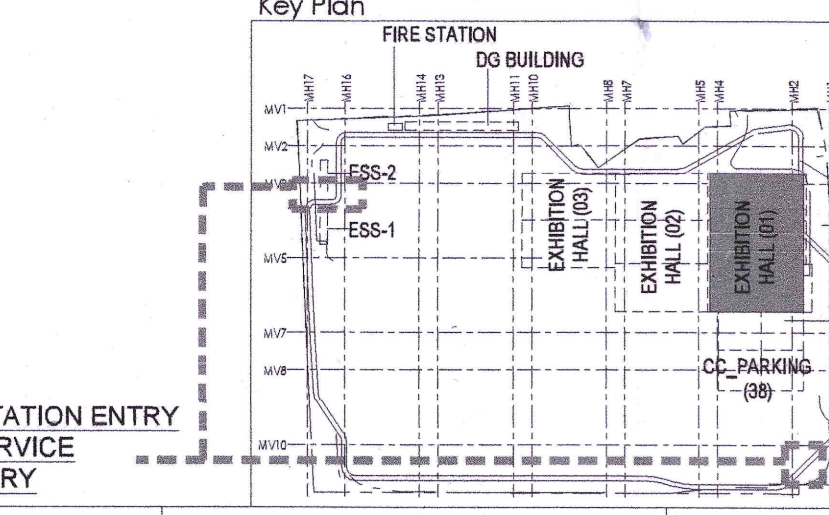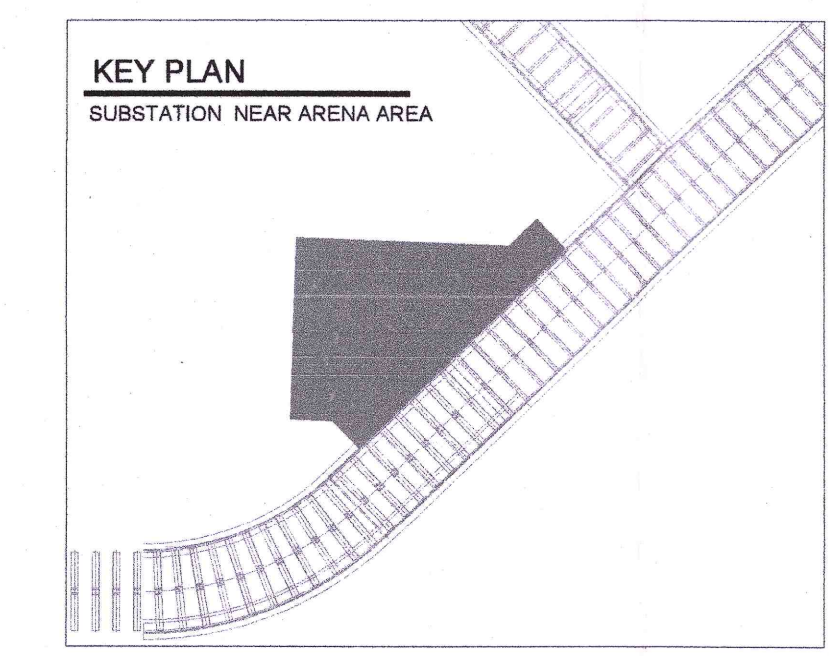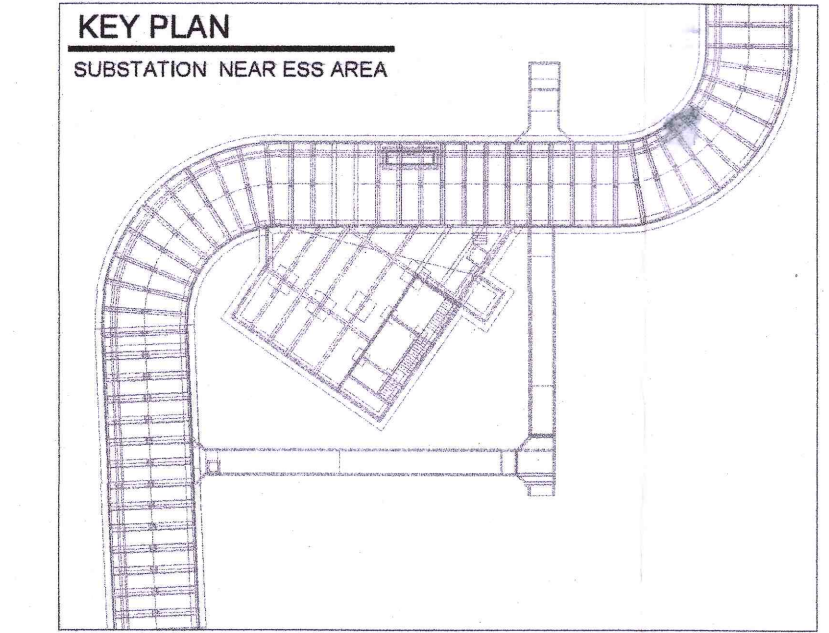

Owner / Employer
India International Convention & Exhibition Centre Limited
Room No. 432A, Ministry of Commerce & Industry, DPT, Udyog Bhawan, New Delhi - 110011, India

Department of Industrial Policy and Promotion Ministry of Commerce & Industry Government of India

Knowledge Partner
Delhi Mumbai Industrial Corridor Development Corporation
Room No 341 B, 3rd Floor Hotel Ashok, Diplomatic Enclave, 508 Chanayapuri, New Delhi - 110021

Employer's Representative
Employer's Engineer
Programme Management Consultant (PMC)

AECOM

Preliminary Engineering Architecture Consultants (PEAC)
idom
No. D-1, Ashwood Building, Green Park, New Delhi, Delhi 110016, India

EPC Contractor
L&T Construction
Buildings & Factories
Mount Poonamallee Road, Manapakkam, P.O. No. 979, Chennai - 600 089

EPC Contractor's Representatives
Design Consultant
Engineering Design and Research Centre (EDRC)
L&T Construction - Buildings & Factories

Architectural Consultant
ARCOP
Arcop Associates Pvt. Ltd.
A-15, Pampore Enclave - G.K-1 New Delhi, Delhi 110048, India

Structural Proof Consultant
Indian Institute of Technology (IIT) Madras
Sardar Patel Rd, Opposite to C. R. & A. Chander, Tamil Nadu 600036

MEP Proof Consultant
Egis India Consulting Engineers Pvt. Ltd.
Plot No. 46, Sector 32, Institutional Area, Opp: Zenith Solutions, Gurugram, Haryana 122001

ICT Proof Consultant
CKR Consulting Engineers Pvt. Ltd.
447/1, 3rd Floor, Narayana Arcade, 5, Subramanyashetty Road, Heliopatra Circle, Basavanagudi, Bengaluru - 560004

Certification
EPC Contractor
Design Consultant
Architectural Consultant
Proof Consultant







Reviewed GFC drawings prepared by [Signature] and [Signature] have been adhered to:
Issued by [Signature] on behalf of PEAC
Employer / Employer's Engineer

RO ISSUED AS GOOD FOR CONSTRUCTION
REV DESCRIPTION DATE DESG DRWN CHD APFD
Revisions
ARCHITECTURAL [Signature] FPS [Signature]
STRUCTURAL [Signature] PFMG [Signature]
ELECTRICAL [Signature] PHE [Signature]
ELV SYSTEM [Signature] GIS [Signature]
HVAC [Signature] GEOTECH [Signature]
CHECKED BY SIGN DATE CHECKED BY SIGN DATE



EPC Contractor
L&T Construction
Buildings & Factories

JOB No: O17203
Project Name
DESIGN AND CONSTRUCTION OF INDIA INTERNATIONAL CONVENTION & EXPO CENTRE
SECTOR 25, DWARKA, NEW DELHI, INDIA
Drawing Status
GOOD FOR CONSTRUCTION (GFC)
Drawing No
L 30 1111 R0
Title
EXTERNAL SUBSTATION (NEAR ESS, ARENA)- ELV EQUIPMENT LAYOUT
EDRC DWG No: O17203-L-SP-30-LV-1111
Scale As indicated
Sheet Size A1

This drawing is the property of L&T Construction. BAK-EDRC and must not be passed on to any person or body not authorized by us to receive it nor be copied or otherwise made use of in full or in part by such person or body without our prior permission. No part of this drawing may be reproduced in any form or by any means electronic or mechanical, including photocopying, recording, or by any information storage or retrieval system, without permission in writing from L&T Construction.

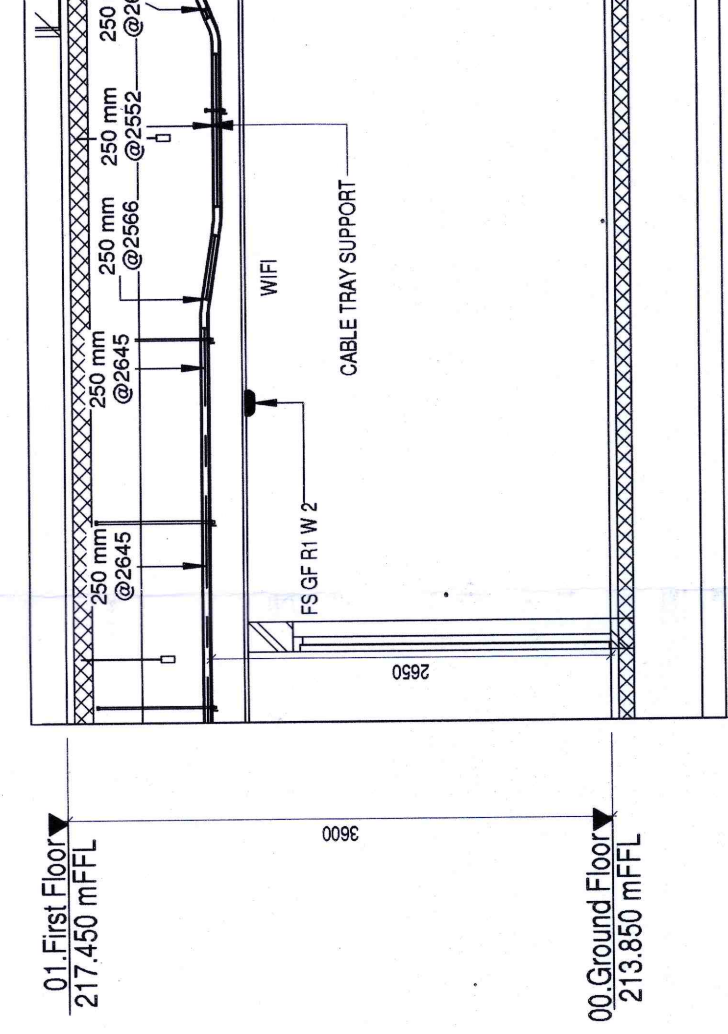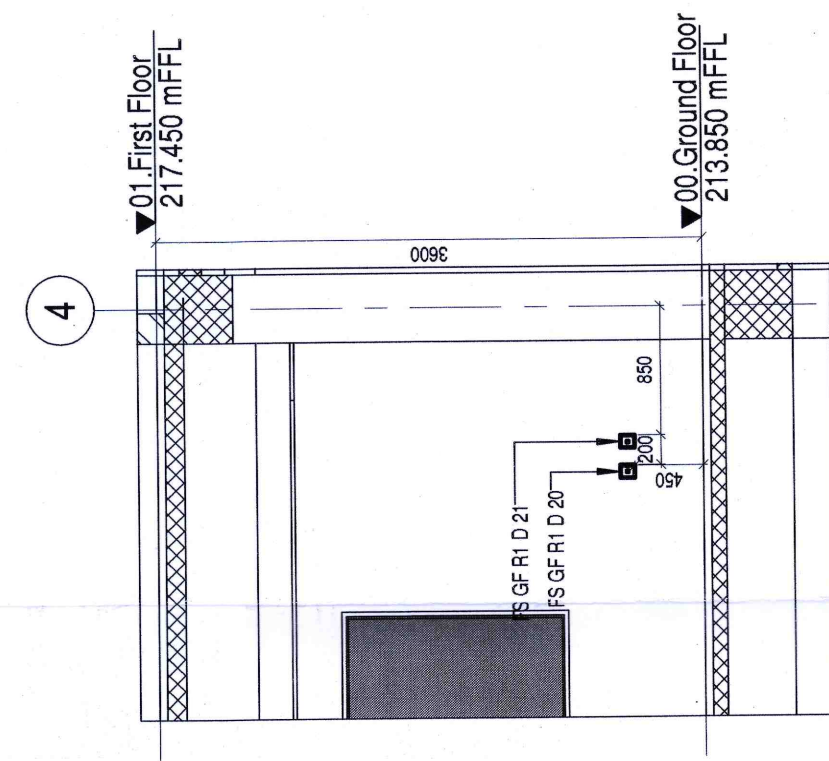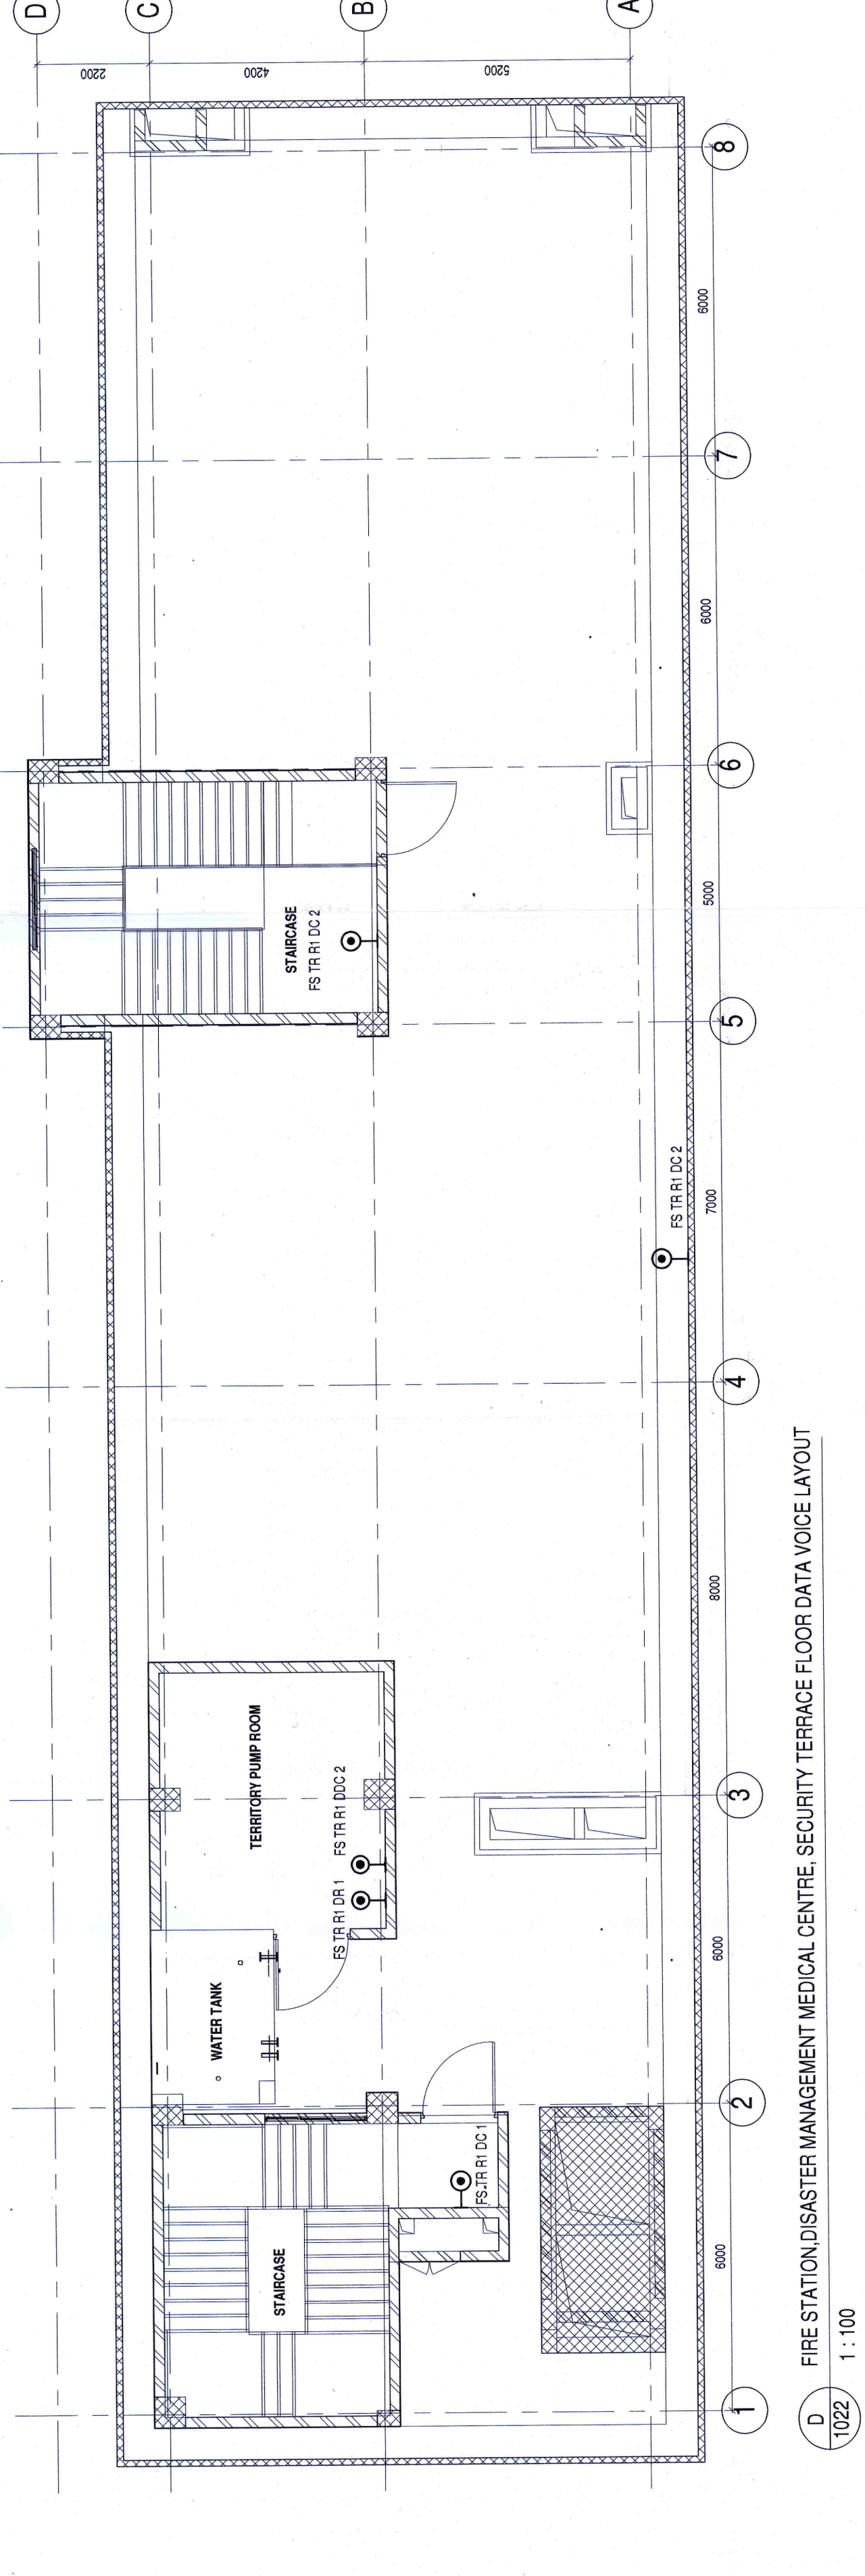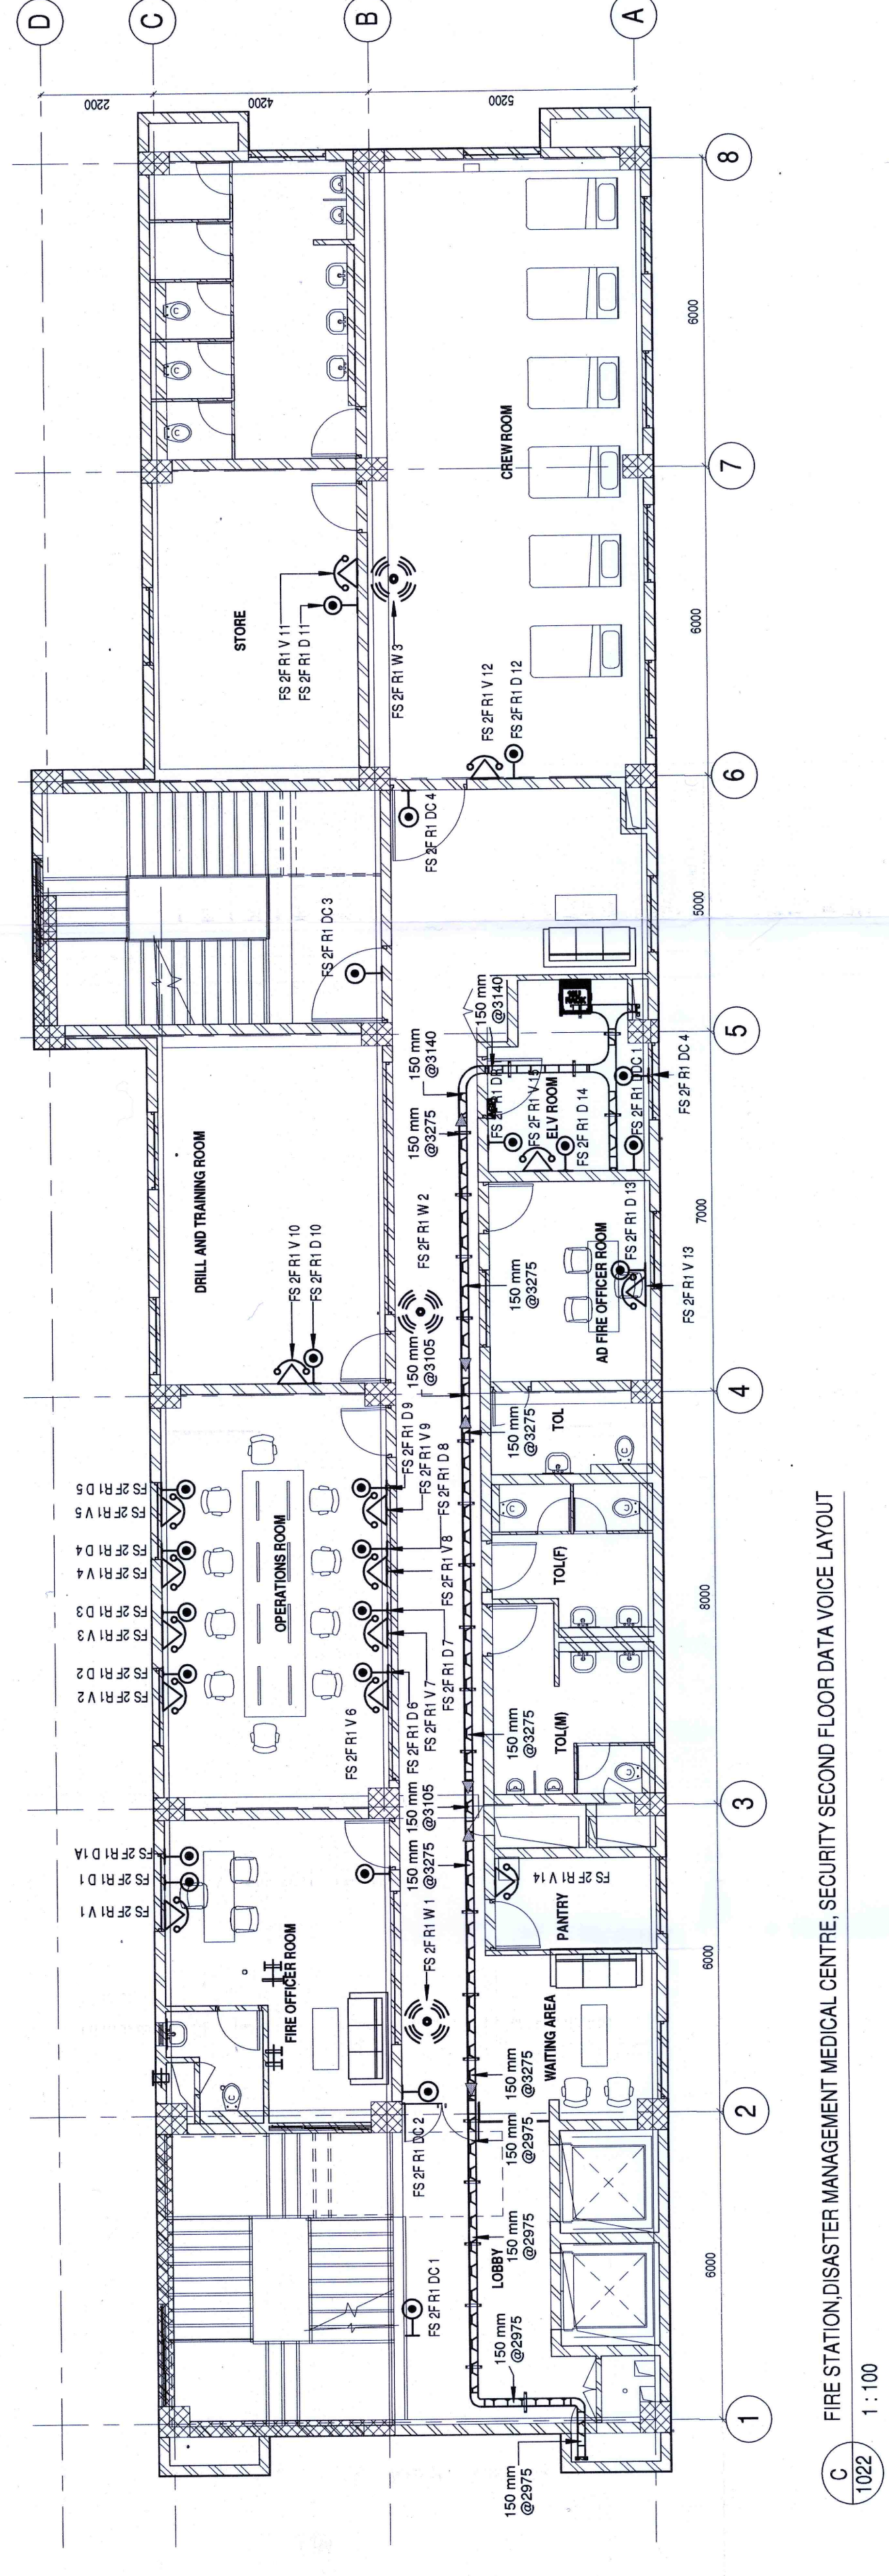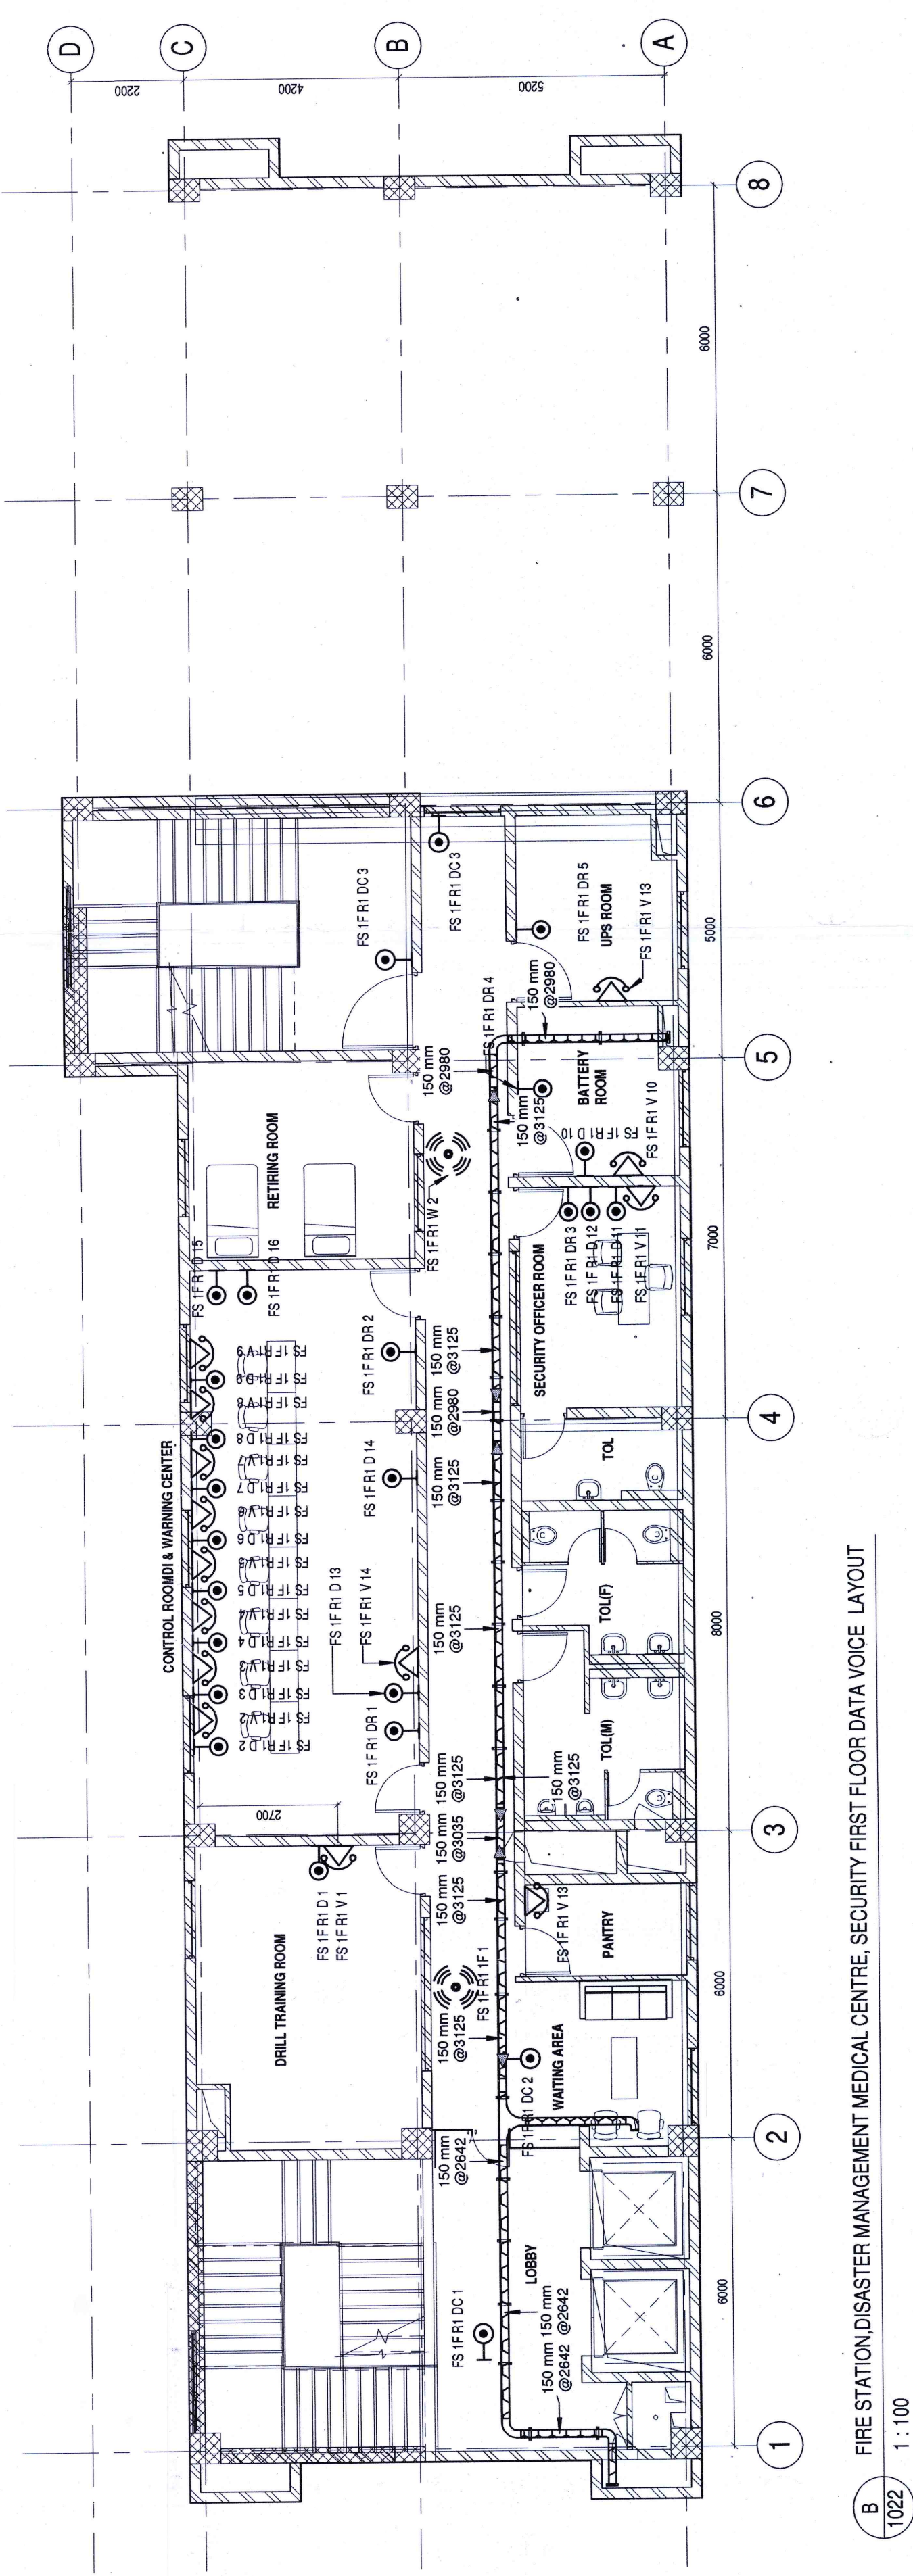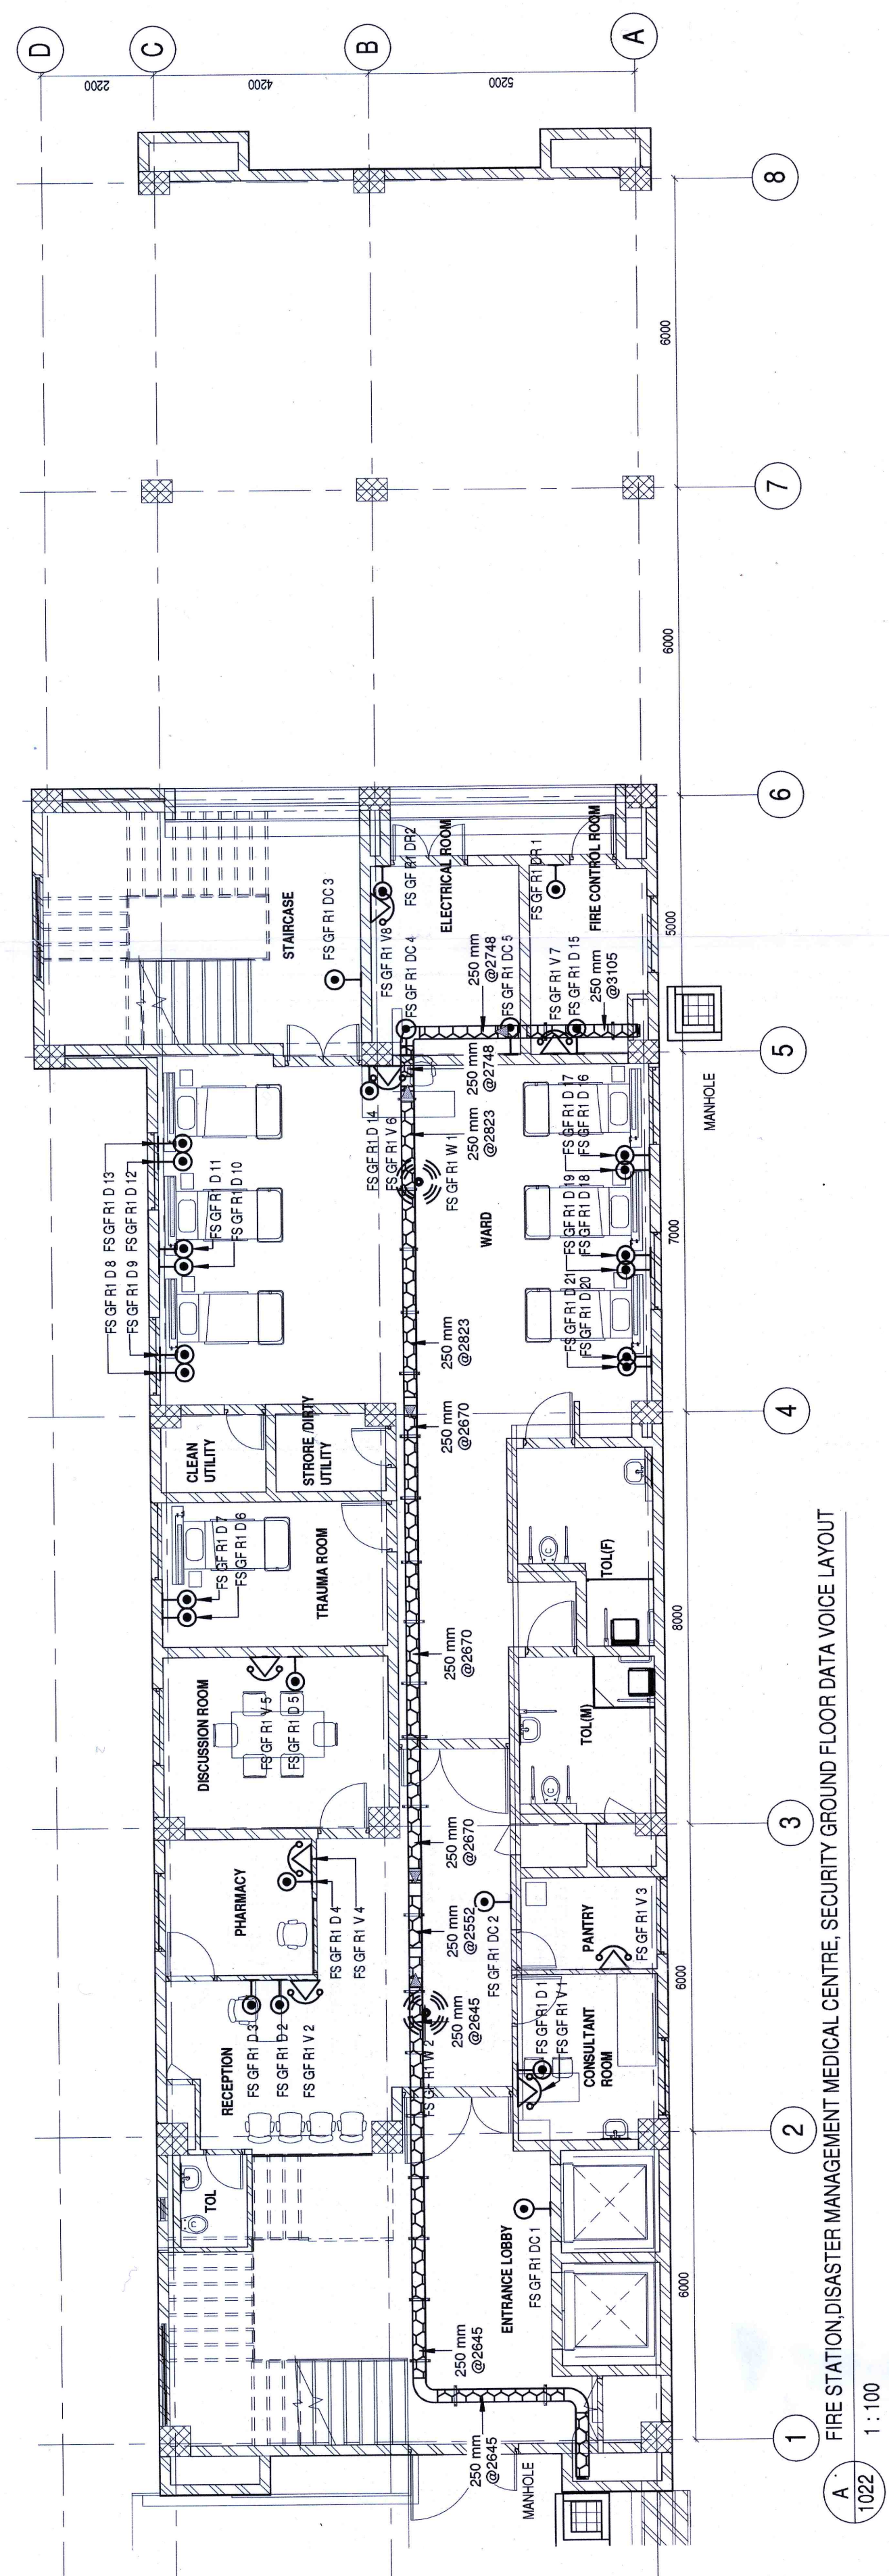

S/N	SYMBOL	DESCRIPTION	MOUNTING HEIGHT
1		DATA SOCKET	750mm FROM FFL
2		TELEPHONE SOCKET	750mm FROM FFL
3		WIFI-AP	FALSE CEILING MOUNTED

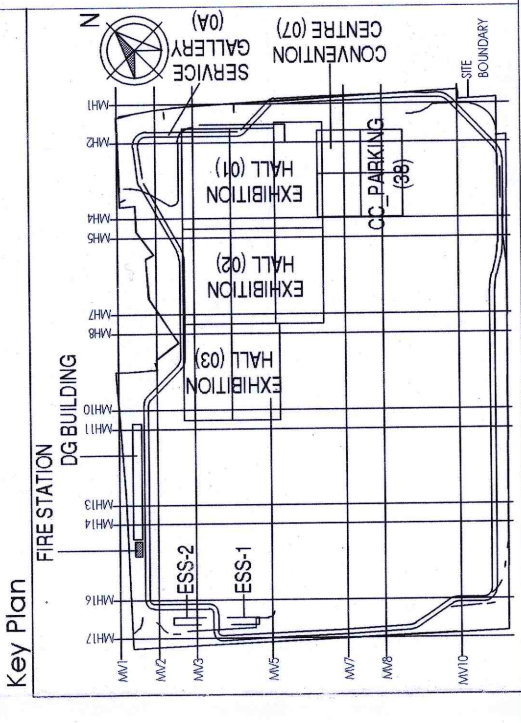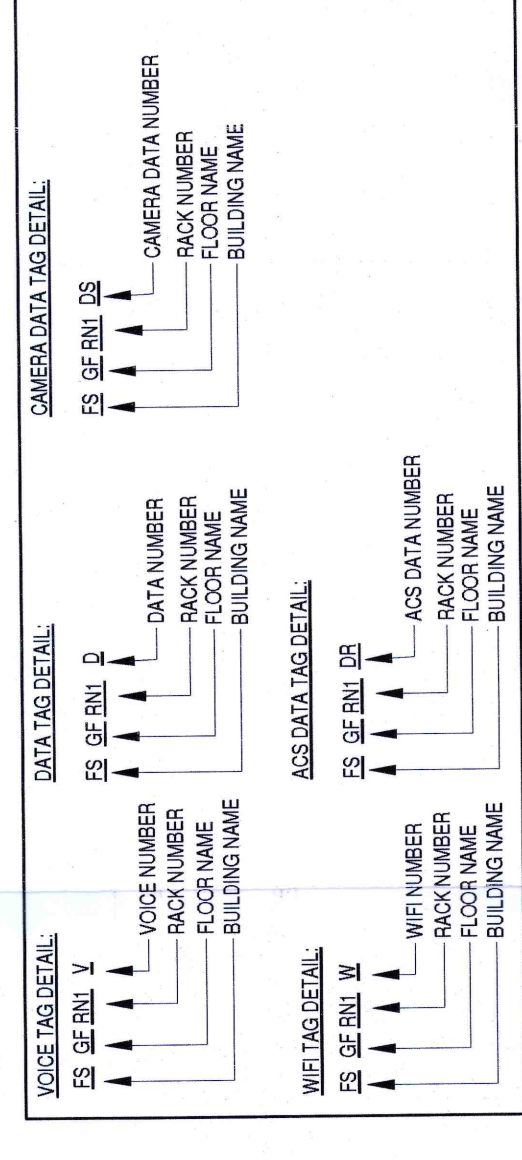[illegible][illegible]