
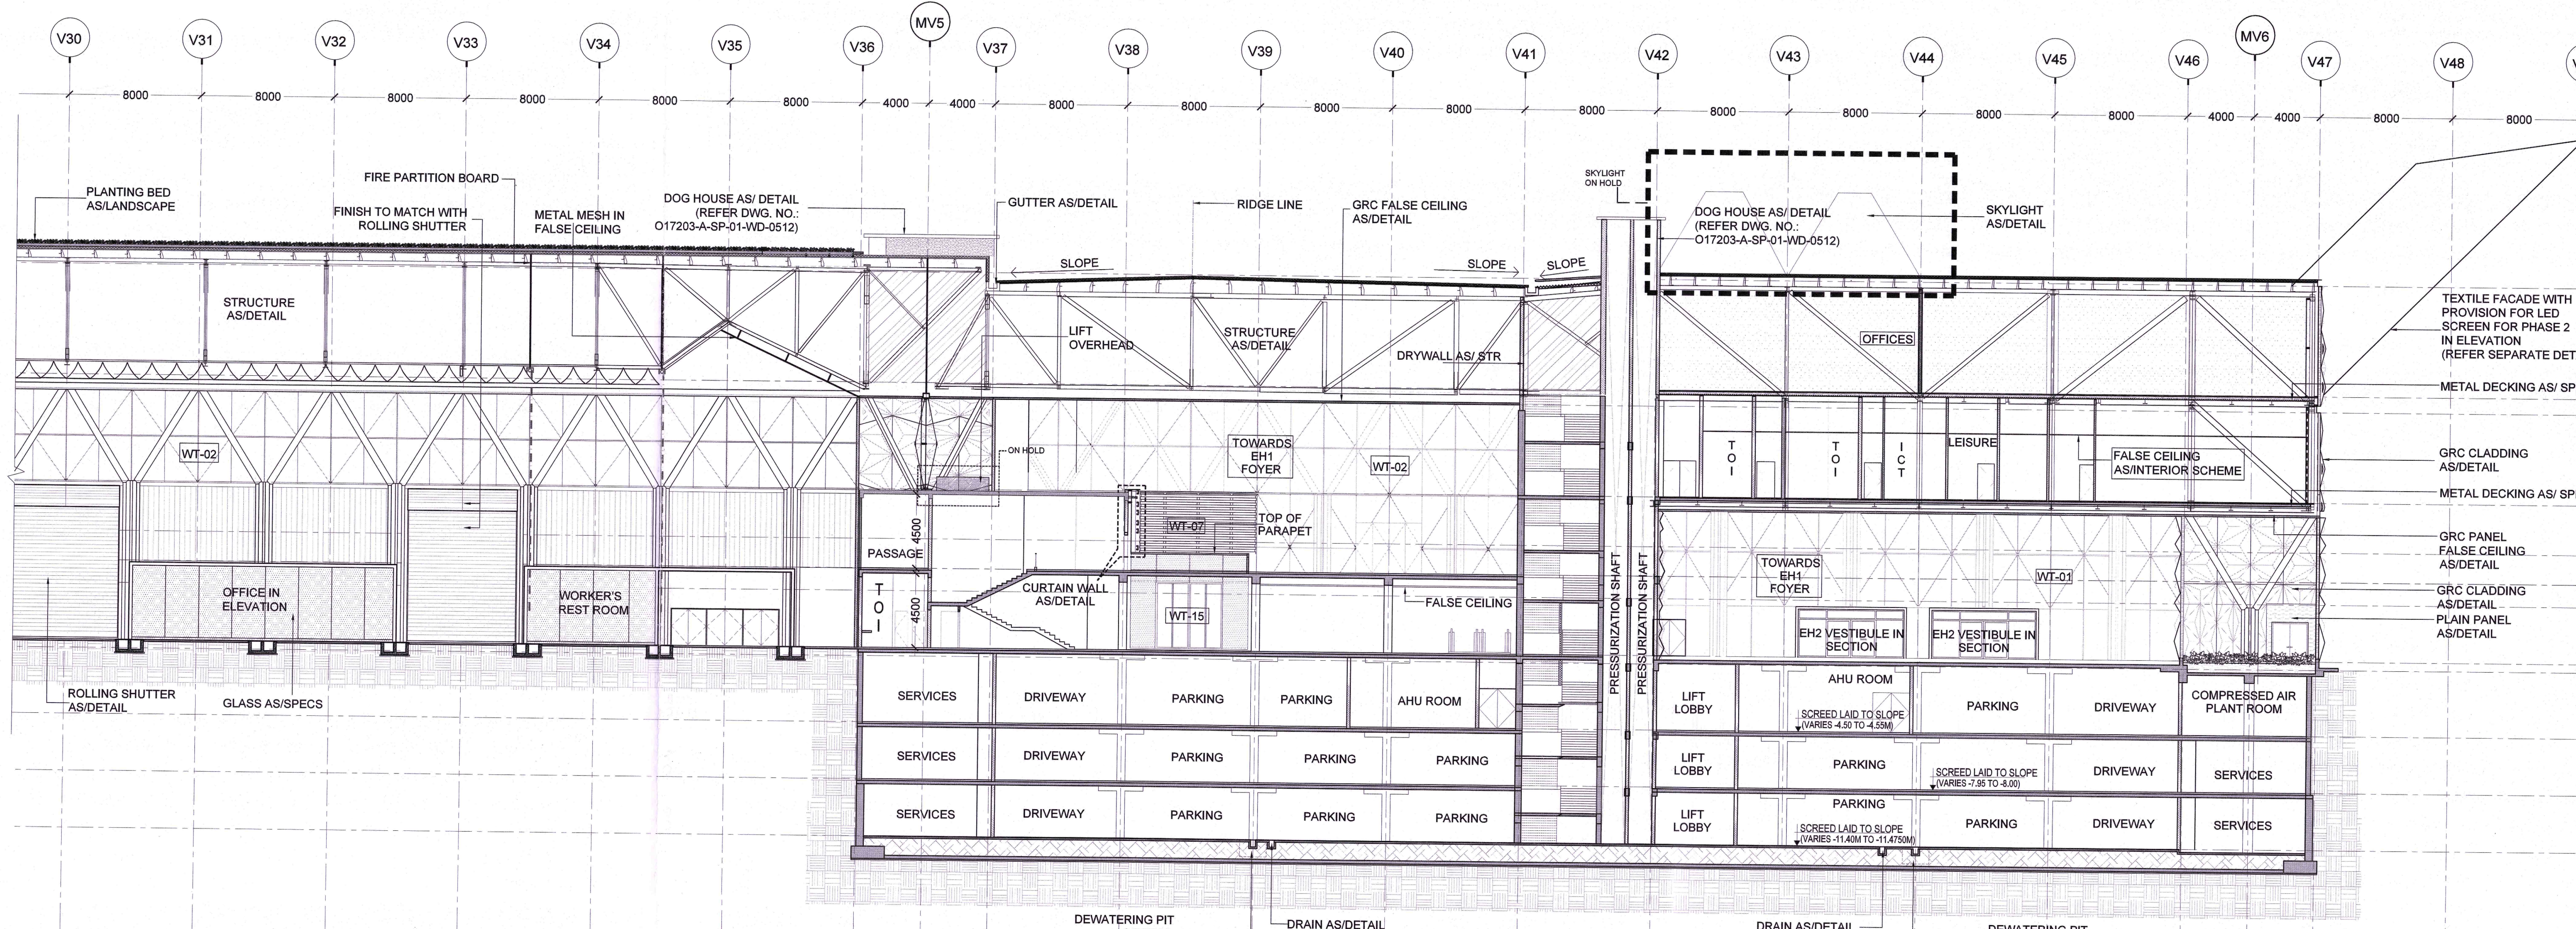
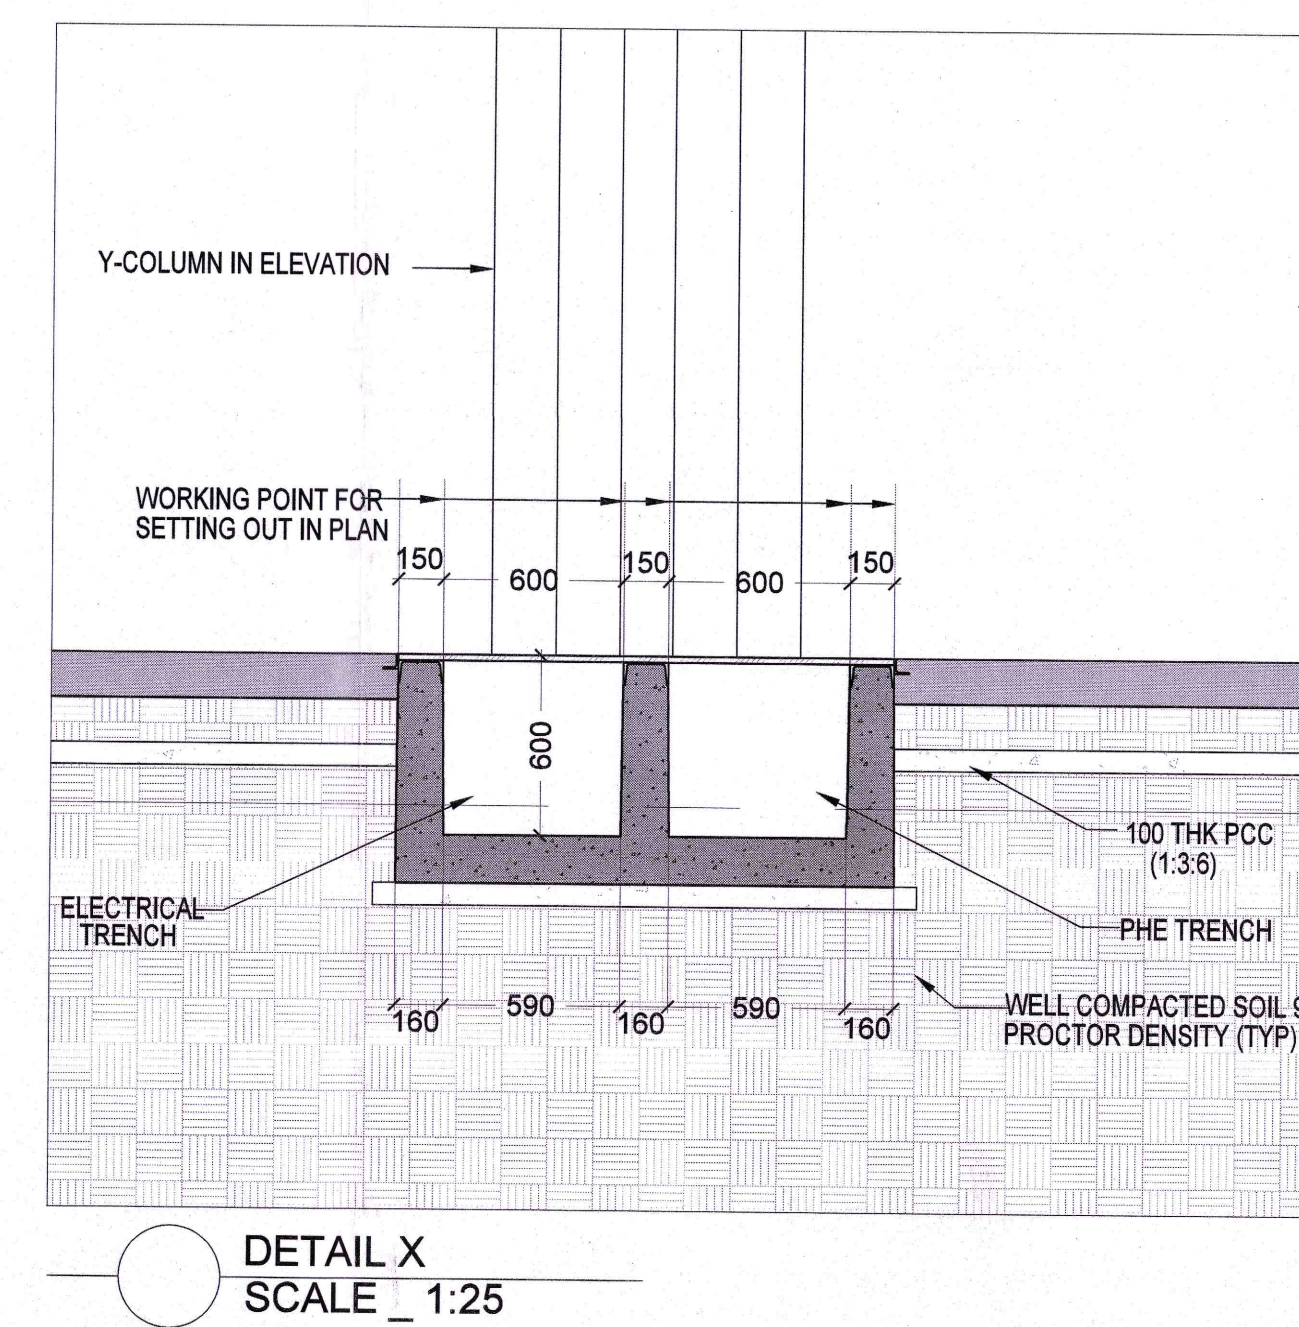
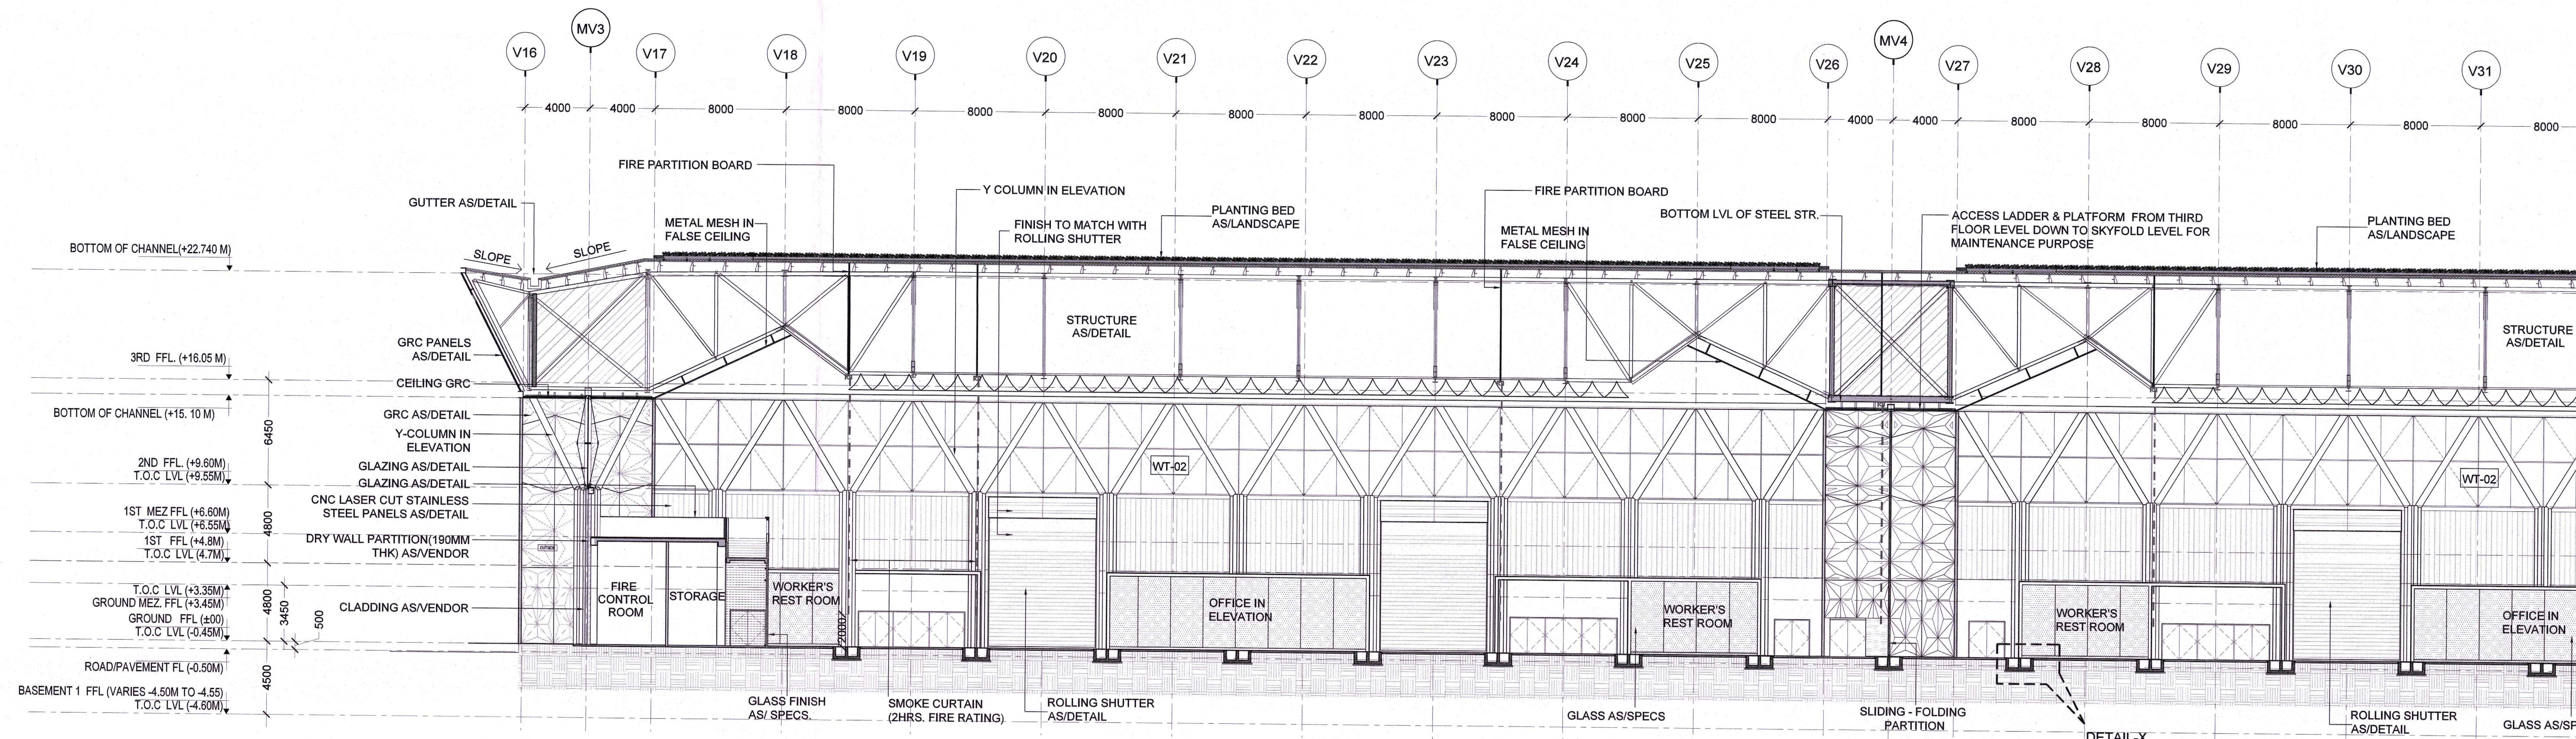
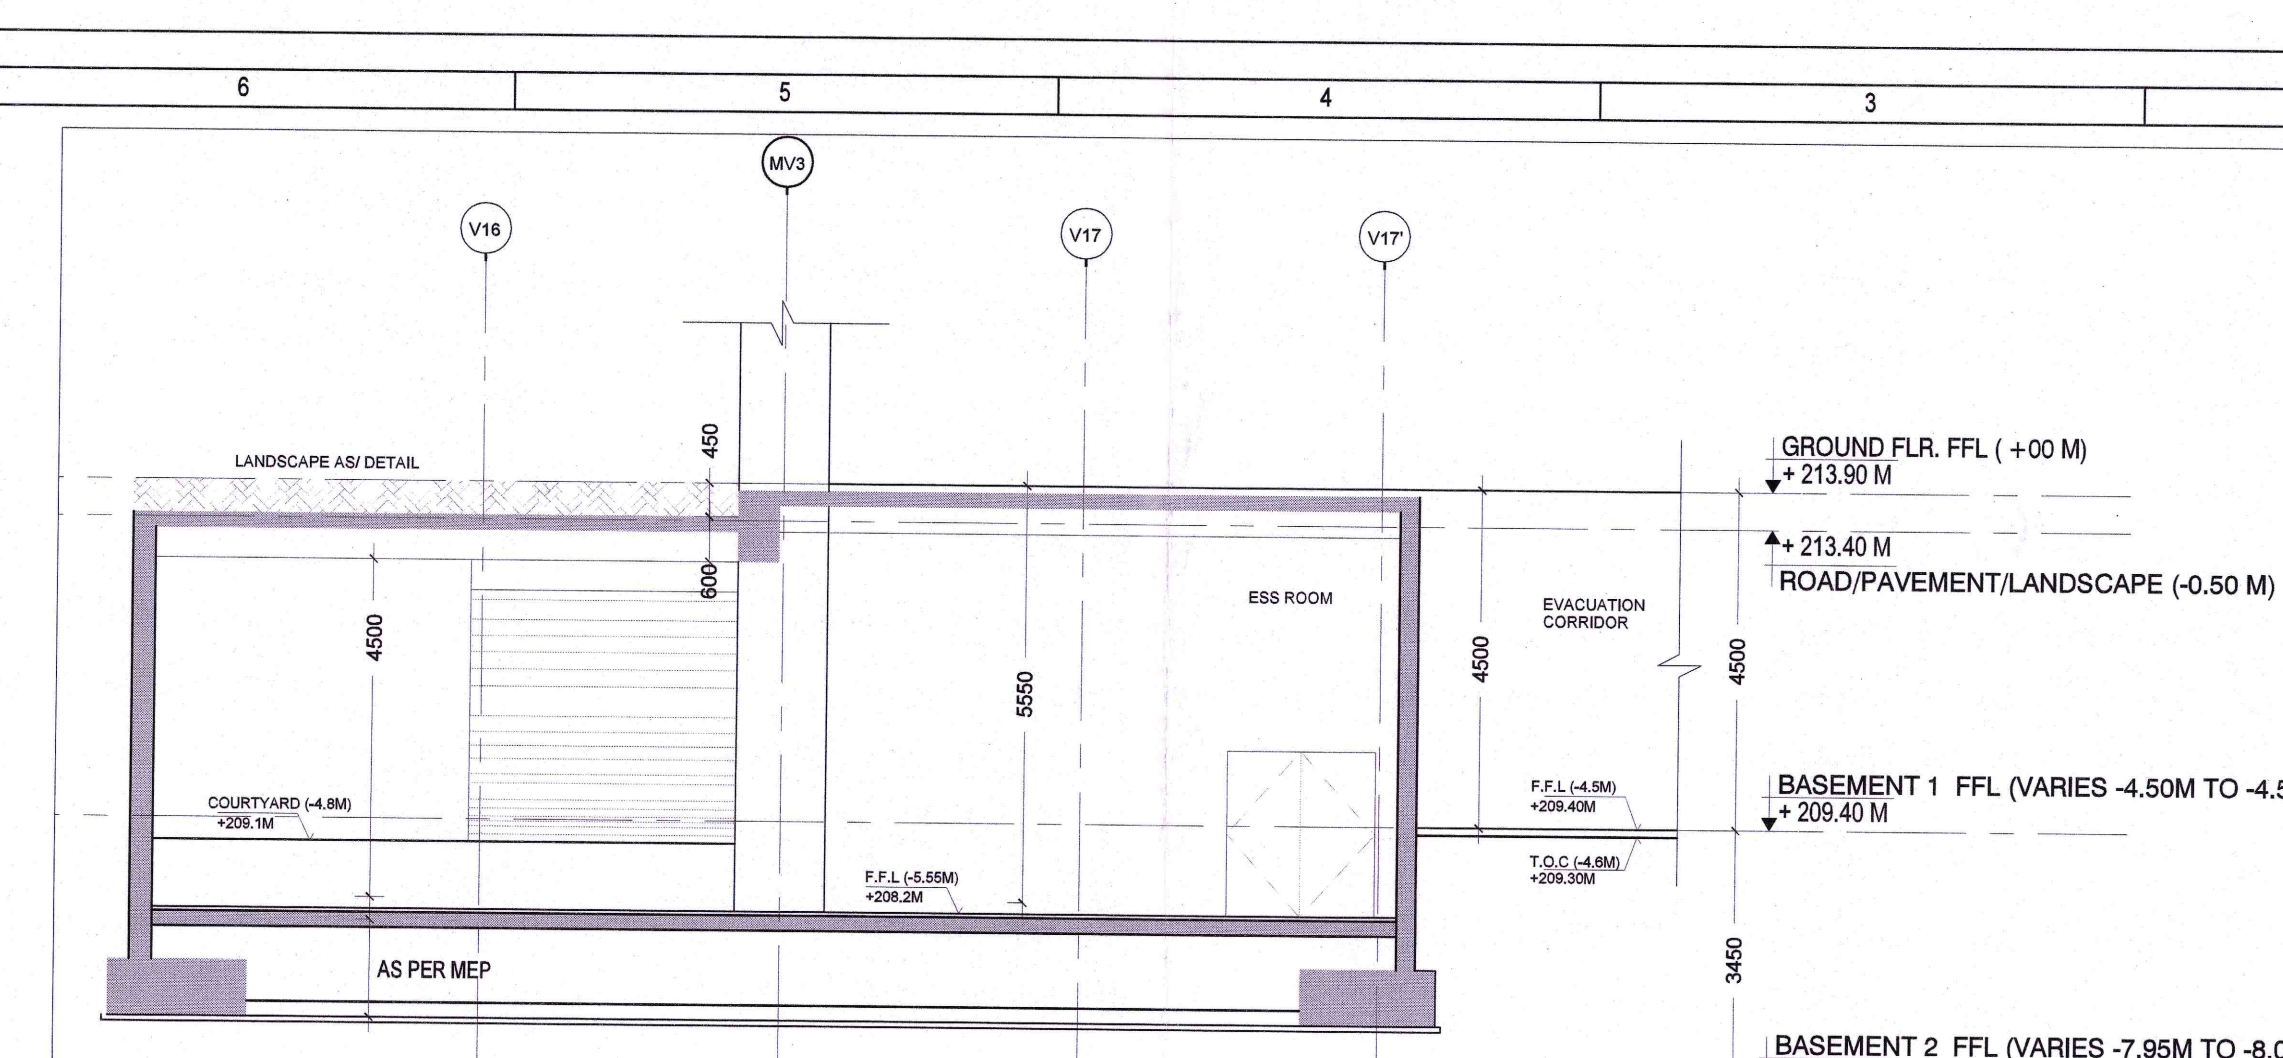


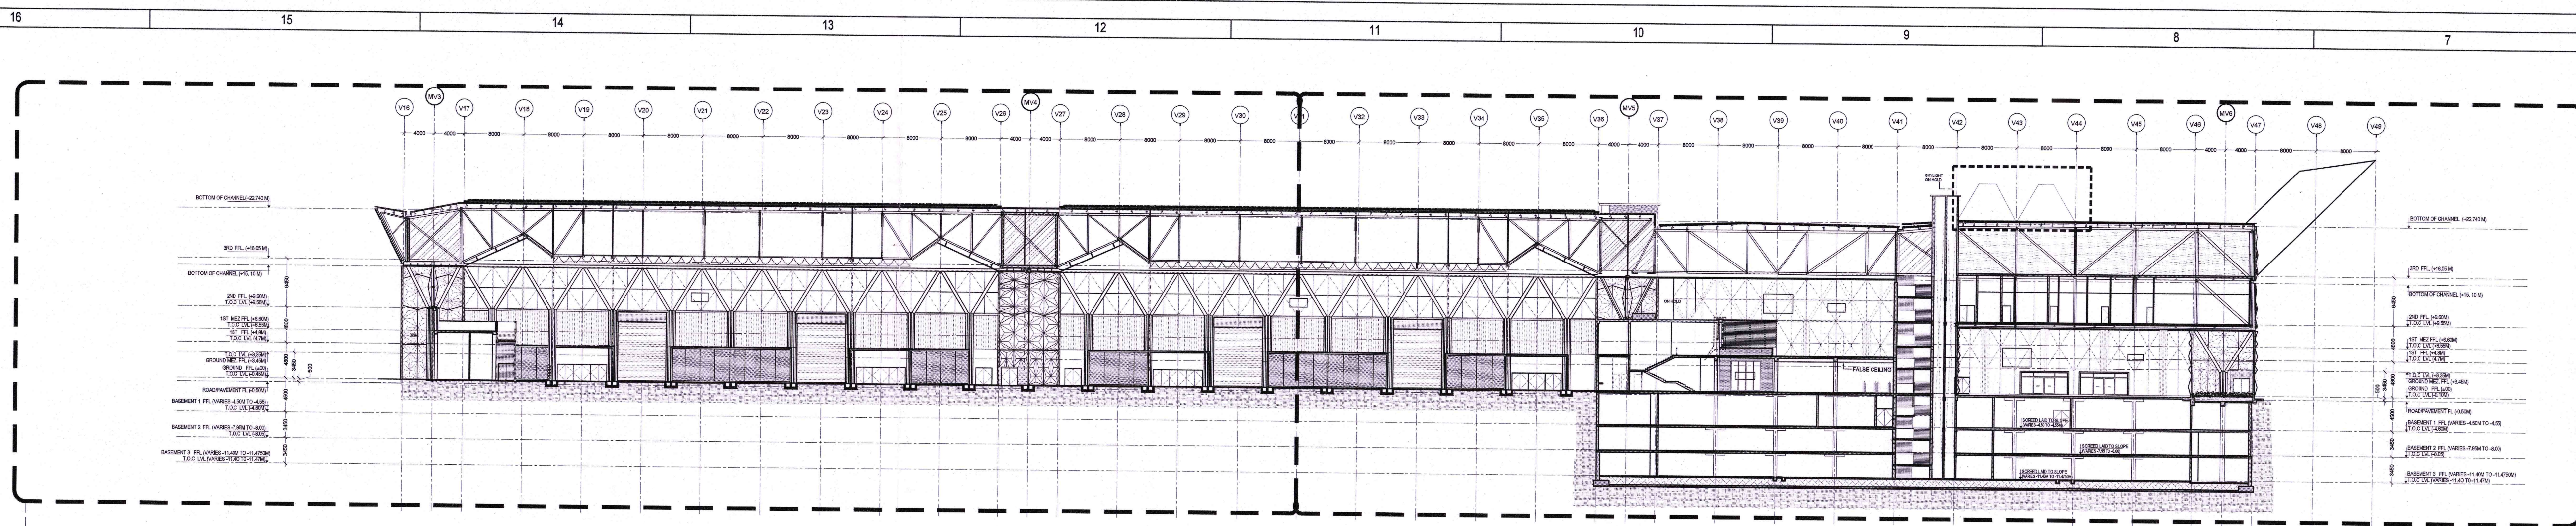

SECTION - DETAIL B
SCALE 1:200

NOTES:


1. ALL DIMENSIONS ARE IN MILLIMETERS. LEVELS IN METERS AND ANGLES IN DEGREES UNLESS OTHERWISE NOTED.
2. THE DRAWING IS TO BE READ AND NOT TO BE SCALED. ONLY VERTICAL DIMENSIONS IN WALL SECTIONS SHALL BE FOLLOWED.
3. THE DRAWING SHALL BE READ IN CONJUNCTION WITH ALL RELEVANT ARCHITECTURAL, STRUCTURAL AND SERVICE DRAWINGS.
4. ALL DIMENSIONS SHALL BE VERIFIED ON SITE PRIOR TO START OF WORK AND ANY DISCREPANCY SHALL BE BROUGHT TO THE NOTICE OF THE ARCHITECT.
5. 0.00 CORRESPONDENCE TO 213.9

6. FOR GRC DETAILS, REFER SEPARATE GRC PACKAGE.
7. FOR WALL TYPE DETAILS, REFER SEPARATE FACADE PACKAGE.

Wall Types	Description
WT-01	Horizontal Fin System ("X" Bracing start from first level of Aluminium Transom.)
WT-02	Tension rod cable system
WT-08	Aluminium Sliding with Bronze finish
WT-14	Horizontal Fin System ("X" Bracing start from GROUND FLOOR FFL TO +15.30 LVL.)

Plain Panels as/ Specs

ALL FINISH (WT-08, DOOR, ROLLING SHUTTER) WILL BE CAPTURED IN SEPARATE DOCUMENT AFTER GETTING APPROVAL FROM PEAC.

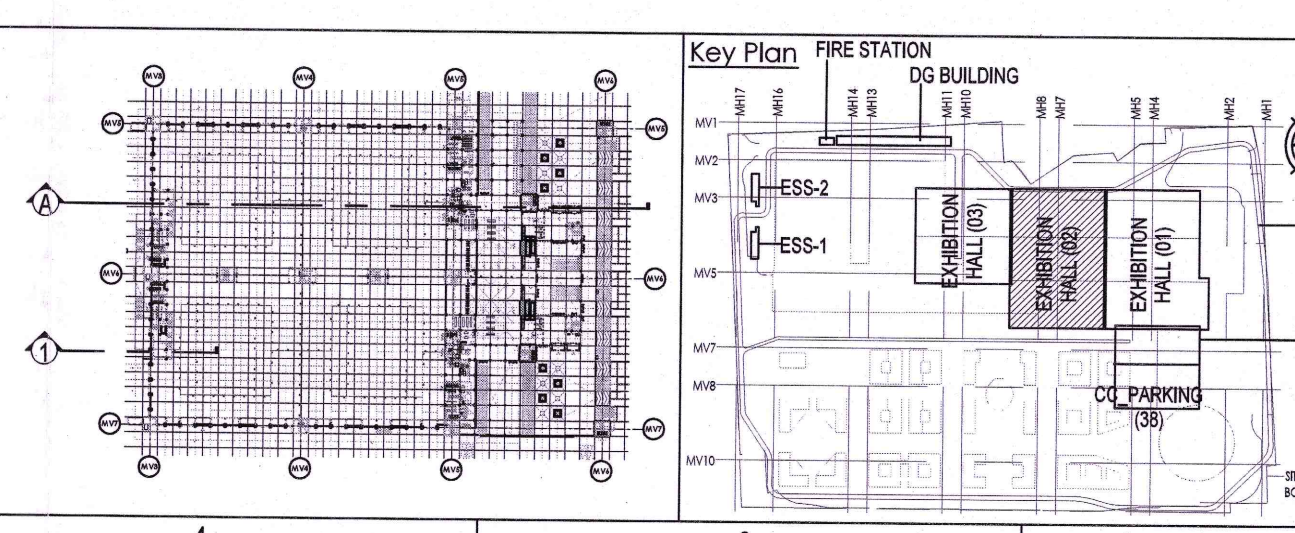

Owner / Employer
India International Convention & Exhibition Centre Limited
Room No. 424, Ministry of Commerce & Industry, D.P.P. Building, New Delhi - 110011, India
Department of Industrial Policy and Promotion, Ministry of Commerce & Industry, Government of India

Knowledge Partner
Dhruv Mumbai Industrial Corridor Development Corporation
Room No. 311 & 3rd Floor, Industrial Development, Sector 138, Connaught Place, New Delhi - 110029

Employer's Representative
Employee Engineer
Programme Management Consultant (PMC)
AECOM
Preliminary Engineering Architecture Consultants (PEAC)
idm **CPKUREJA**
A-1, D-1, Main Road, Sector 4, Noida-201301, India
A-1, D-1, Main Road, Sector 4, Noida-201301, India

EPC Contractor
L&T Construction
Buildings & Factories
Mount Road, Sector 138, Connaught Place, New Delhi - 110029

EPC Contractor Representative
Design Consultant
Engineering Design and Research Center (EDRC)
L&T Construction - Buildings & Factories
Architectural Consultant
ARCOF
Arcof Associates Pvt. Ltd.
A-15, Park Road, Sector 138, Connaught Place, New Delhi - 110029, India

Structural Proof Consultant
Indian Institute of Technology (IIT) Madras
Sector 138, Connaught Place, New Delhi - 110029, India

MEP Proof Consultant
Egi India Consulting Engineers Pvt. Ltd.
Plot No. 4, Sector 138, Connaught Place, New Delhi - 110029, India

ICT Proof Consultant
C&S Consulting Engineers Pvt. Ltd.
Plot No. 4, Sector 138, Connaught Place, New Delhi - 110029, India

Certification
EPC Contractor
Design Consultant
Architectural Consultant
Proof Consultant
Structural
MEP
ICT
PEAC
Reviewed GFC drawings prepared by Contractor and issued for preliminary aspects and parameters based on drawings up to 1:200 scale.

Issued by
Employer / Employer Engineer

REV	DESCRIPTION	DATE	DESIGN	DRW	CHKD	APPD
1	ISSUED FOR GFC	2023/11/14				
2	REVISIONS					
3	ARCHITECTURAL					
4	ELECTRICAL					
5	MECHANICAL					
6	WATER					
7	CHECKED BY	SEN	DATE	CHECKED BY	SEN	DATE


EPC Contractor
L&T Construction
Buildings & Factories
Project Name
JOB No: 017203

DESIGN AND CONSTRUCTION OF INDIA INTERNATIONAL CONVENTION & EXPO CENTRE
SECTOR 25, DWARKA, NEW DELHI, INDIA
Drawing Status **GOOD FOR CONSTRUCTION**
GOOD FOR CONSTRUCTION


Drawing No: A 02 0301 Rev. No: R0

Title:
EXHIBITION HALL - 2
SECTION AA'


EDRC DWG No: 017203-A-SP-02-WD-0301
Scale: 1:500, 1:200
Sheet No: AD

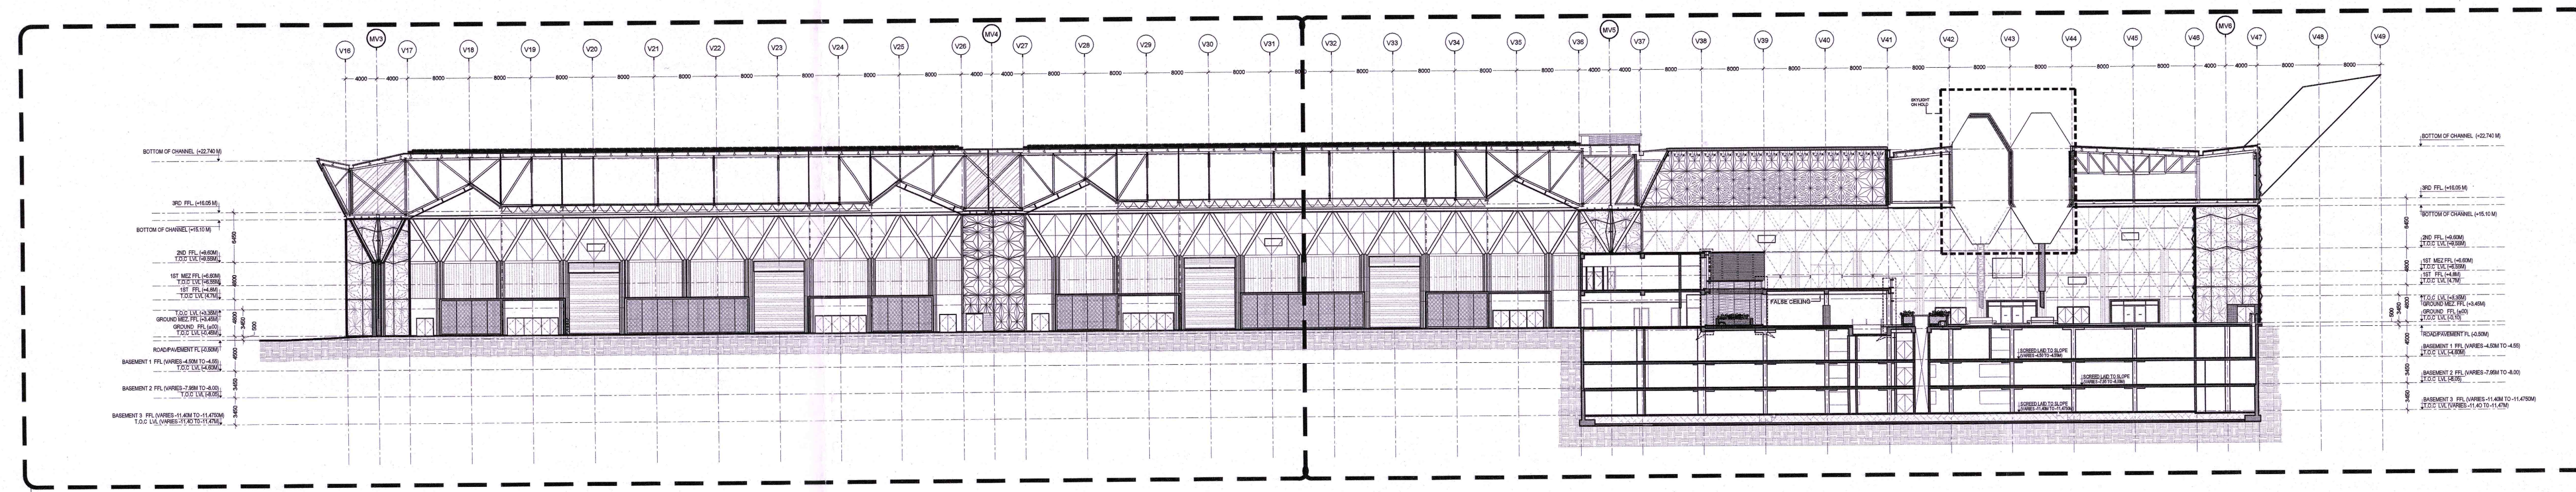


DETAIL-A
SECTION BB'
SCALE 1:300

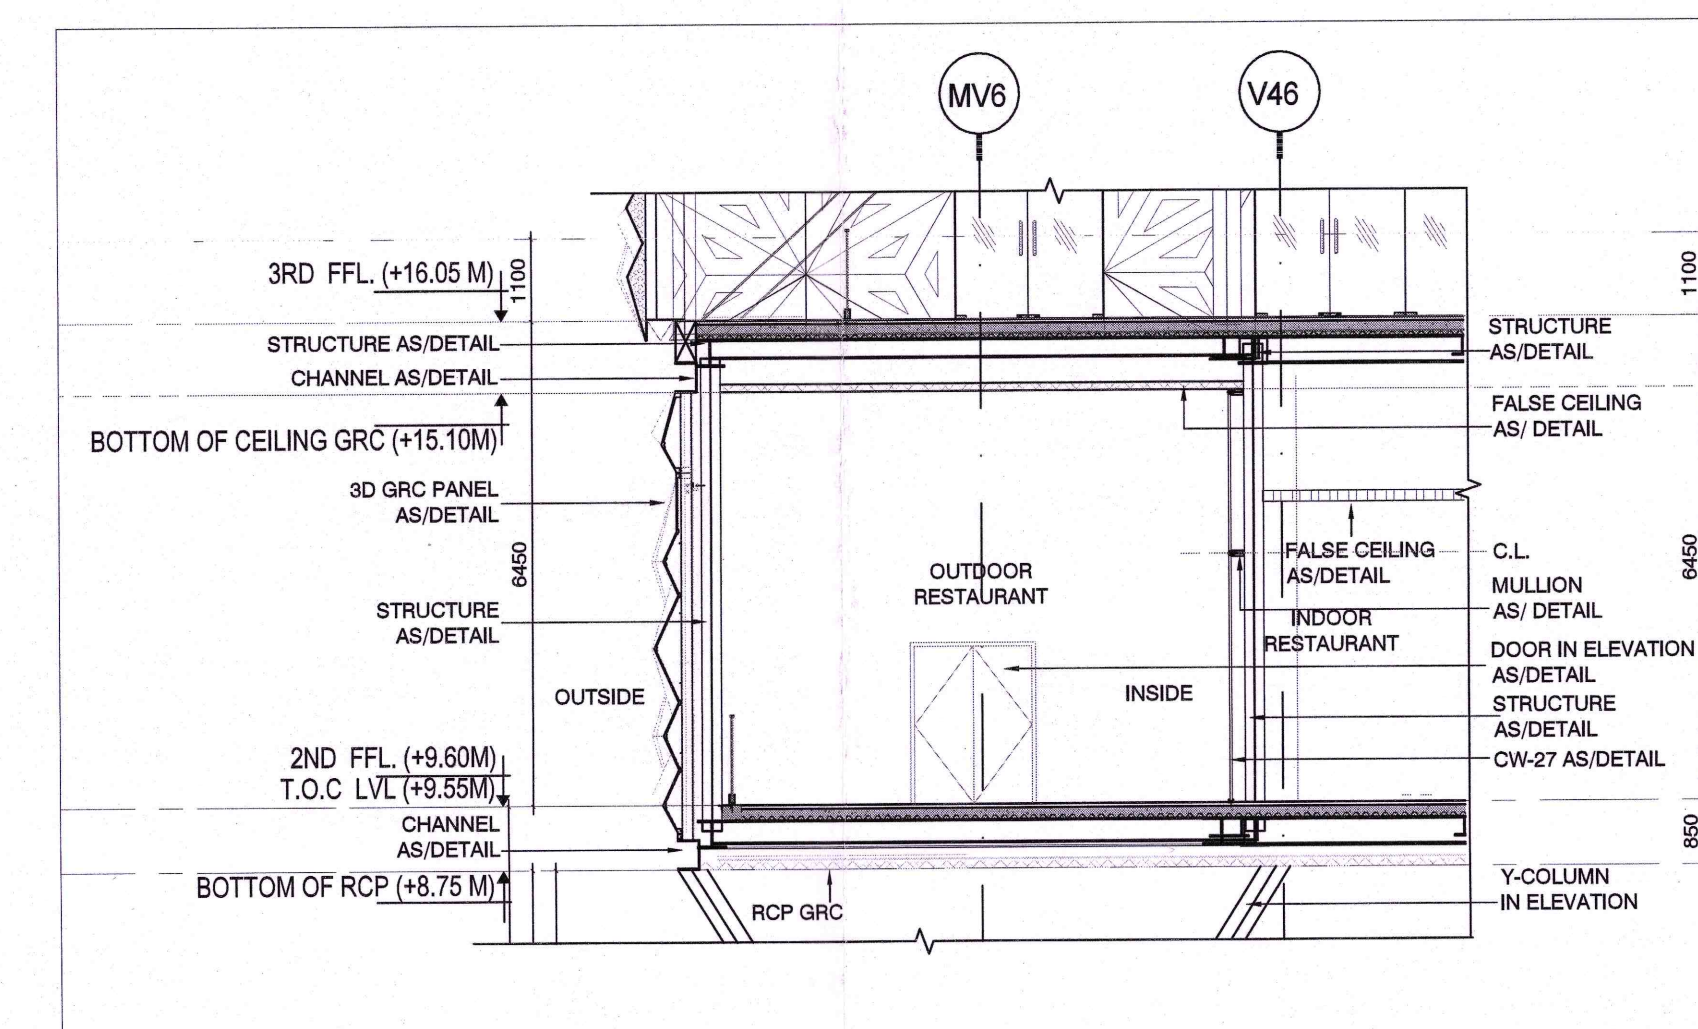

PART SECTION X'
SCALE 1:100

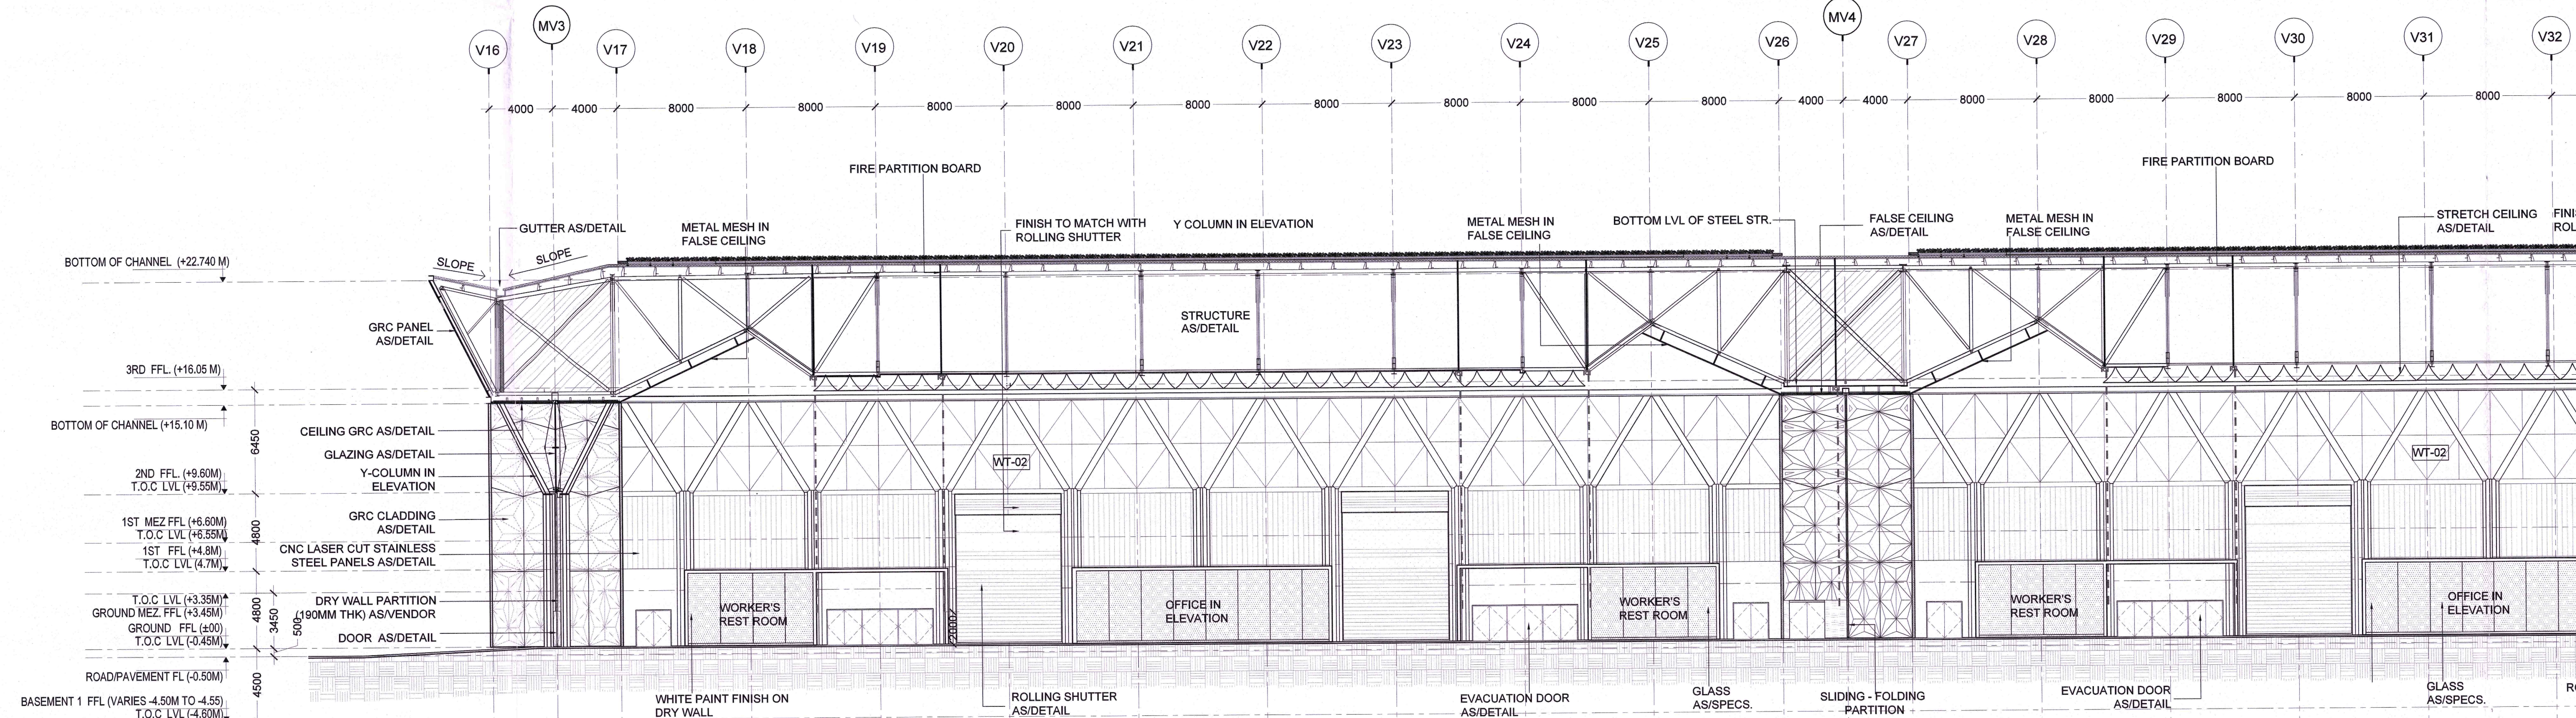

SECTION DETAIL A'
SCALE 1:200

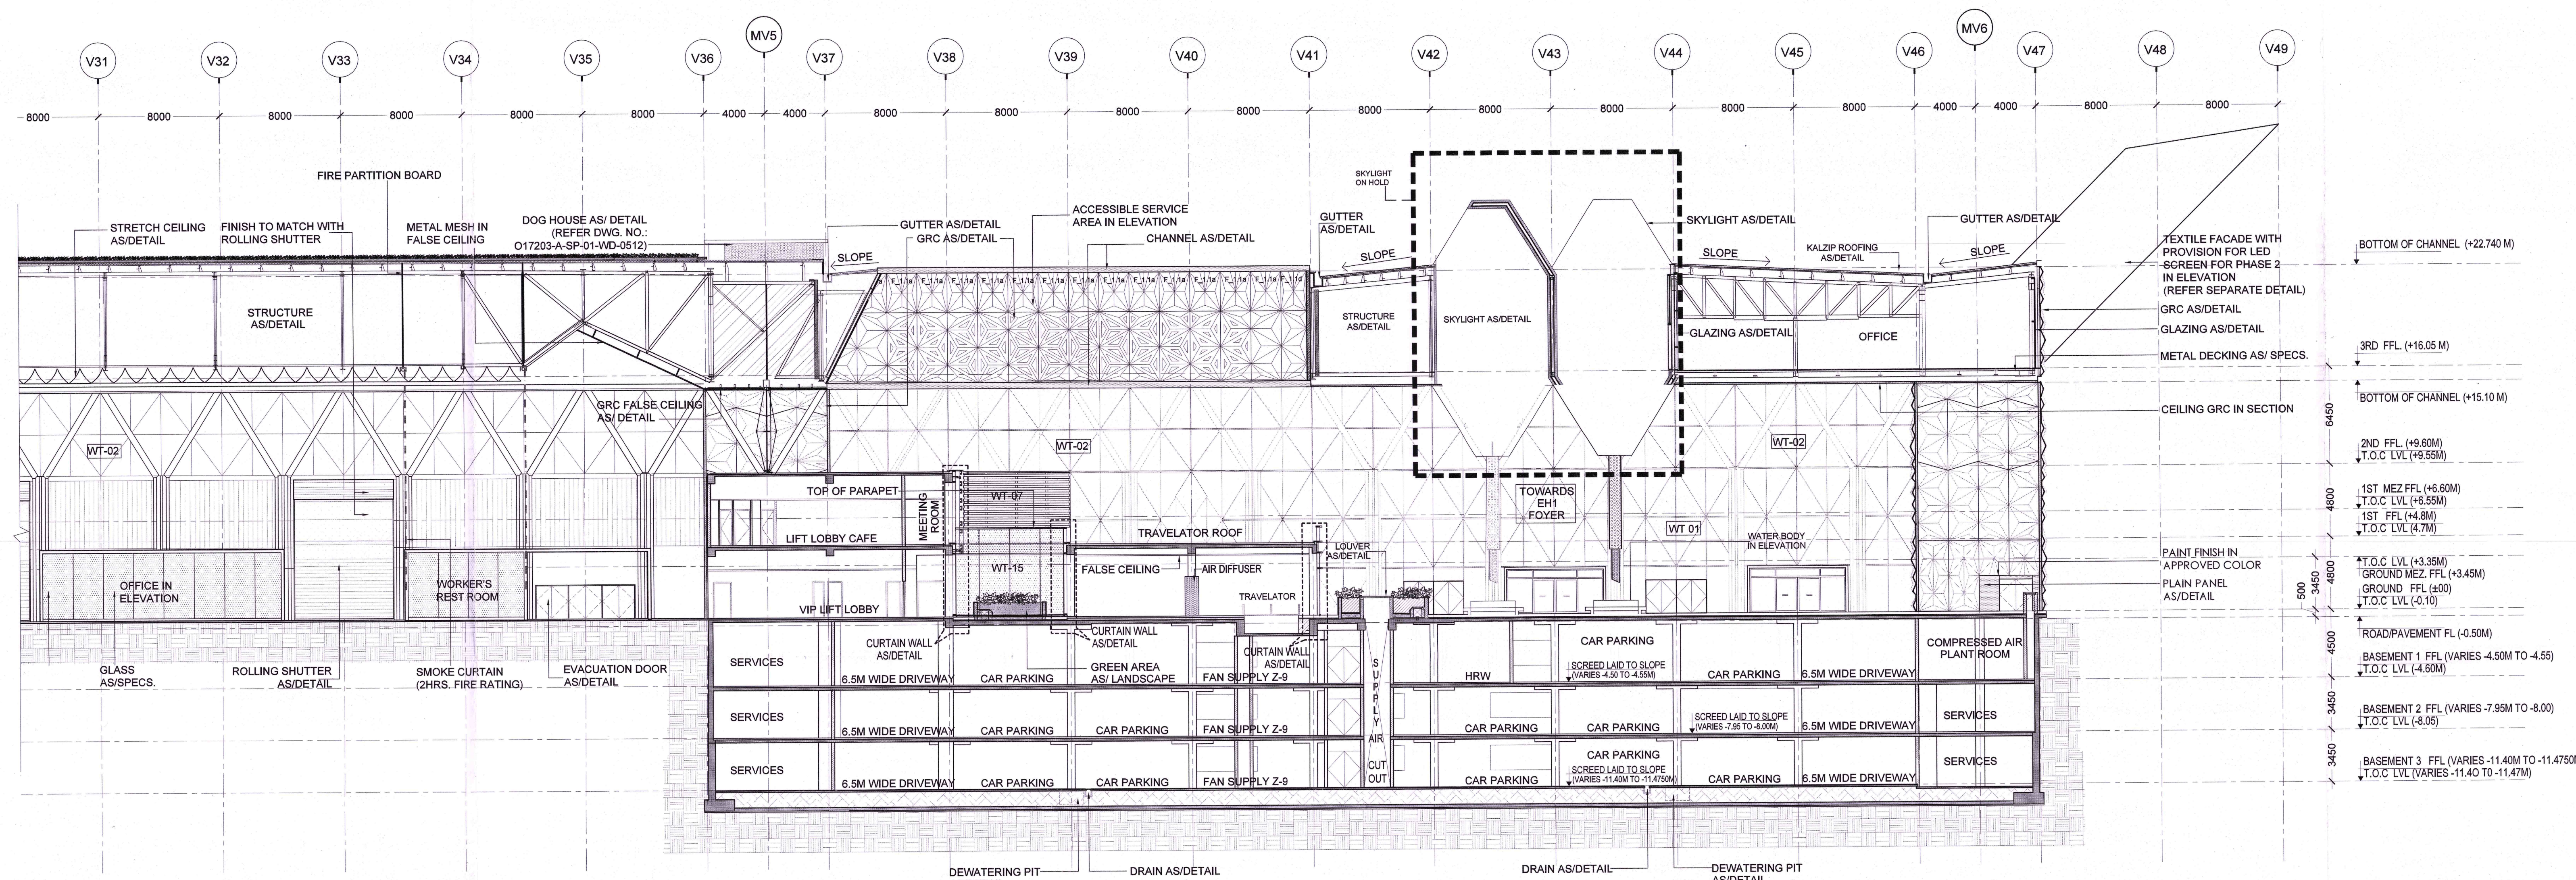

SECTION DETAIL B'
SCALE 1:200

NOTES:

- ALL DIMENSIONS ARE IN MILLIMETERS, LEVELS IN METERS AND ANGLES IN DEGREES UNLESS OTHERWISE NOTED.
- THE DRAWING IS TO BE READ AND NOT TO BE SCALED. ONLY 1/8" DIMENSIONS IN ALL CASES SHALL BE FOLLOWED.
- THE DRAWING SHALL BE READ IN CONJUNCTION WITH ALL RELEVANT ARCHITECTURAL, STRUCTURAL AND SERVICE DRAWINGS.
- ALL DIMENSIONS SHALL BE VERIFIED ON SITE PRIOR TO START OF WORK AND ANY DISCREPANCY SHALL BE BROUGHT TO THE NOTICE OF THE ARCHITECT.
- 0.00 CORRESPONDENCE TO 215.3

- FOR GRC DETAILS, REFER SEPARATE GRC PACKAGE.
- FOR WALL TYPE DETAILS, REFER SEPARATE FACADE PACKAGE.

Wall Types	Description
WT-01	Horizontal Fin System ('X' Bracing start from first level of Aluminium Transom)
WT-02	Tension rod cable system
WT-08	Aluminium Siding with Bronze finish
WT-14	Horizontal Fin System ('X' Bracing start from GROUND FLOOR FFL TO +15.10 LVL)

Plain Panels as/ Specs

ALL FINISH (WT-08, DOOR, ROLLING SHUTTER) WILL BE CAPTURED IN SEPARATE DOCUMENT AFTER GETTING APPROVAL FROM PEAC.

Owner / Employer
India International Convention & Exhibition Centre Limited
Room No. 424, Ministry of Commerce & Industry, DPT, Udyog Bhawan, New Delhi-110011, India
Department of Industrial Policy and Promotion Ministry of Commerce & Industry Government of India

Knowledge Partner
Dahi Mumbai Industrial Corridor Development Corporation
Room No. 301 & 3rd Floor Industrial, Electronic Complex, 30B Chhatrapati New Delhi-110016, India

Employer's Representative
Programme Management Consultant (PMC)
ASCOM
Preliminary Engineering Architectural Consultants (PEAC)
An Delhi Metro Station, 20049 Model, India
New Delhi, Delhi-110016, India

EPC Contractor
L&T Construction
Buildings & Factories
Mount Road, Chennai-600 009, India

Design Consultant
Engineering Design and Research Center (EDRC)
L&T Construction - Buildings & Factories

Architectural Consultant
ARCOP
A-15, Ramana Estate, G.L-1, New Delhi, Delhi-110006, India

Structural Consultant
Indian Institute of Technology (IIT) Madras
Sector Road No. 1, Opposite to C.L.I. Adyar, Chennai, Tamil Nadu-600 025, India

MEP Consultant
Egi India Consulting Engineers Pvt. Ltd.
Plot No. 18, Sector 12, Industrial Area, Opp. Jyoti Sankar, Gurgaon, Haryana-122011, India

ICT Consultant
CRS Consulting Engineers Pvt. Ltd.
4471, 3rd Floor, Haryana Road, Sakinaka, Bangalore-560004, India

Certification
EPC Contractor
Design Consultant
Architectural Consultant
Structural Consultant
MEP Consultant
ICT Consultant
Issued by:
Employer / Employer's Engineer

REV	DESCRIPTION	DATE	SIGN	DRWN	CHD	APPD
1	ISSUED FOR GRC	10/03/2023				
2	REVISIONS					
3	ARCHITECTURE					
4	STRUCTURAL					
5	ELECTRICAL					
6	MECHANICAL					
7	HAZ					
8	CHECKED BY					
9	SIGN					
10	DATE					
11	CHECKED BY					
12	SIGN					
13	DATE					



Project Name

DESIGN AND CONSTRUCTION OF INDIA INTERNATIONAL CONVENTION & EXPO CENTRE

SECTOR 25, DWARKA, NEW DELHI, INDIA

Drawing Status

GOOD FOR CONSTRUCTION

GOOD FOR CONSTRUCTION

Drawing No

A 02 0302 R0

Rev. No

EXHIBITION HALL - 2

SECTION BB

Scale

1:300, 1:200, A0

Sheet No

0302

01/03/2023

0302

0302

0302

0302

0302

0302

0302

0302