

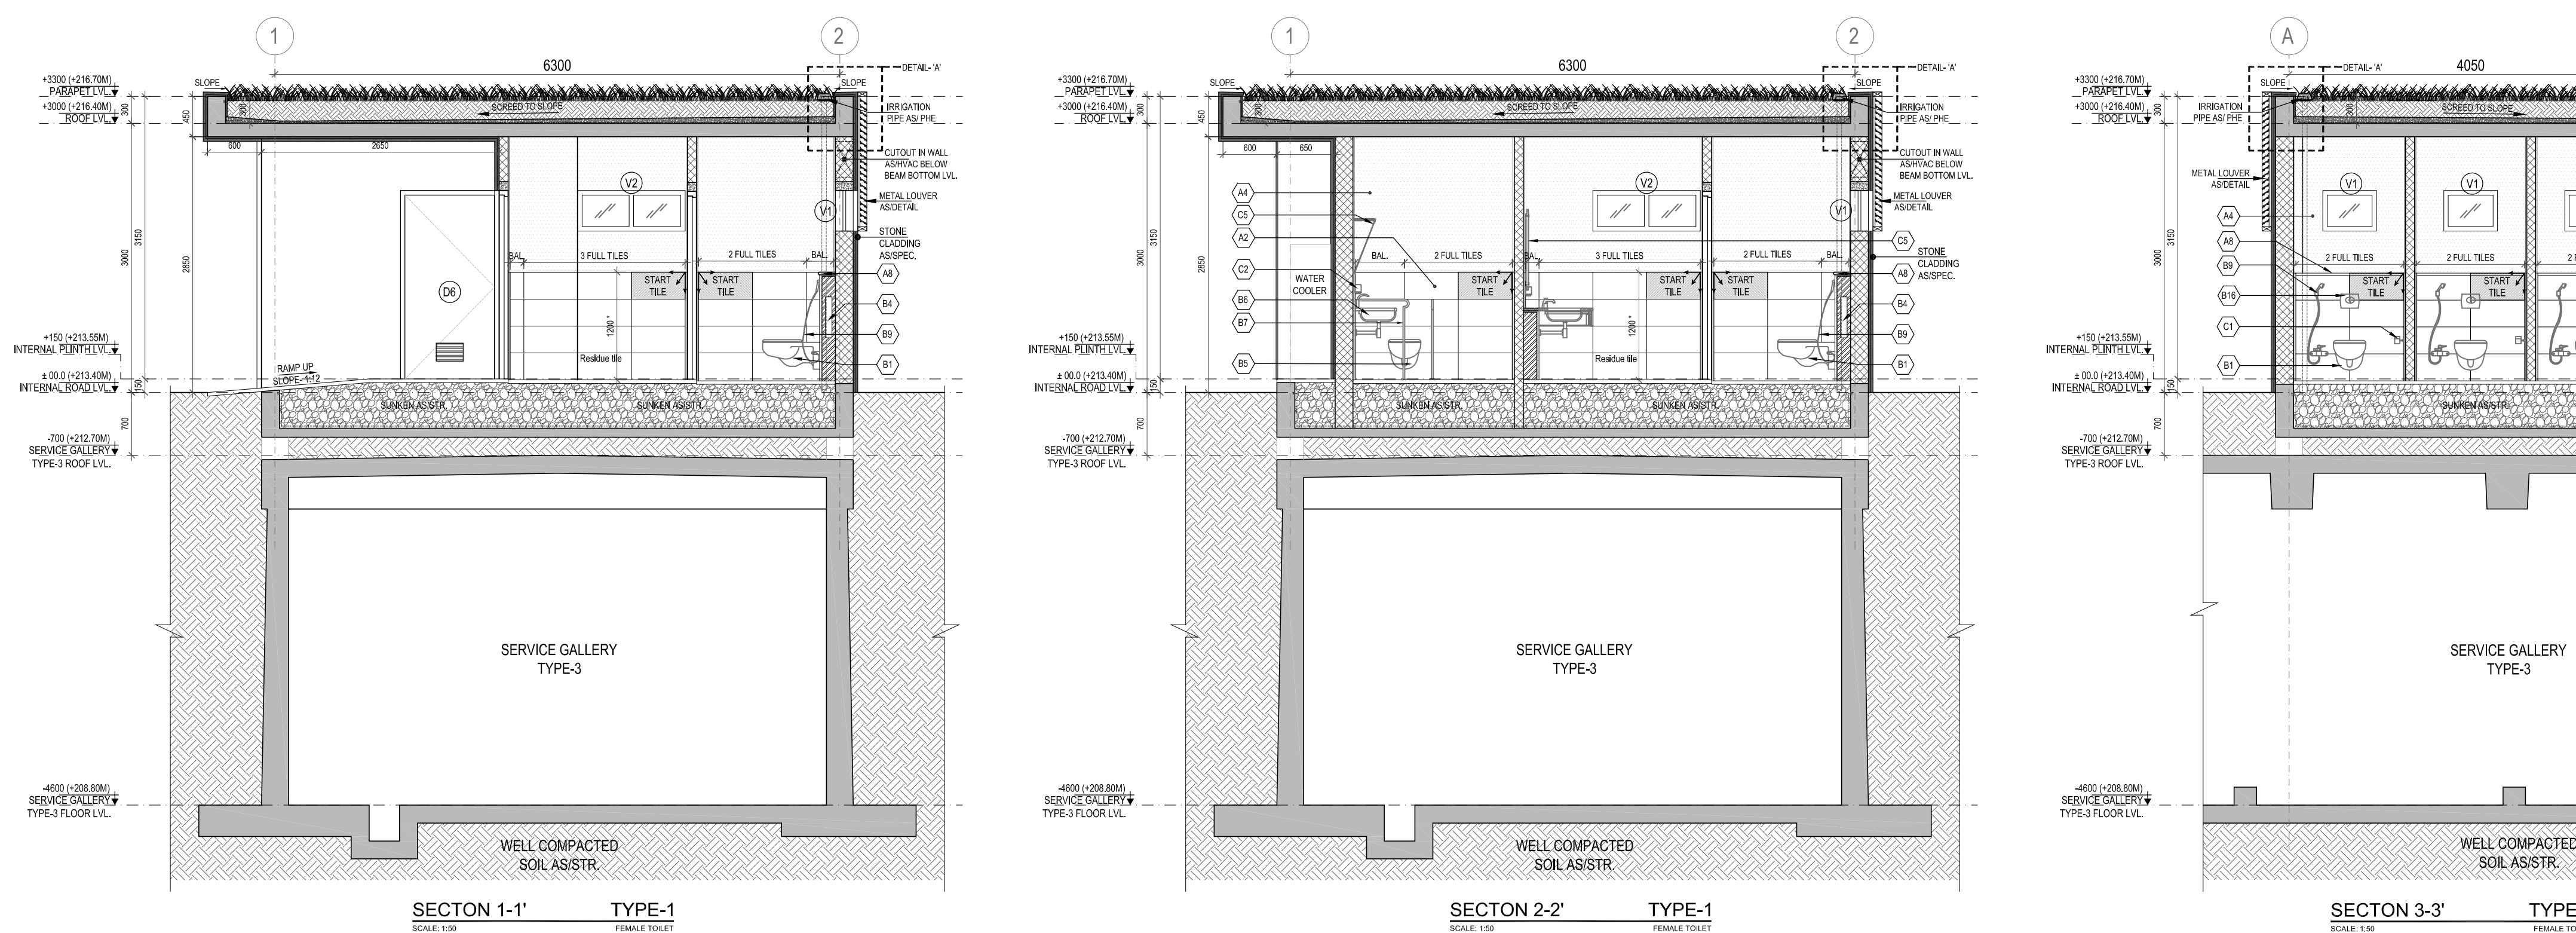


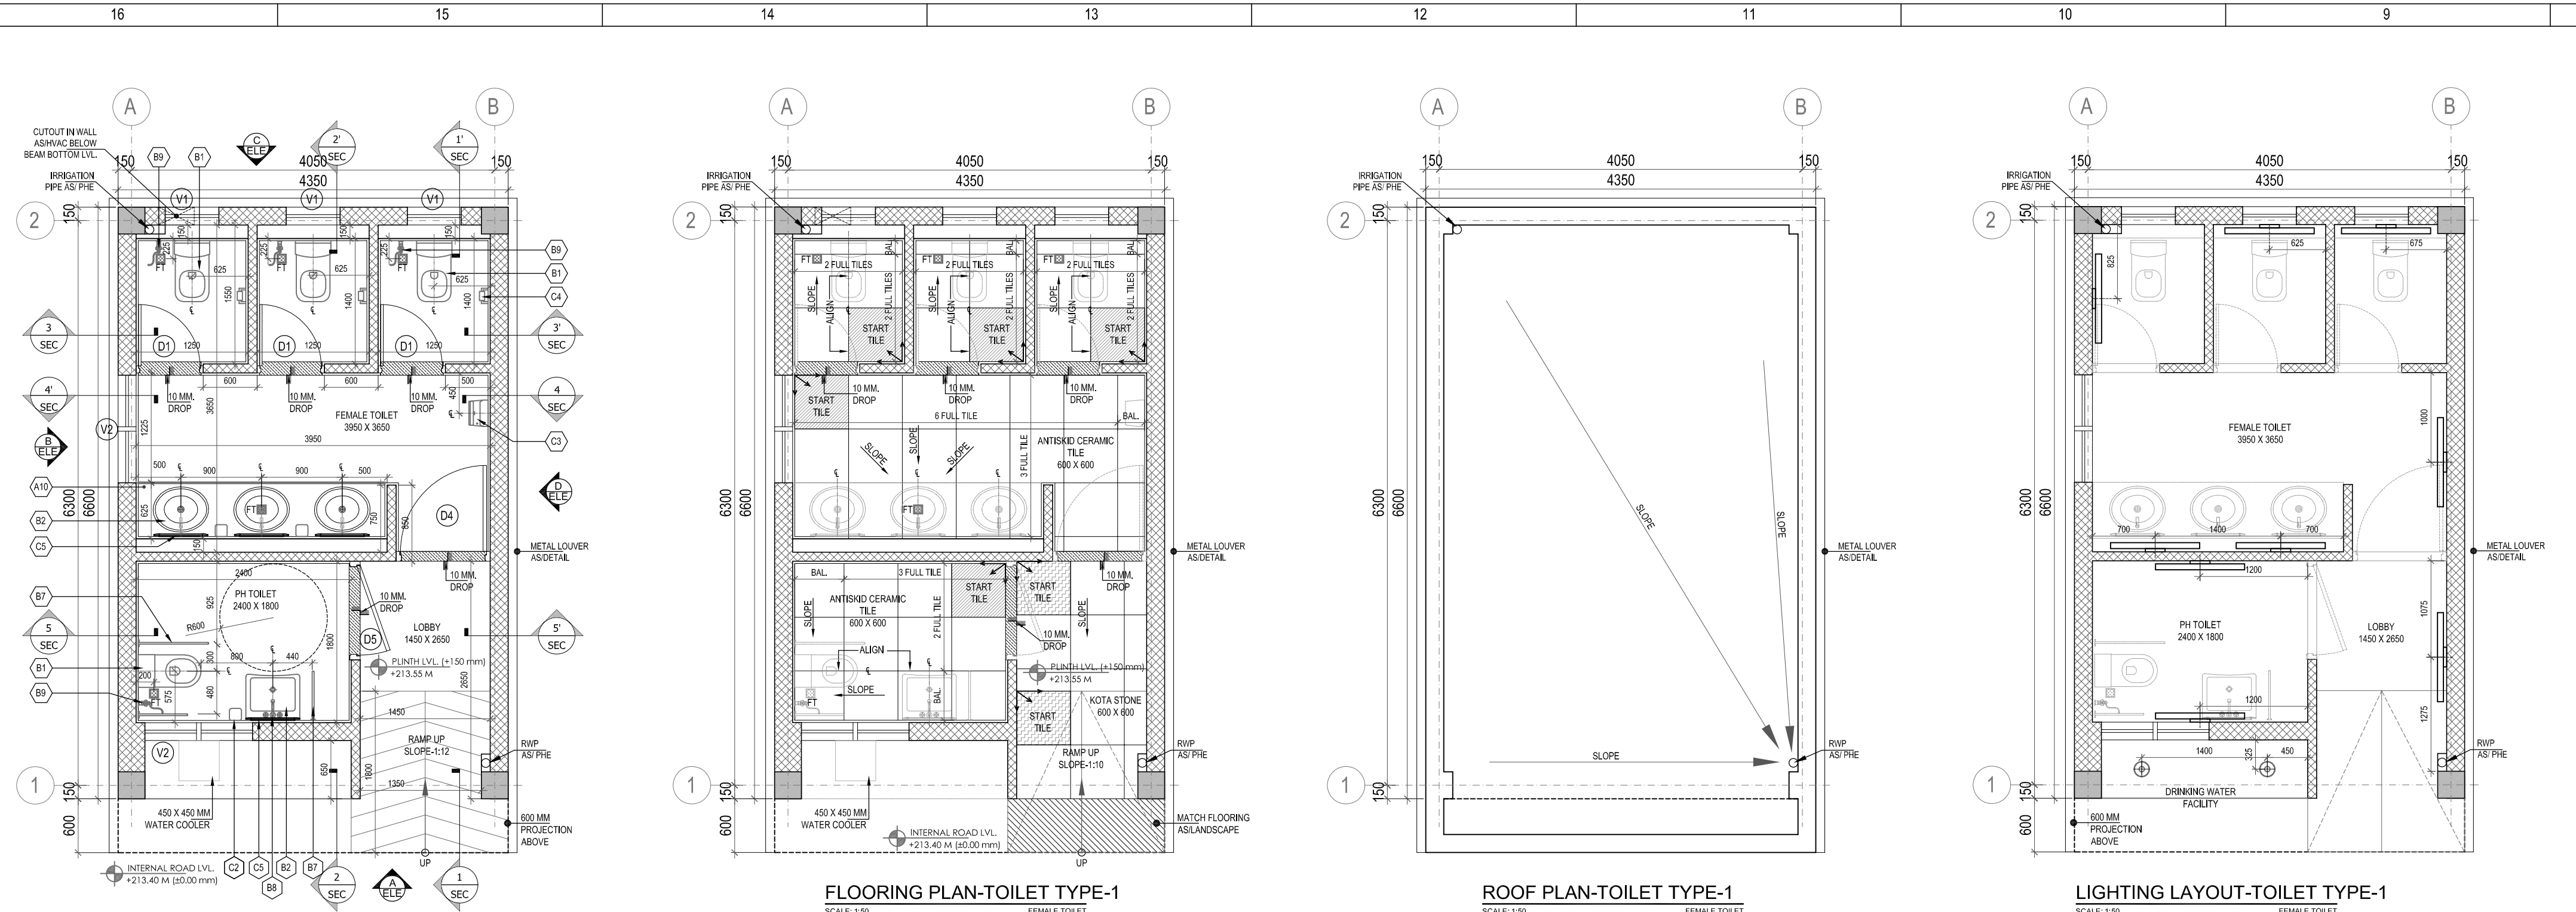

TOILET TYPE-1 MALE & FEMALE (TOILET AT OPEN EXHIBITION AREA) DOOR WINDOW SCHEDULE											
NAME	WIDTH (mm)	WIDTH (mm)	HEIGHT (mm)	HEIGHT (mm)	CILL HT (mm)	UNTEL HT (mm)	WIDTH (mm)	HEIGHT (mm)	CILL HT (mm)	MATERIAL	LOCATION
DOOR											
	FRAME TO FRAME	ROUGH OPENING SIZE	FRAME TO FRAME	ROUGH OPENING SIZE						DOOR LOUVER	
D1	750	780	2100	-	-	2100	300	100	200	WOODEN FRAMED WOODEN FLUSH SHUTTER DOOR WITH LOUVER	TYPE-1 TOILET (MALE & FEMALE)
D4	1050	1080	2100	-	-	2100	650	450	200	WOODEN FRAMED WOODEN FLUSH SHUTTER DOOR WITH LOUVER	TYPE-1 TOILET (MALE)
D4	1050	1080	2100	-	-	2100	450	200	200	WOODEN FRAMED WOODEN FLUSH SHUTTER DOOR WITH LOUVER	TYPE-1 TOILET (FEMALE)
D5	1100	1130	2100	-	-	2100	300	200	200	WOODEN FRAMED WOODEN FLUSH SHUTTER DOOR WITH LOUVER	TYPE-1 TOILET (FEMALE)
VENTILATOR											
V1	600	630	429	450	1650	2100				ALUMINIUM FRAMED GLAZED TOP HUNG VENTILATOR	TYPE-1 TOILET (MALE & FEMALE)
V2	1200	1230	429	450	1650	2100				ALUMINIUM FRAMED GLAZED TOP HUNG VENTILATOR	TYPE-1 TOILET (MALE & FEMALE)

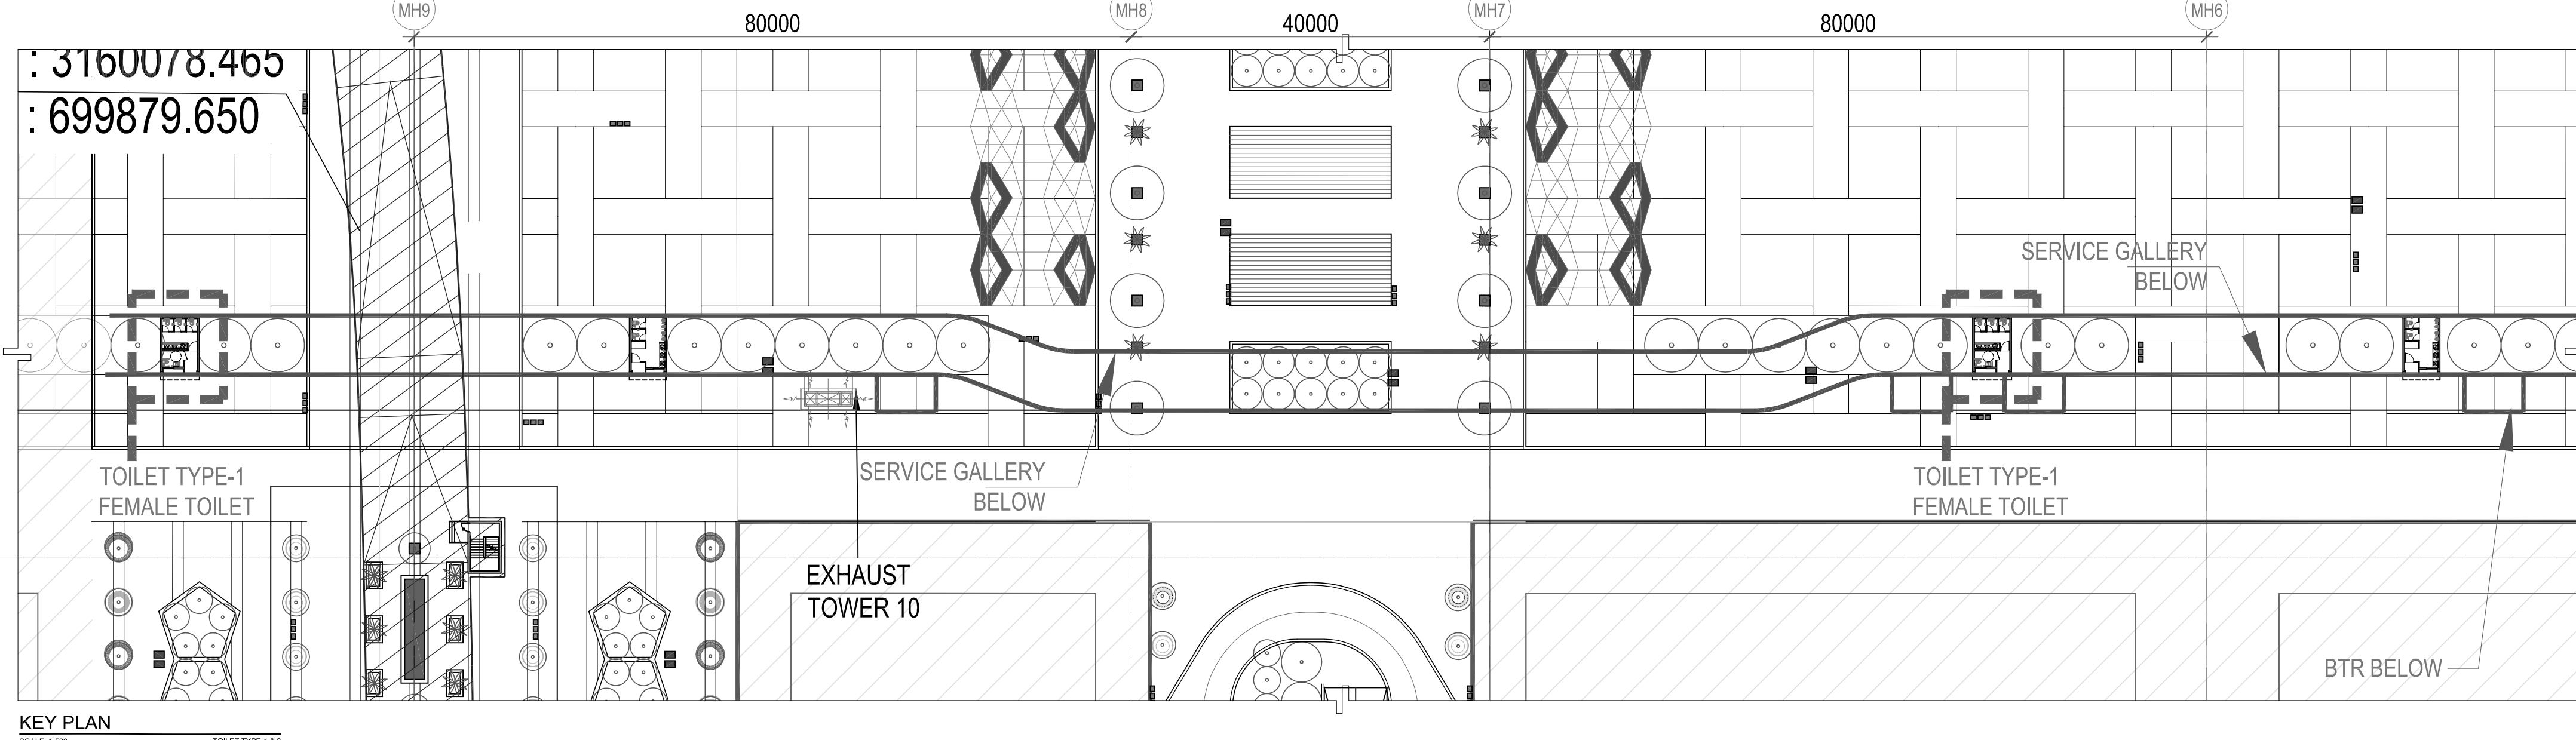

ABBREVIATION:



F.F.L. - FINISHED FLOOR LEVEL
P.L. - FORMED ROAD LEVEL
P.C. - PRE-HOSE CABINET
L.V. - LEVEL
E.L.V. - ELECTRICAL
E.L.V. - EXTRA LOW VOLTAGE
M.H. - 400 MM DIA. MANHOLE UNIT
P.H.E. - PUBLIC HEALTH ENGINEERING

NOTES:


- ALL DIMENSIONS ARE IN MILLIMETERS. LEVELS IN METERS AND ANGLES IN DEGREES UNLESS OTHERWISE NOTED.
- THE DRAWING IS TO BE READ AND NOT TO BE SCALED. ONLY WRITTEN DIMENSIONS IN ALL CASES SHALL BE FOLLOWED.
- THE DRAWING SHALL BE READ IN CONJUNCTION WITH ALL RELEVANT ARCHITECTURAL, STRUCTURAL AND SERVICE DRAWINGS.
- ALL DIMENSIONS SHALL BE VERIFIED ON SITE PRIOR TO START OF WORK AND ANY DISCREPANCY SHALL BE BROUGHT TO THE NOTICE OF THE ARCHITECT.
- READ THE DRAWING IN CONJUNCTION WITH SITE PLAN, DWG NO. 017203-A-SP-00-00-0003
- PLUMBING FIXTURES, RAINWATER PIPE / LIGHT LOCATIONS ARE INDICATIVE ONLY FOR EXACT LOCATION AND NUMBERS REFER MEP DRG.

*** DIMENSION VARIES. BOTTOM TILE IS RESIDUE TILE**

FOR SUNKEN DETAIL REFER STRUCTURAL DRAWINGS.

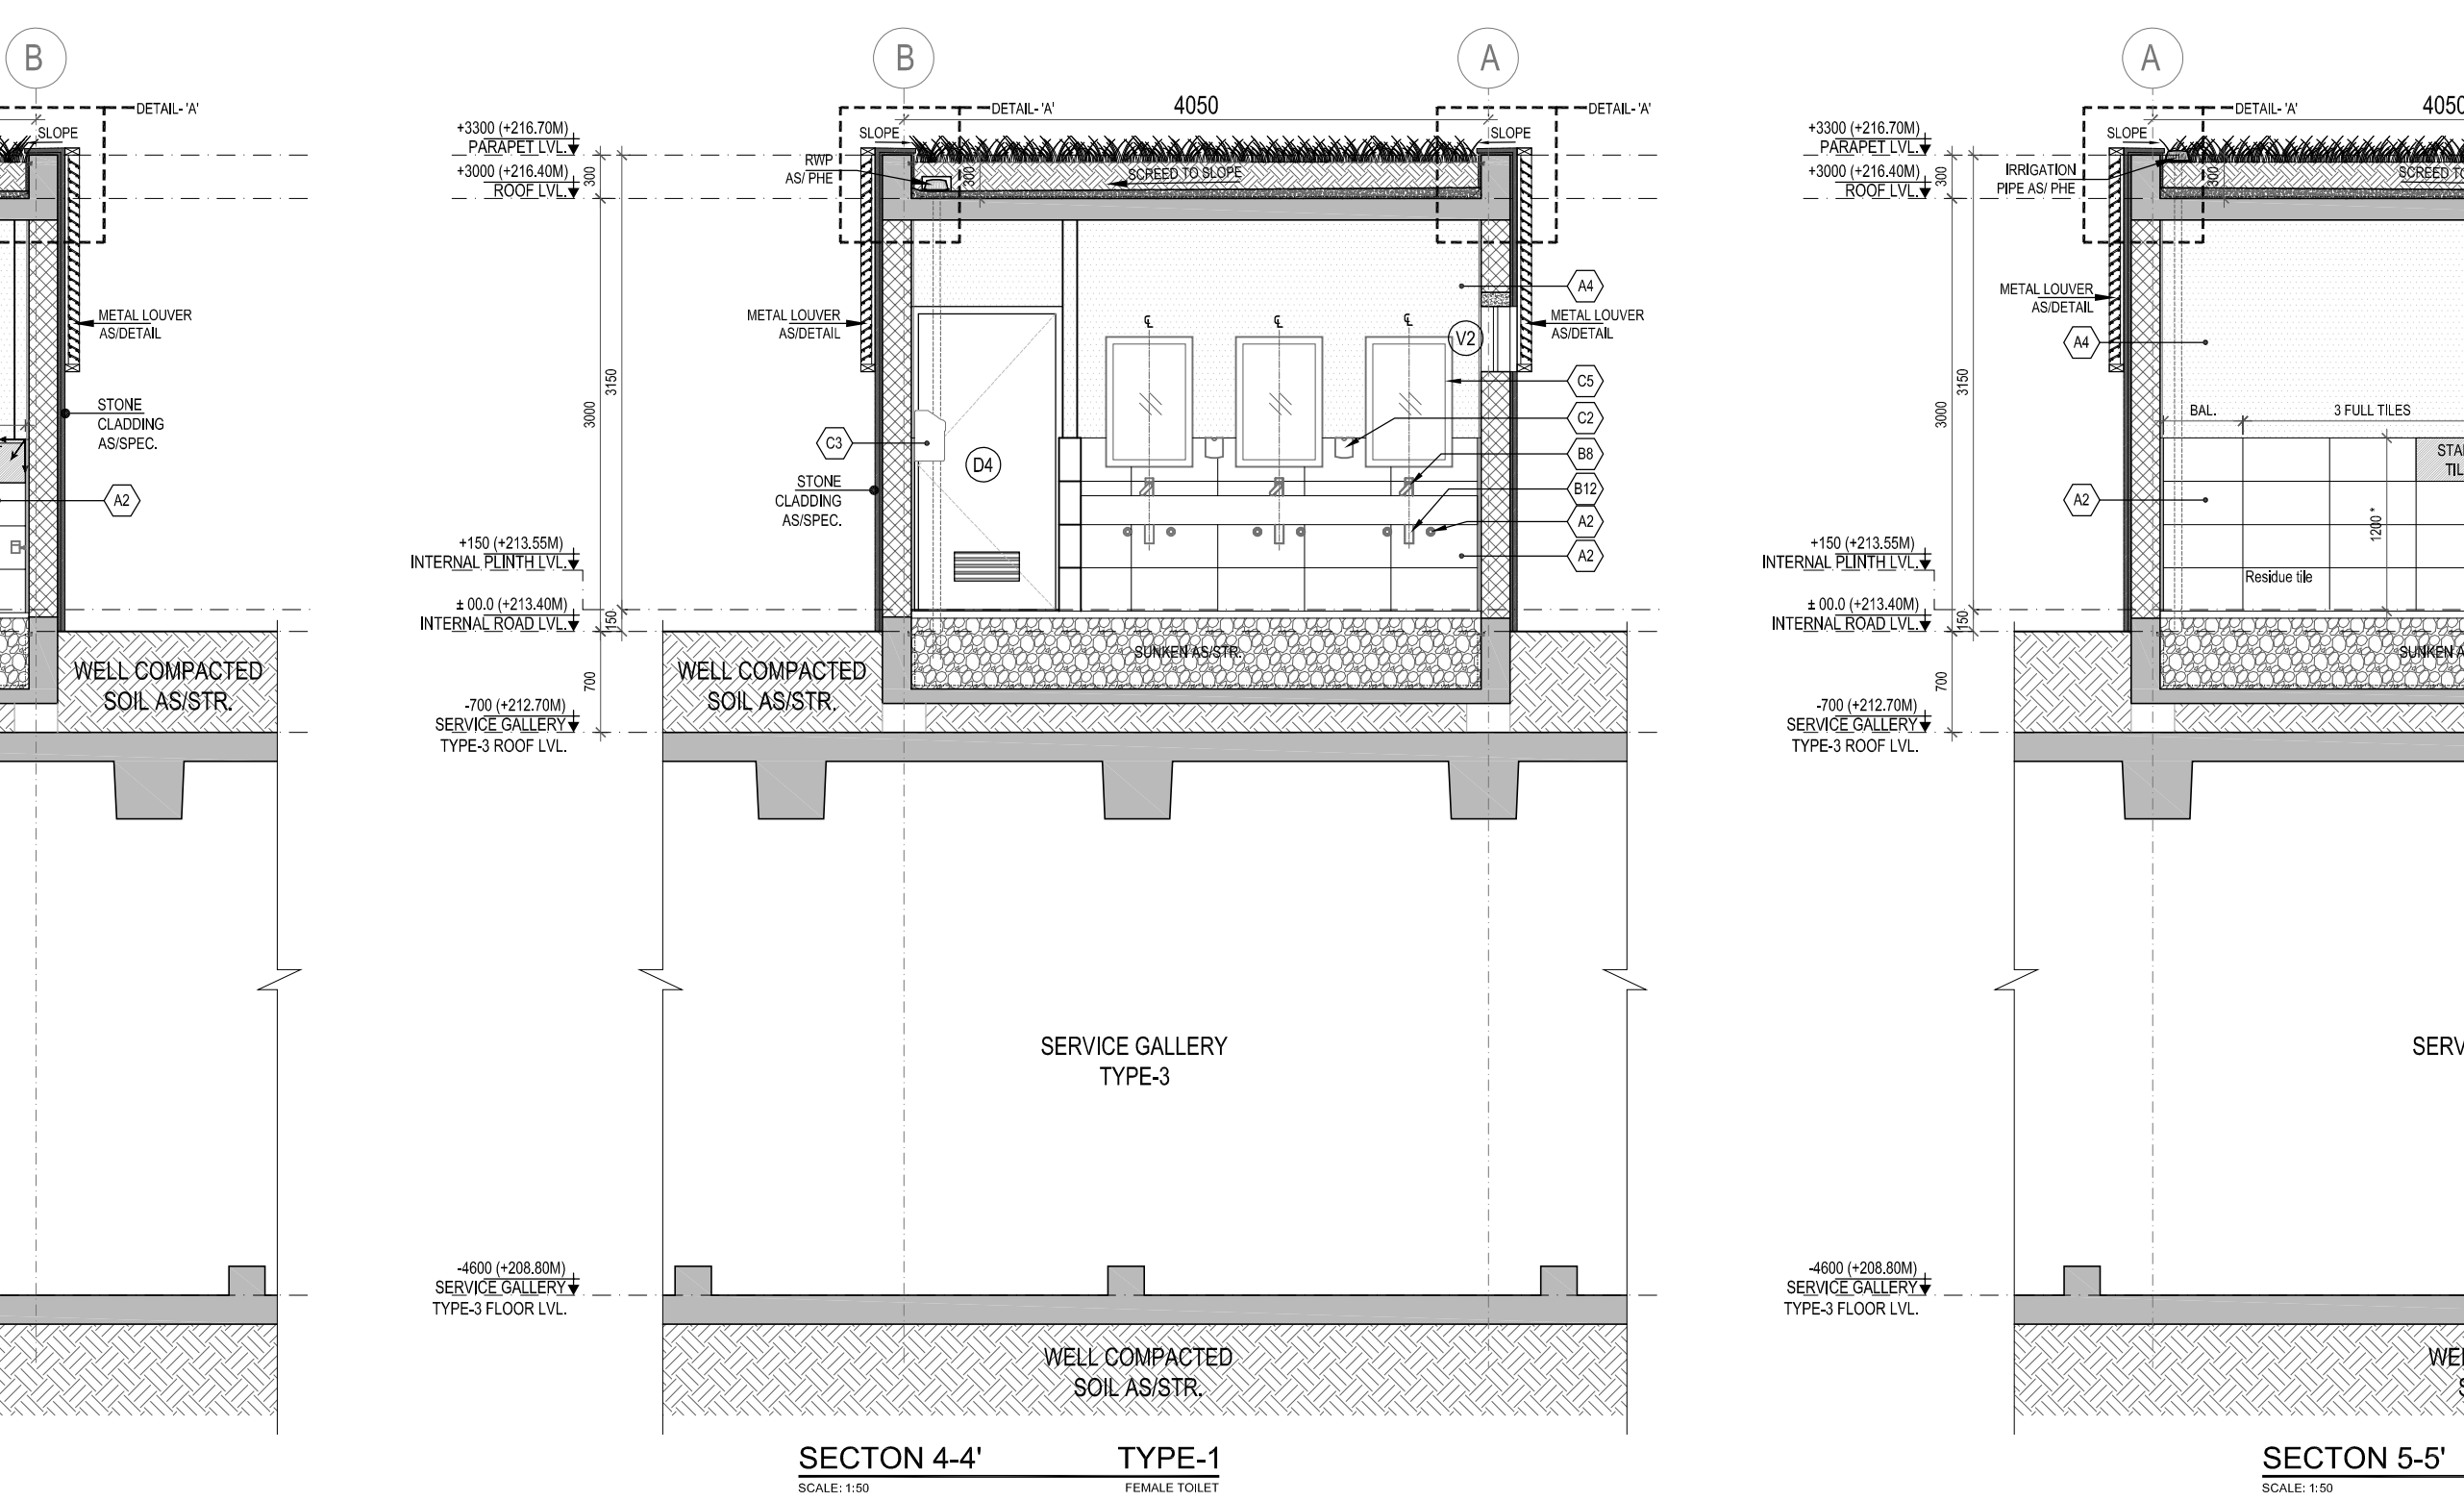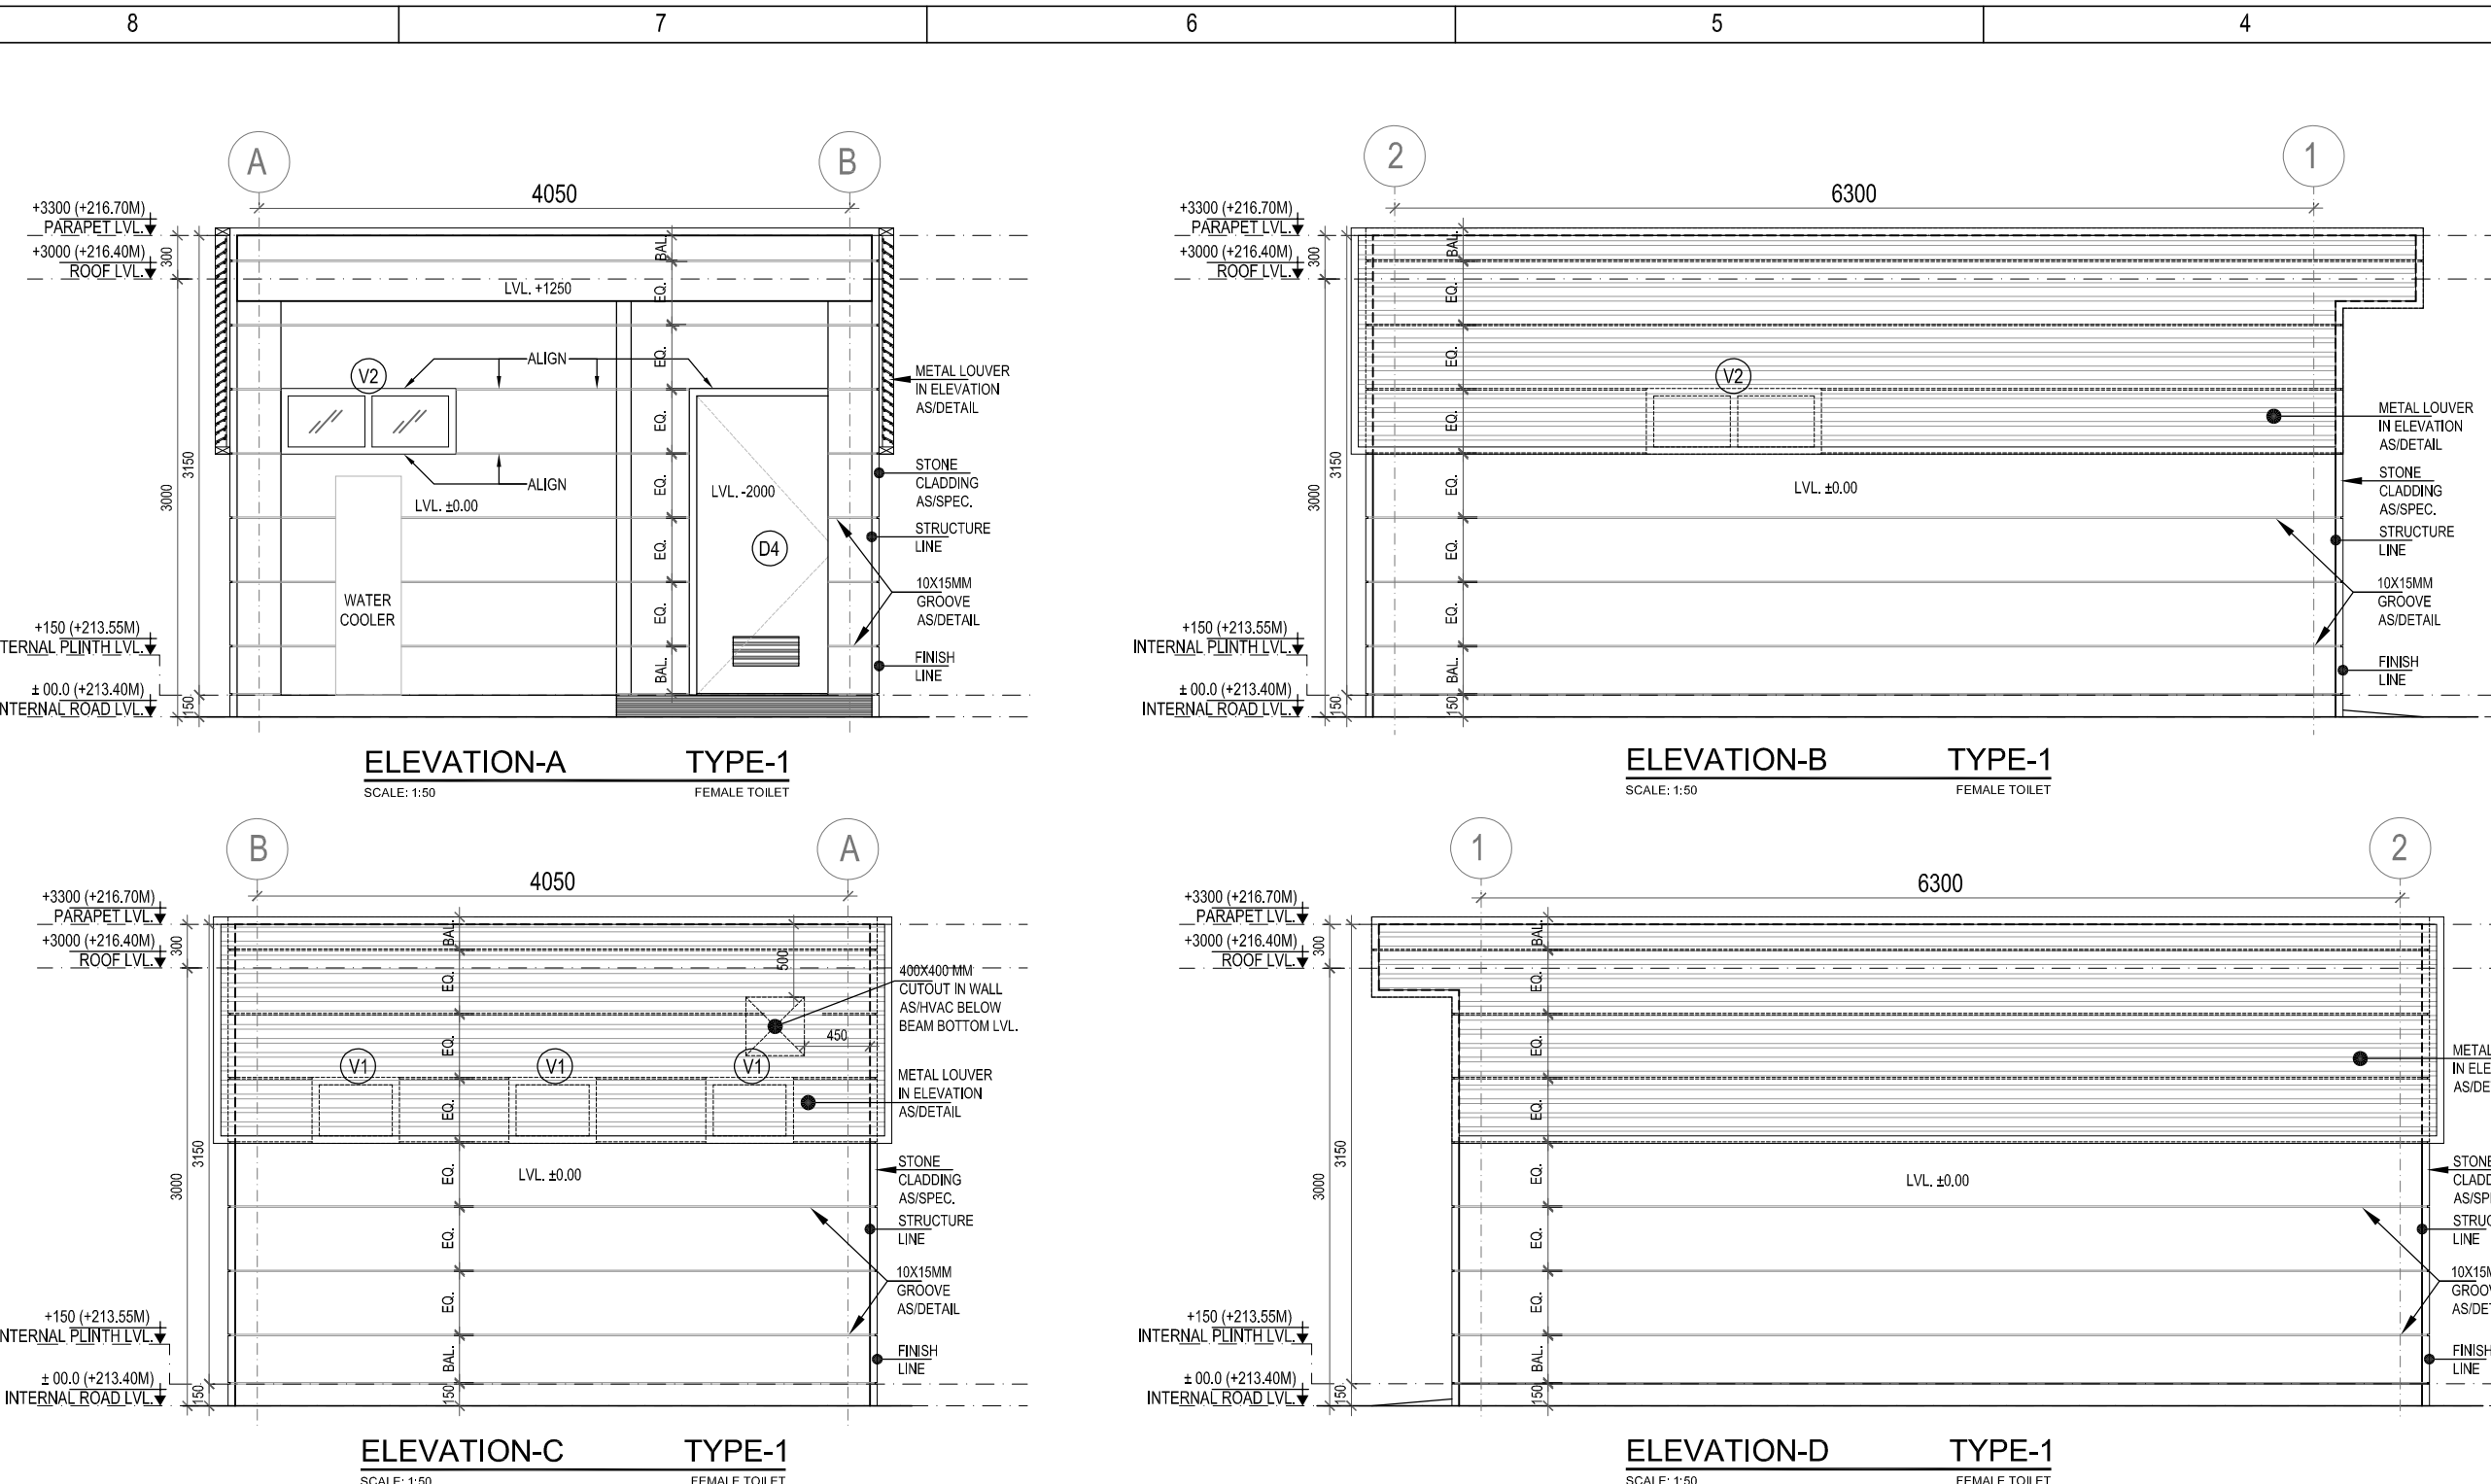

TOILET TYPE-1 MALE & FEMALE (TOILET AT OPEN EXHIBITION AREA) DOOR WINDOW SCHEDULE											
NAME	WIDTH (mm)	WIDTH (mm)	HEIGHT (mm)	HEIGHT (mm)	CILL HT (mm)	UNTEL HT (mm)	WIDTH (mm)	HEIGHT (mm)	CILL HT (mm)	MATERIAL	LOCATION
DOOR											
	FRAME TO FRAME	ROUGH OPENING SIZE	FRAME TO FRAME	ROUGH OPENING SIZE						DOOR LOUVER	
D1	750	780	2100	-	-	2100	300	100	200	WOODEN FRAMED WOODEN FLUSH SHUTTER DOOR WITH LOUVER	TYPE-1 TOILET (MALE & FEMALE)
D4	1050	1080	2100	-	-	2100	650	450	200	WOODEN FRAMED WOODEN FLUSH SHUTTER DOOR WITH LOUVER	TYPE-1 TOILET (MALE)
D4	1050	1080	2100	-	-	2100	450	200	200	WOODEN FRAMED WOODEN FLUSH SHUTTER DOOR WITH LOUVER	TYPE-1 TOILET (FEMALE)
D5	1100	1130	2100	-	-	2100	300	200	200	WOODEN FRAMED WOODEN FLUSH SHUTTER DOOR WITH LOUVER	TYPE-1 TOILET (FEMALE)
VENTILATOR											
V1	600	630	429	450	1650	2100				ALUMINIUM FRAMED GLAZED TOP HUNG VENTILATOR	TYPE-1 TOILET (MALE & FEMALE)
V2	1200	1230	429	450	1650	2100				ALUMINIUM FRAMED GLAZED TOP HUNG VENTILATOR	TYPE-1 TOILET (MALE & FEMALE)

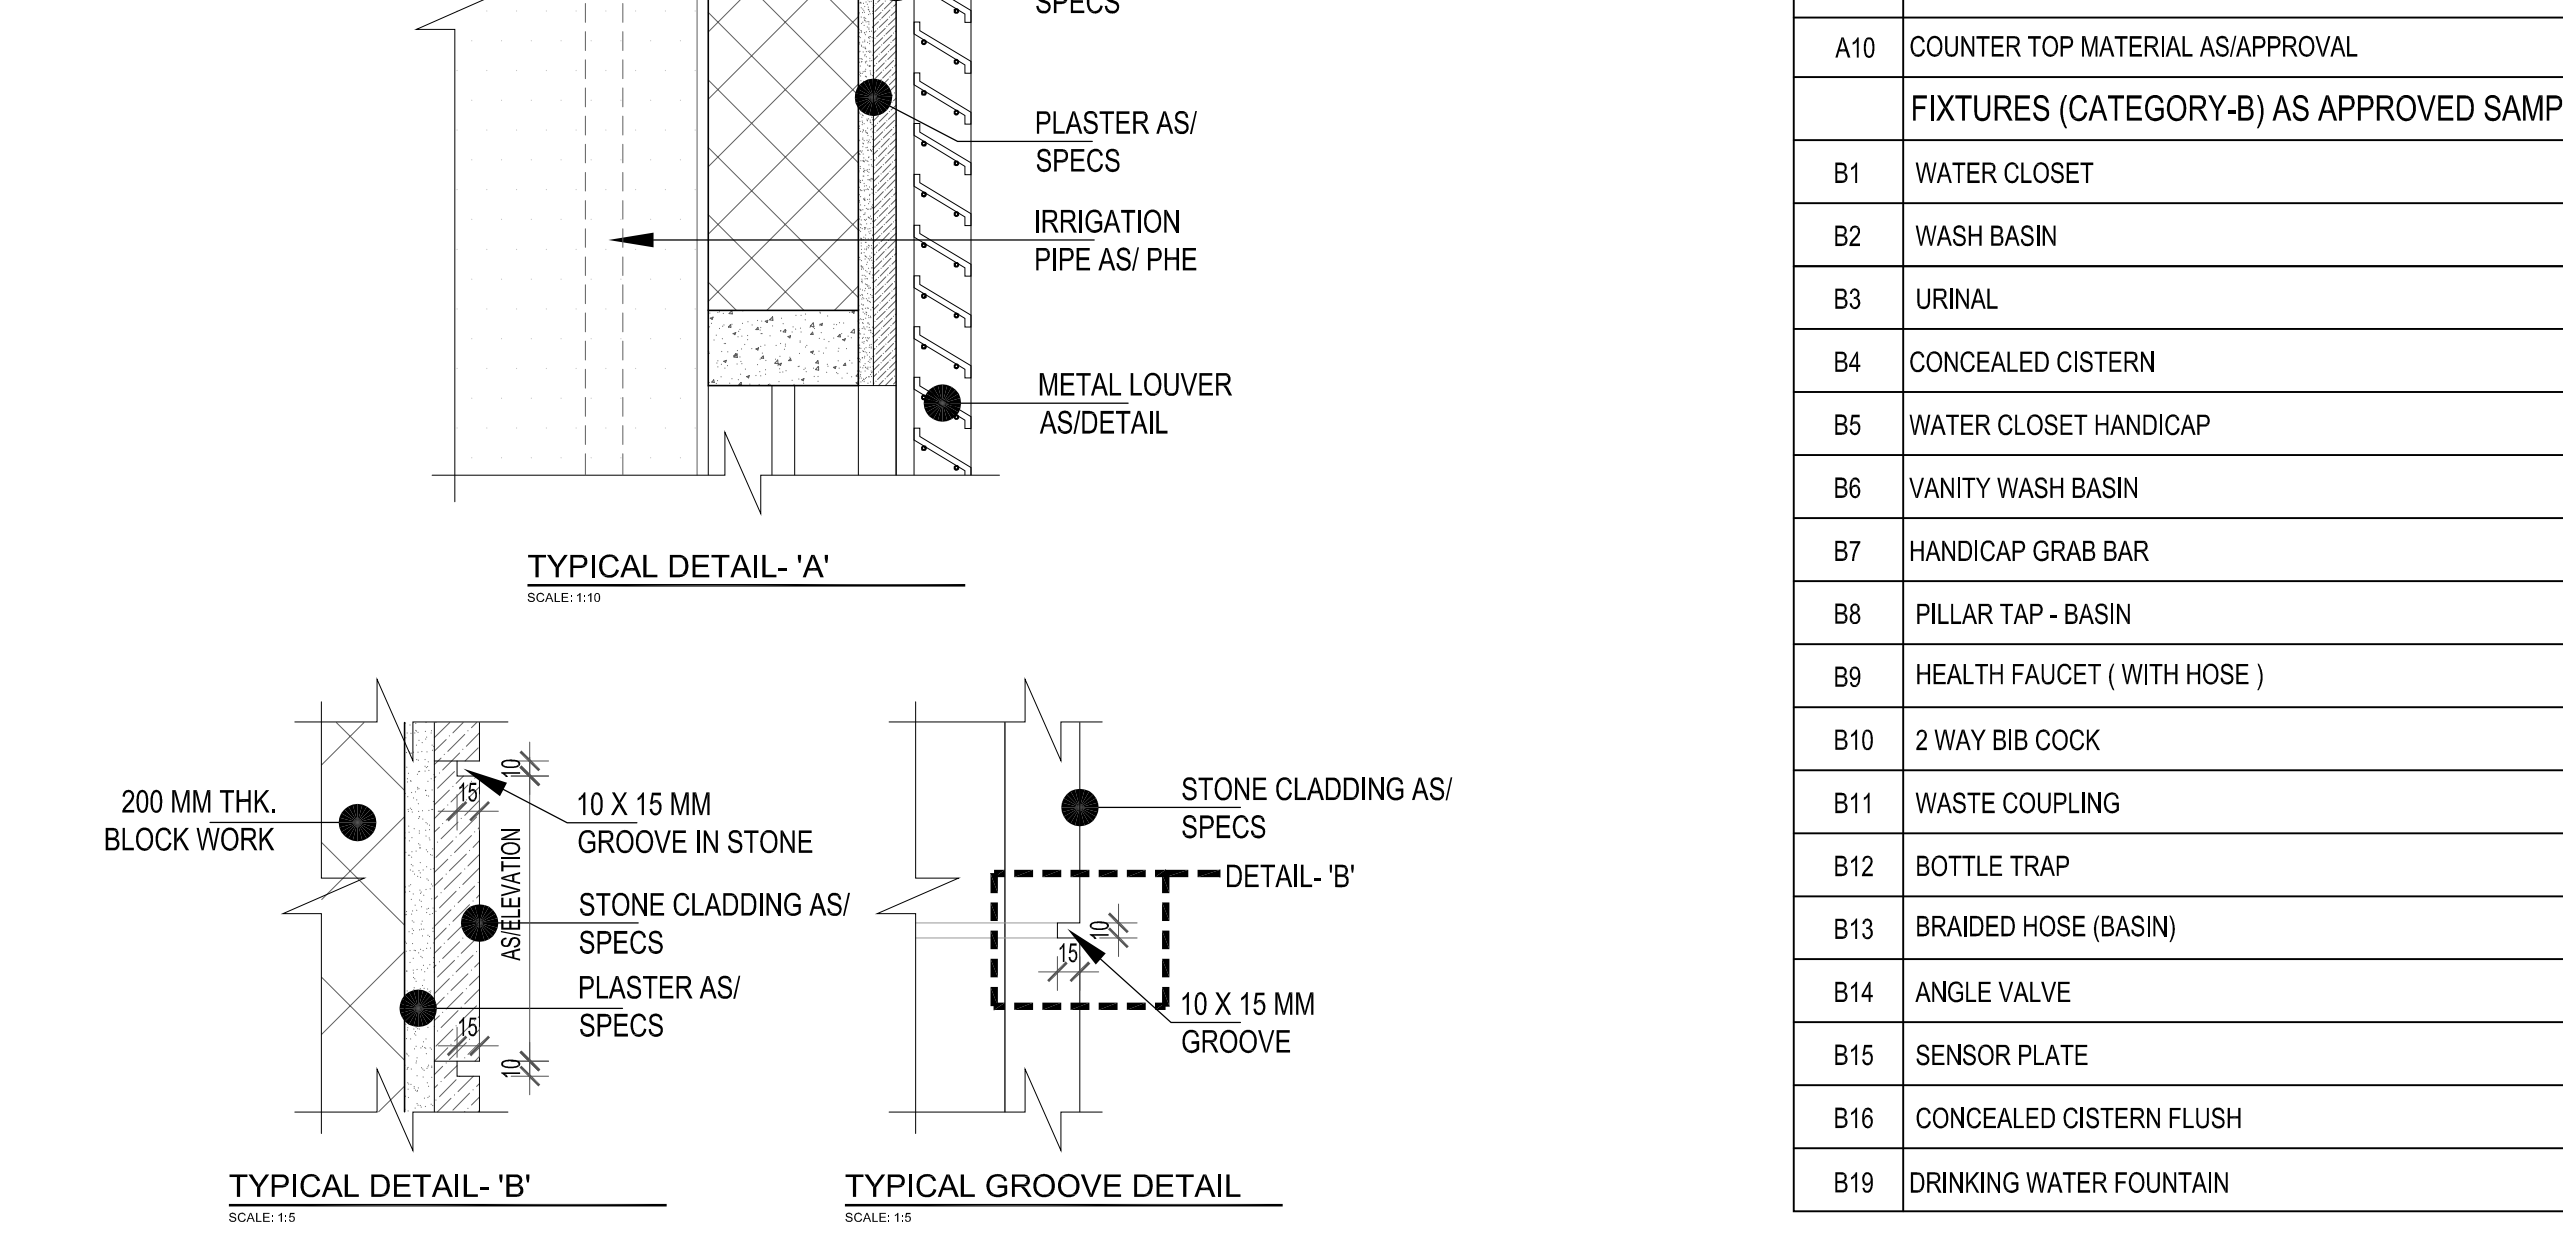

ABBREVIATION:



F.F.L. - FINISHED FLOOR LEVEL
P.L. - FORMED ROAD LEVEL
P.C. - PRE-HOSE CABINET
L.V. - LEVEL
E.L.V. - ELECTRICAL
E.L.V. - EXTRA LOW VOLTAGE
M.H. - 400 MM DIA. MANHOLE UNIT
P.H.E. - PUBLIC HEALTH ENGINEERING

NOTES:

- ALL DIMENSIONS ARE IN MILLIMETERS. LEVELS IN METERS AND ANGLES IN DEGREES UNLESS OTHERWISE NOTED.
- THE DRAWING IS TO BE READ AND NOT TO BE SCALED. ONLY WRITTEN DIMENSIONS IN ALL CASES SHALL BE FOLLOWED.
- THE DRAWING SHALL BE READ IN CONJUNCTION WITH ALL RELEVANT ARCHITECTURAL, STRUCTURAL AND SERVICE DRAWINGS.
- ALL DIMENSIONS SHALL BE VERIFIED ON SITE PRIOR TO START OF WORK AND ANY DISCREPANCY SHALL BE BROUGHT TO THE NOTICE OF THE ARCHITECT.
- READ THE DRAWING IN CONJUNCTION WITH SITE PLAN, DWG NO. 017203-A-SP-00-00-0003
- PLUMBING FIXTURES, RAINWATER PIPE / LIGHT LOCATIONS ARE INDICATIVE ONLY FOR EXACT LOCATION AND NUMBERS REFER MEP DRG.

*** DIMENSION VARIES. BOTTOM TILE IS RESIDUE TILE**

FOR SUNKEN DETAIL REFER STRUCTURAL DRAWINGS.

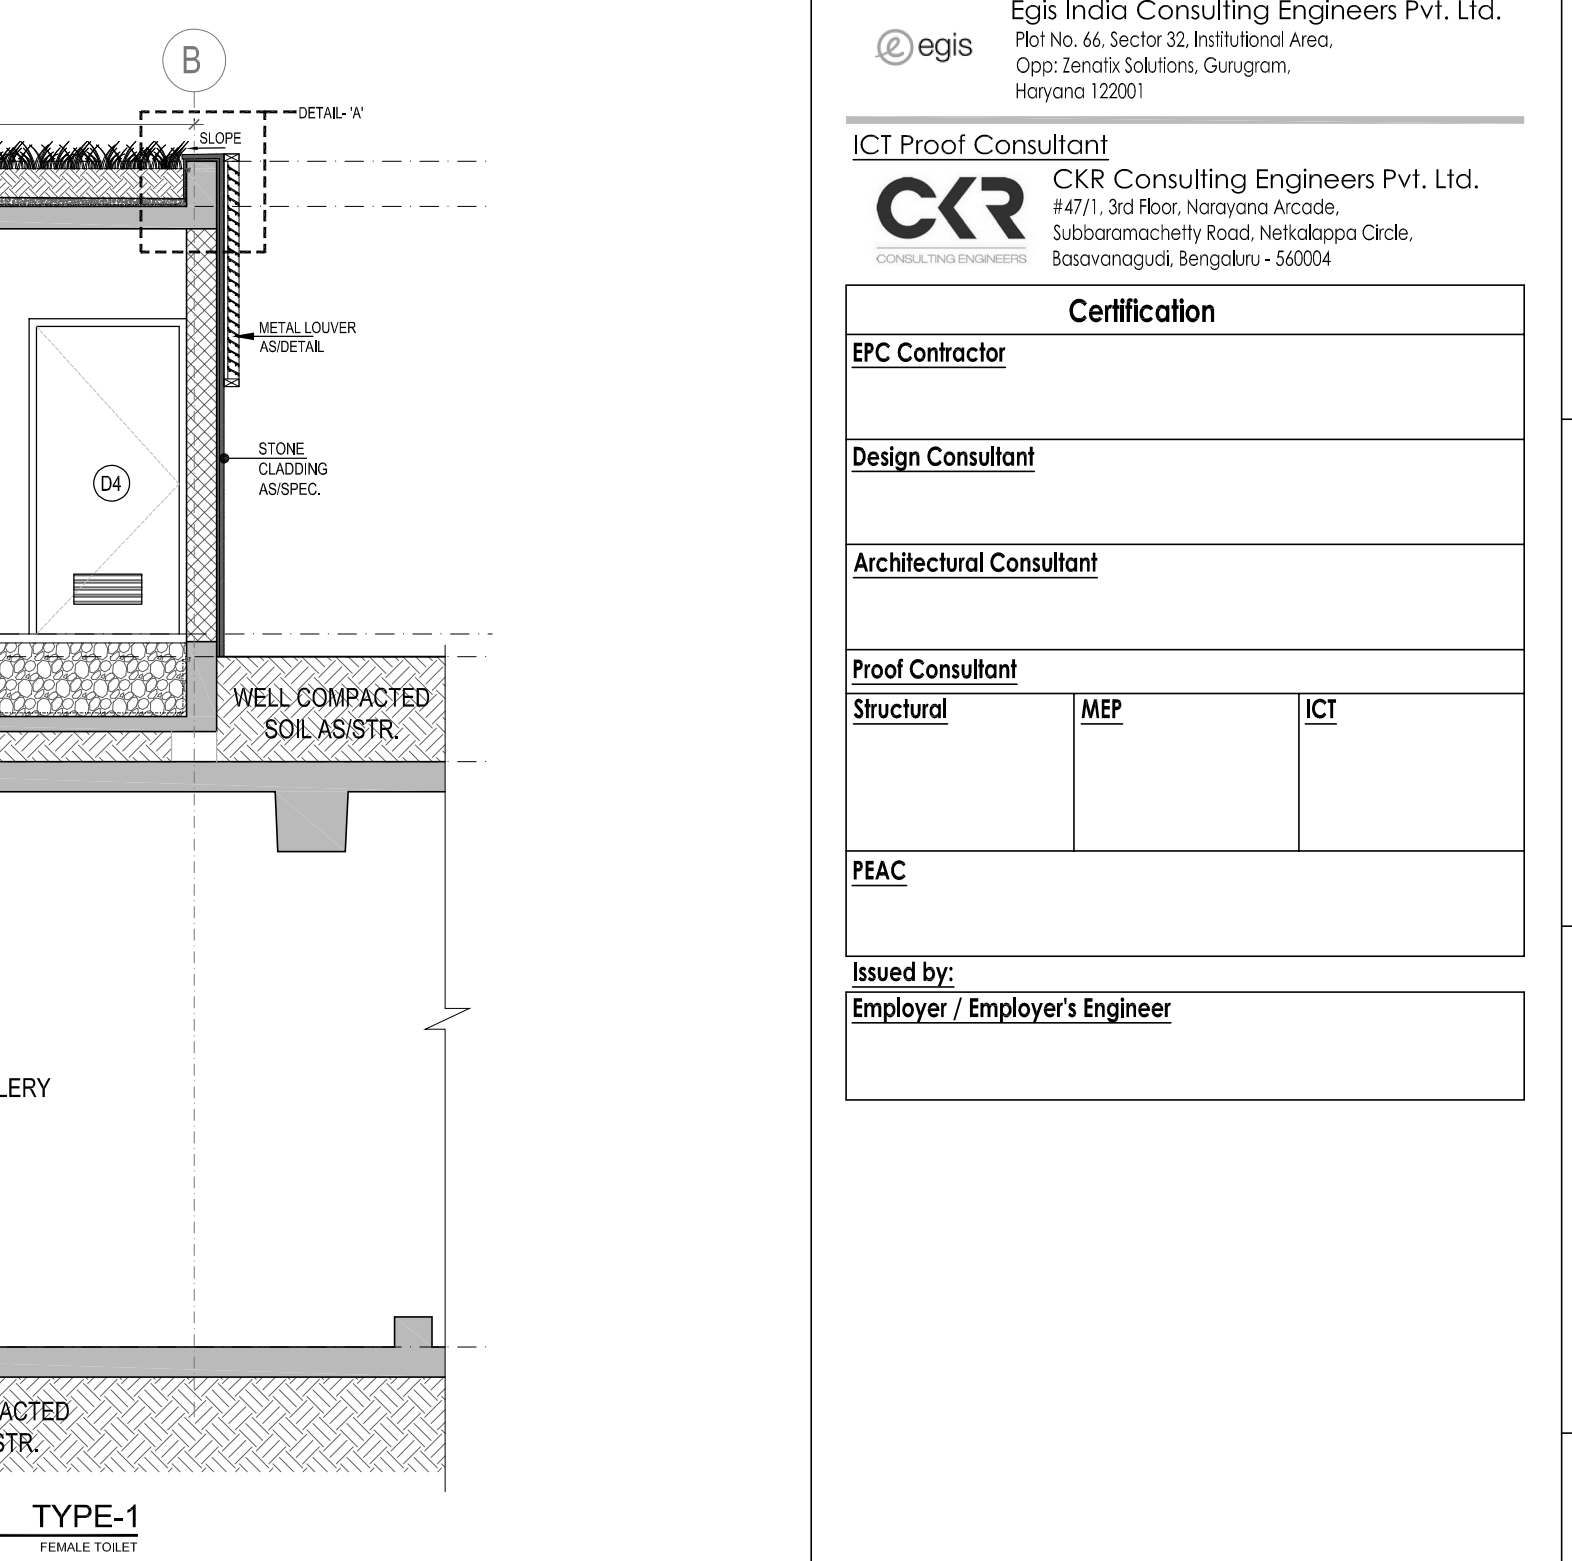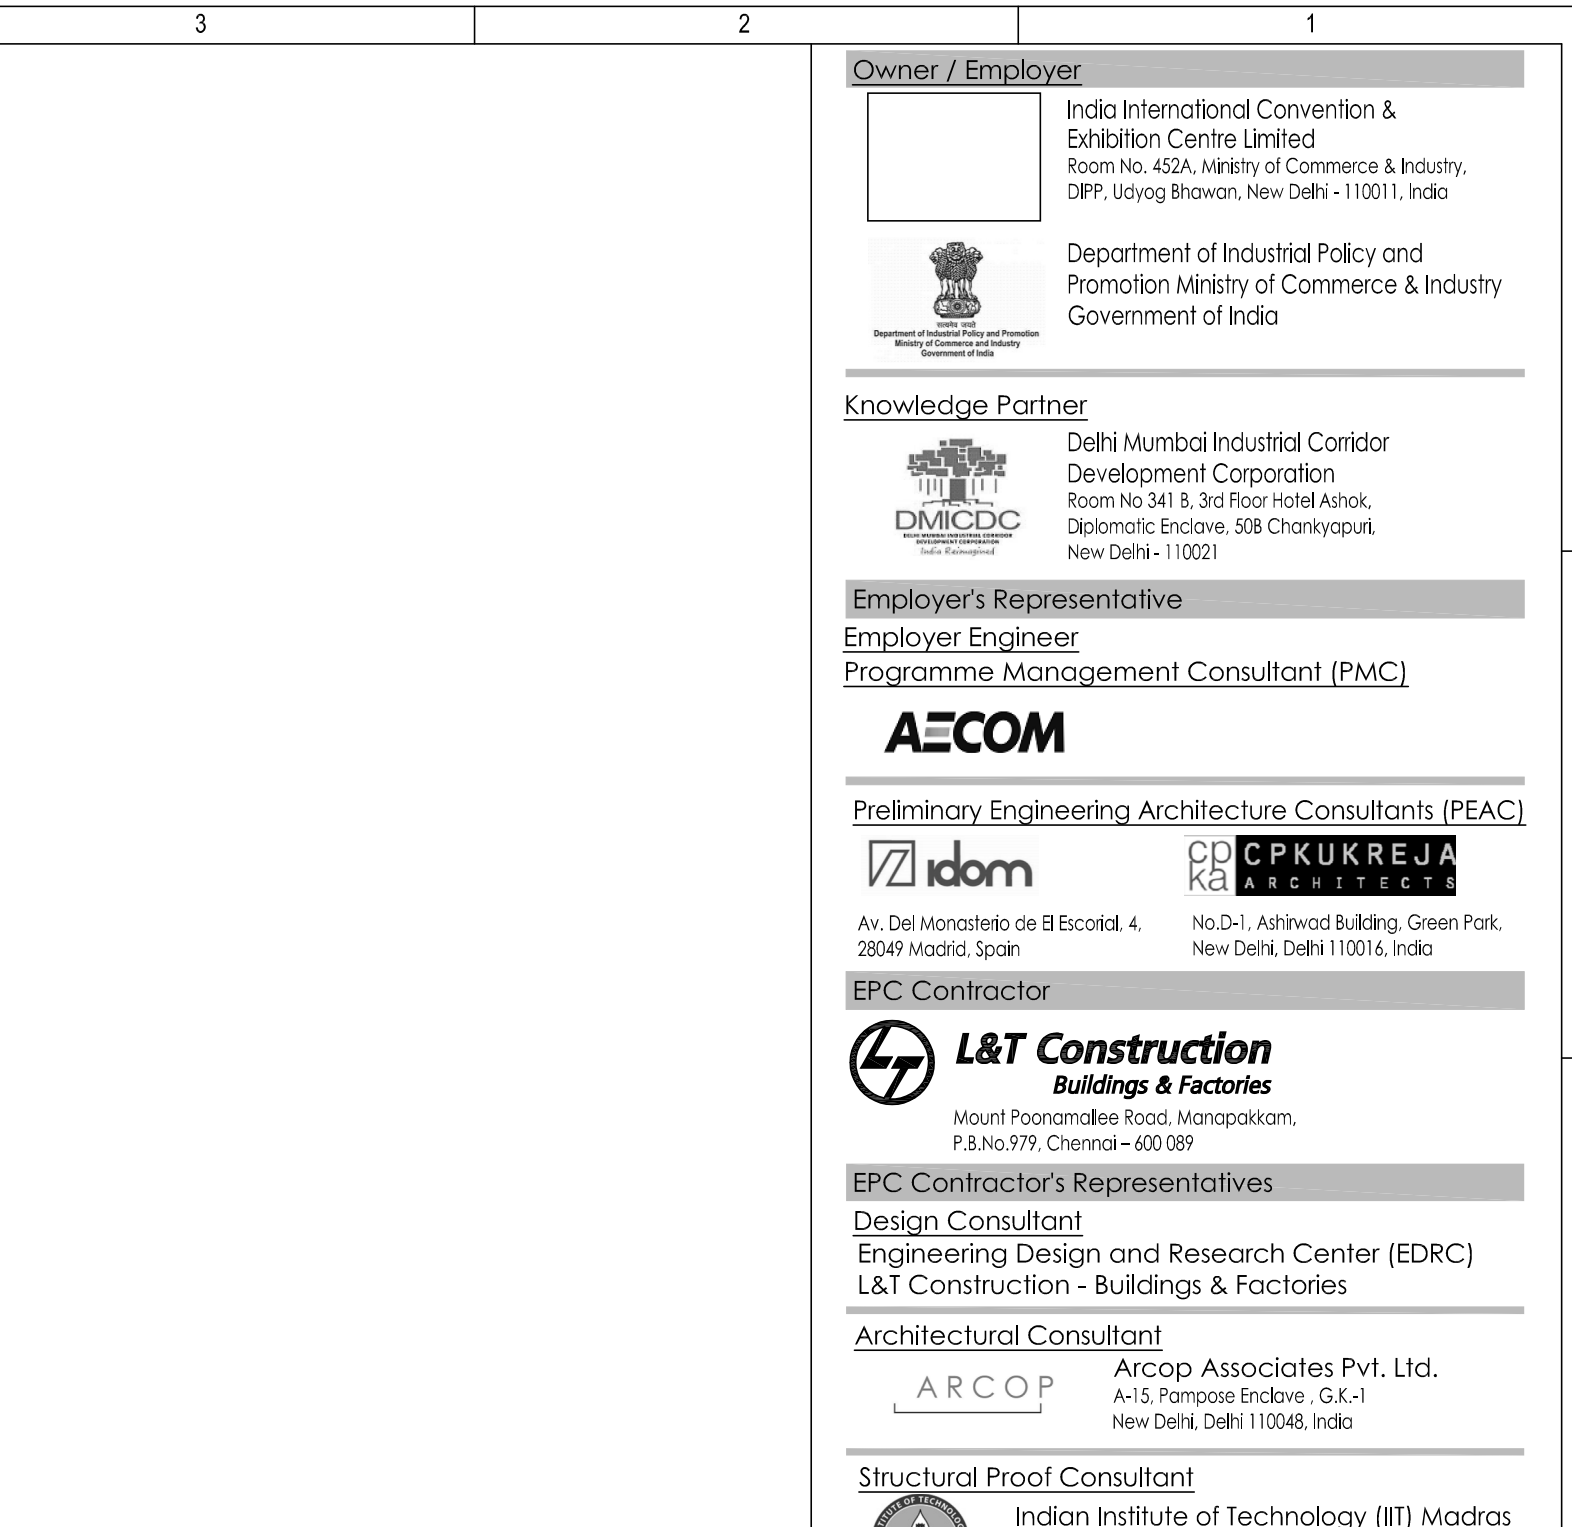

TOILET TYPE-1 MALE & FEMALE (TOILET AT OPEN EXHIBITION AREA) DOOR WINDOW SCHEDULE											
NAME	WIDTH (mm)	WIDTH (mm)	HEIGHT (mm)	HEIGHT (mm)	CILL HT (mm)	UNTEL HT (mm)	WIDTH (mm)	HEIGHT (mm)	CILL HT (mm)	MATERIAL	LOCATION
DOOR											
	FRAME TO FRAME	ROUGH OPENING SIZE	FRAME TO FRAME	ROUGH OPENING SIZE						DOOR LOUVER	
D1	750	780	2100	-	-	2100	300	100	200	WOODEN FRAMED WOODEN FLUSH SHUTTER DOOR WITH LOUVER	TYPE-1 TOILET (MALE & FEMALE)
D4	1050	1080	2100	-	-	2100	650	450	200	WOODEN FRAMED WOODEN FLUSH SHUTTER DOOR WITH LOUVER	TYPE-1 TOILET (MALE)
D4	1050	1080	2100	-	-	2100	450	200	200	WOODEN FRAMED WOODEN FLUSH SHUTTER DOOR WITH LOUVER	TYPE-1 TOILET (FEMALE)
D5	1100	1130	2100	-	-	2100	300	200	200	WOODEN FRAMED WOODEN FLUSH SHUTTER DOOR WITH LOUVER	TYPE-1 TOILET (FEMALE)
VENTILATOR											
V1	600	630	429	450	1650	2100				ALUMINIUM FRAMED GLAZED TOP HUNG VENTILATOR	TYPE-1 TOILET (MALE & FEMALE)
V2	1200	1230	429	450	1650	2100				ALUMINIUM FRAMED GLAZED TOP HUNG VENTILATOR	TYPE-1 TOILET (MALE & FEMALE)



ABBREVIATION:

F.F.L. - FINISHED FLOOR LEVEL
P.L. - FORMED ROAD LEVEL
P.C. - PRE-HOSE CABINET
L.V. - LEVEL
E.L.V. - ELECTRICAL
E.L.V. - EXTRA LOW VOLTAGE
M.H. - 400 MM DIA. MANHOLE UNIT
P.H.E. - PUBLIC HEALTH ENGINEERING

NOTES:

- ALL DIMENSIONS ARE IN MILLIMETERS. LEVELS IN METERS AND ANGLES IN DEGREES UNLESS OTHERWISE NOTED.
- THE DRAWING IS TO BE READ AND NOT TO BE SCALED. ONLY WRITTEN DIMENSIONS IN ALL CASES SHALL BE FOLLOWED.
- THE DRAWING SHALL BE READ IN CONJUNCTION WITH ALL RELEVANT ARCHITECTURAL, STRUCTURAL AND SERVICE DRAWINGS.
- ALL DIMENSIONS SHALL BE VERIFIED ON SITE PRIOR TO START OF WORK AND ANY DISCREPANCY SHALL BE BROUGHT TO THE NOTICE OF THE ARCHITECT.
- READ THE DRAWING IN CONJUNCTION WITH SITE PLAN, DWG NO. 017203-A-SP-00-00-0003
- PLUMBING FIXTURES, RAINWATER PIPE / LIGHT LOCATIONS ARE INDICATIVE ONLY FOR EXACT LOCATION AND NUMBERS REFER MEP DRG.

*** DIMENSION VARIES. BOTTOM TILE IS RESIDUE TILE**

FOR SUNKEN DETAIL REFER STRUCTURAL DRAWINGS.

This drawing is the property of L&T Construction Pvt. Ltd. and shall not be used or reproduced in any form without the prior permission of the company.

Owner / Employer

India International Convention & Exhibition Centre Limited
Room No. 402A, Ministry of Commerce & Industry,
BPM, Jyoti Bhawan, New Delhi - 110011, India

Department of Industrial Policy and Promotion
Ministry of Commerce & Industry
Government of India

Knowledge Partner

Delhi Mumbai Industrial Corridor Development Corporation
Room No. 341 & 342, Ministry of Commerce & Industry,
BPM, Jyoti Bhawan, New Delhi - 110011, India

Employers Representative
Employer Engineer
Programme Management Consultant (PMC)

AECOM

Primary Engineering Architecture Consultants (PEAC)

dom **CD CPKUREJA**
No. 27, Nehru Building, Green Park,
20049 Noida, Uttar Pradesh
New Delhi, Delhi 110046, India

EPC Contractor

L&T Construction
Buildings & Factories
M-10, Sector 25, Gurgaon, Haryana
Gurgaon, Haryana 122001, India

EPC Contractor's Representatives

Design Consultant
Engineering Design and Research Center (EDRC)
L&T Construction - Buildings & Factories

Architectural Consultant
ARCOP Associates Pvt. Ltd.
A-15, Parkside Enclave, G-1/1
New Delhi, Delhi 110046, India

Structural Proof Consultant
Indian Institute of Technology (IIT) Madras
Sector 25, Gurgaon, Haryana
Gurgaon, Haryana 122001, India

MEP Proof Consultant
Egis India Consulting Engineers Pvt. Ltd.
Plot No. 16, Sector 25, Gurgaon, Haryana
Gurgaon, Haryana 122001, India

ICT Proof Consultant
CR Consulting Engineers Pvt. Ltd.
40/1, 3rd Floor, Naraina Arcade,
26 Connaught Place, New Delhi
Connaught Place, New Delhi 110046, India

Certification

EPC Contractor

Design Consultant

Architectural Consultant

Proof Consultant

Structure

MEP

 
ICT

PEAC

Issued by:
Employer / Employer's Engineer

Colour scheme:-

METAL LOUVERS:- RAL-9003- Signal white

LEGEND		
TAG	PARTICULARS	
FINISHING SCHEDULE (CATEGORY-A) AS APPROVED SAMPLES/SPECIFICATIONS		
A1	FLOOR TILE (600X600)	
A2	WALL TILE (600X300)	
A3	STONE ASI APPROVAL (THRESHOLD)	
A4	PAINT ASI APPROVAL	
A7	URINAL PARTITION ASI SPECS	
A8	STONE ASI APPROVAL	
A10	COUNTER TOP MATERIAL ASI APPROVAL	
FIXTURES (CATEGORY-B) AS APPROVED SAMPLES		
B1	WATER CLOSET	
B2	WASH BASIN	
B3	URINAL	
B4	CONCEALED CISTERN	
B5	WATER CLOSET HANDICAP	
B6	VANITY WASH BASIN	
B7	HANDICAP GRAB BAR	
B8	PILLAR TAP - BASIN	
B9	HEALTH FAUCET (WITH HOSE)	
B10	2 WAY BIB COCK	
B11	WASTE COUPLING	
B12	BOTTLE TRAP	
B13	BRAIDED HOSE (BASIN)	
B14	ANGLE VALVE	
B15	SENSOR PLATE	
B16	CONCEALED CISTERN FLUSH	
B19	DRINKING WATER FOUNTAIN	
FITTINGS (CATEGORY-C) AS APPROVED SAMPLES		
C1	TOILET PAPER HOLDER	
C2	SOAP DISPENSER	
C3	HAND DRIER	
C4	TISSUE PAPER HOLDER	
C5	MIRROR (800 X 800)	
LEGEND		
	ANTISKID CERAMIC FLOOR TILE AS APPROVED SAMPLE	
	GLAZED CERAMIC WALL TILE AS APPROVED SAMPLE	
	STARTING FLOOR TILE (ANTISKID CERAMIC TILE)	
	STONE THRESHOLD	
	KOTA STONE AS APPROVED SAMPLE	
	STARTING FLOOR TILE (KOTA STONE)	
LEGEND		
S.No.	PARTICULARS	SYMBOL
PLUMBING		
1	FLOOR TRAP	
ELECTRICAL		
1	DOWN LIGHT AT CEILING LEVEL AS MEP	
2	TUBELIGHT AT +2250 MM FROM FFL AS MEP	

EPC Contractor

L&T Construction
Buildings & Factories

JOB No. : 017203

Project Name
DESIGN AND CONSTRUCTION OF INDIA INTERNATIONAL CONVENTION & EXPO CENTRE
SECTOR 25, DWARKA, NEW DELHI, INDIA

Drawing Status
GOOD FOR CONSTRUCTION (GFC)

Drawing No
A 00 0090


Rev. No
R0

Title :
SITE TOILET DETAIL
TYPE 1 (FEMALE)
OPEN EXHIBITION AREA




EDRC DWG NO. : 017203-A-SP-00-00-0090

Scale
AS INDICATED


Sheet No.
A0

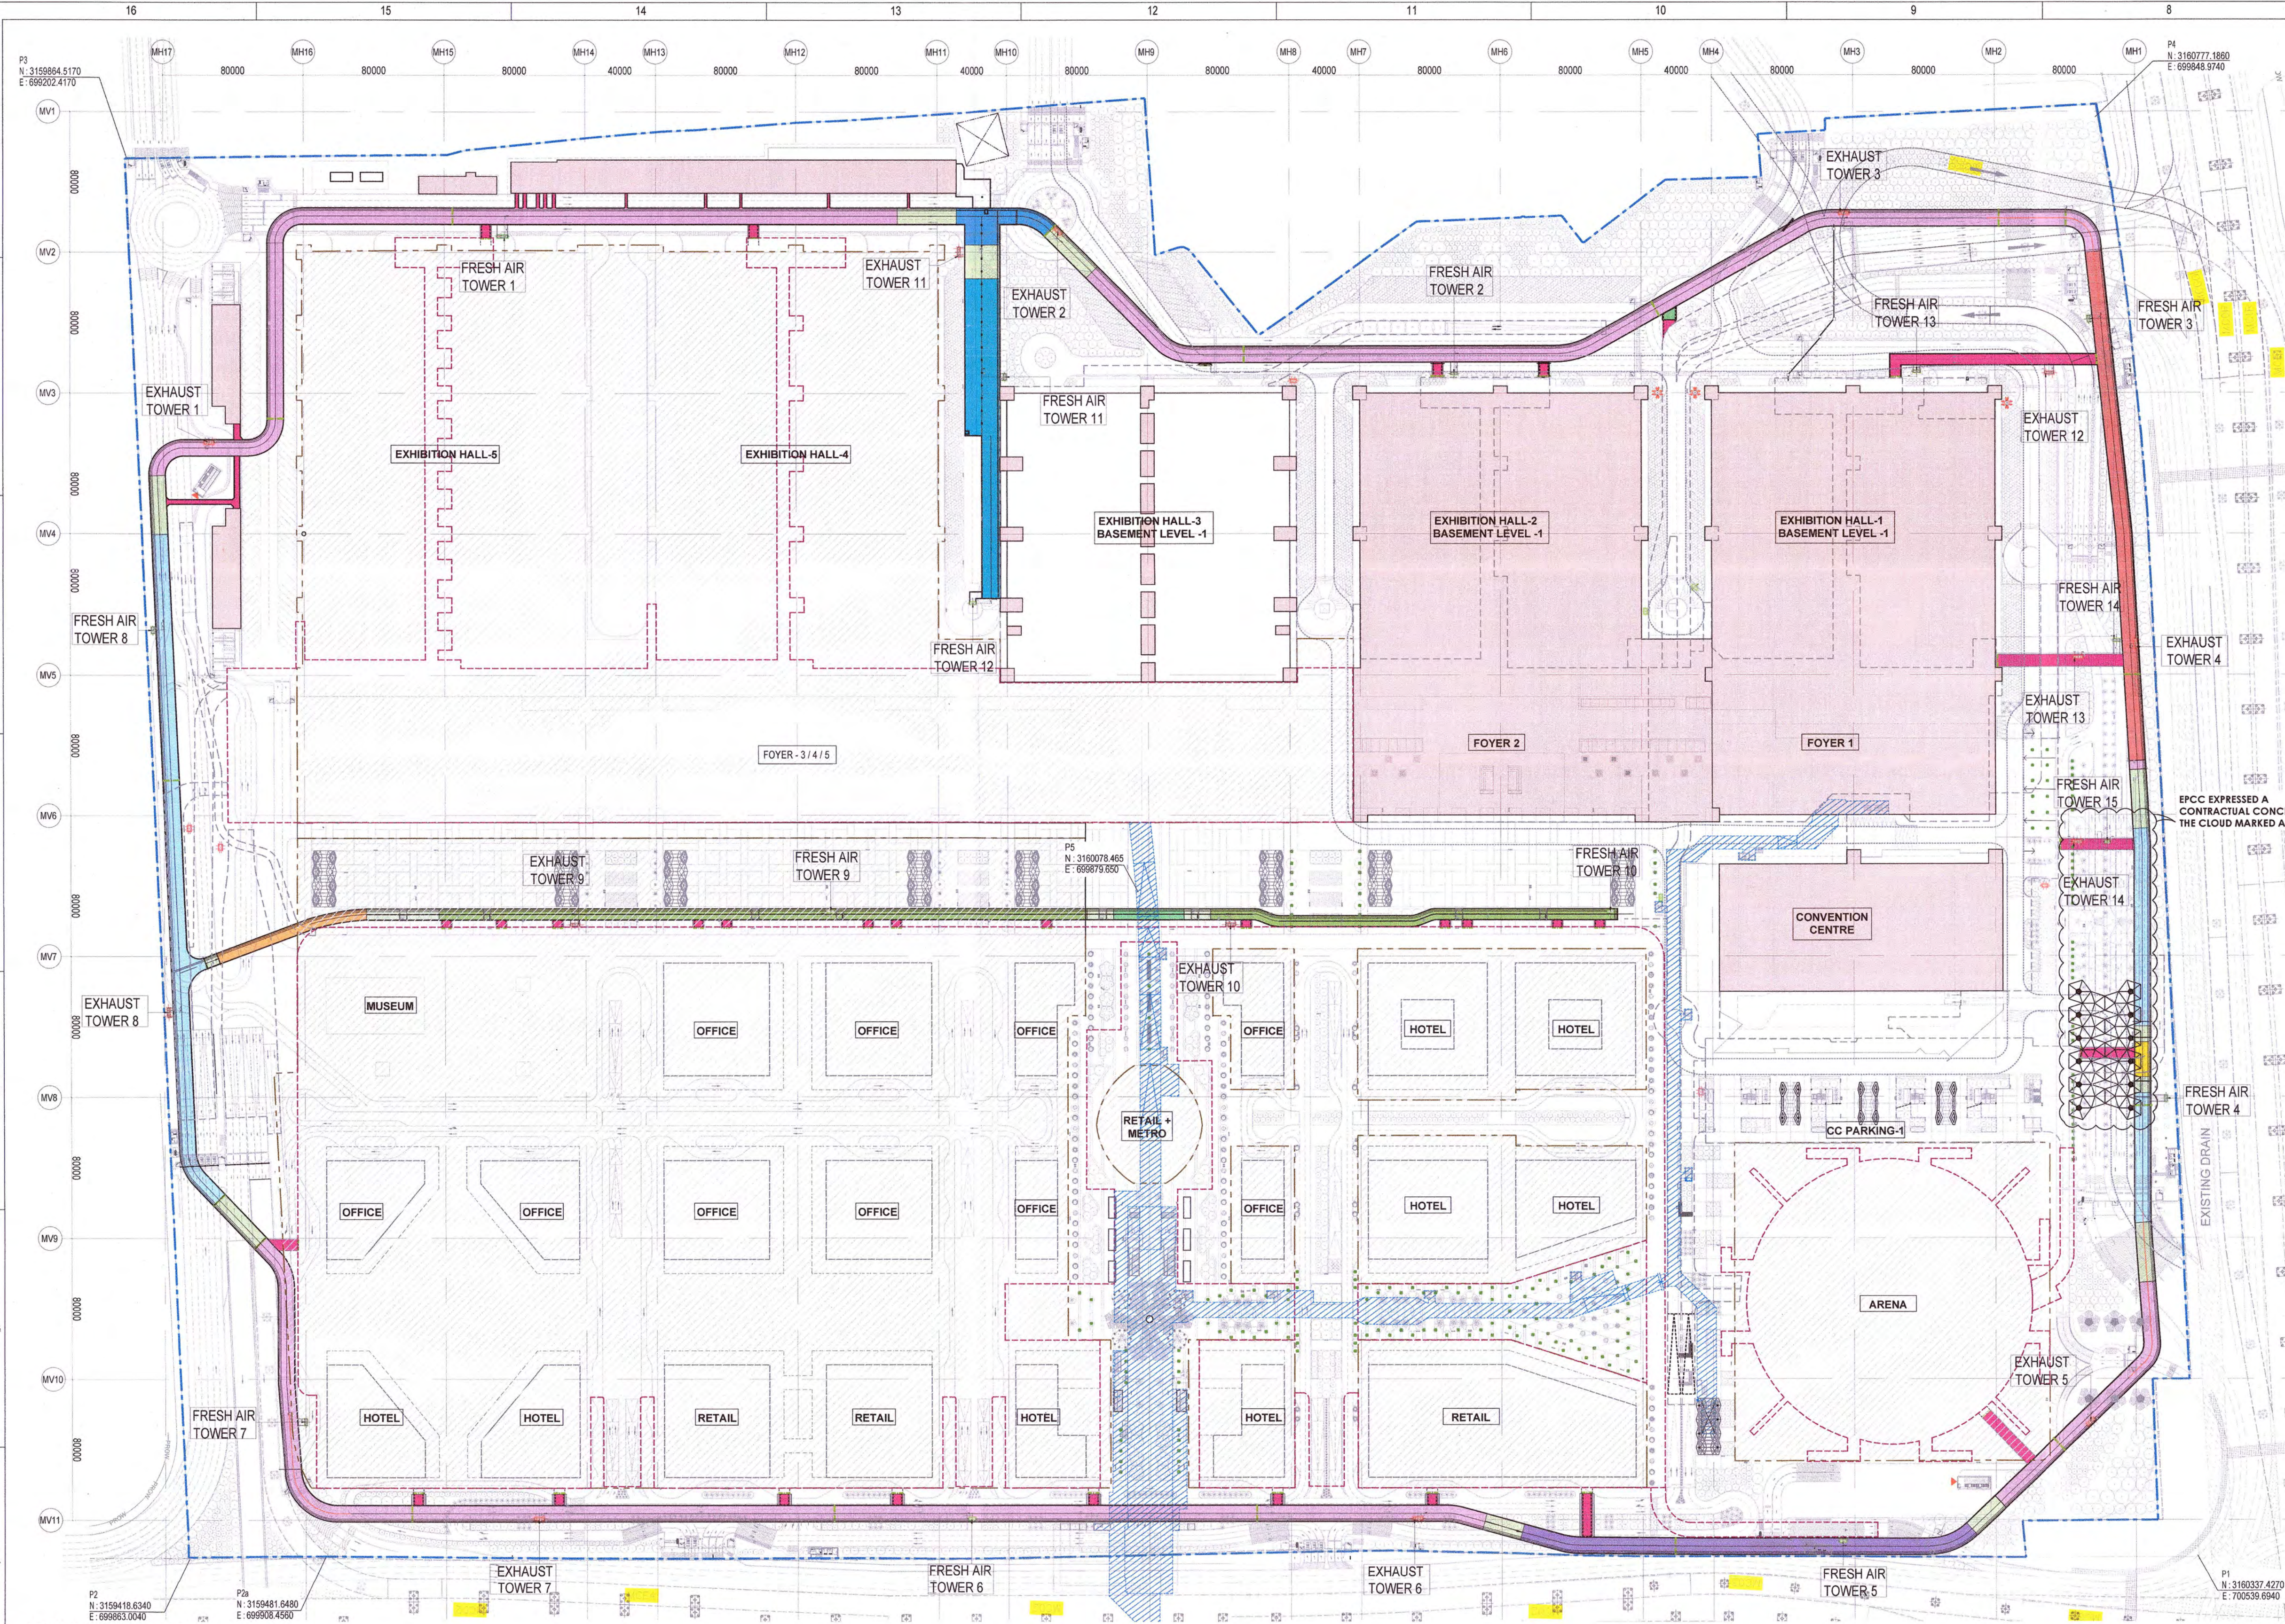

SERVICE GALLERY LAYOUT
GROUND FLOOR
SCALE: 1:2000

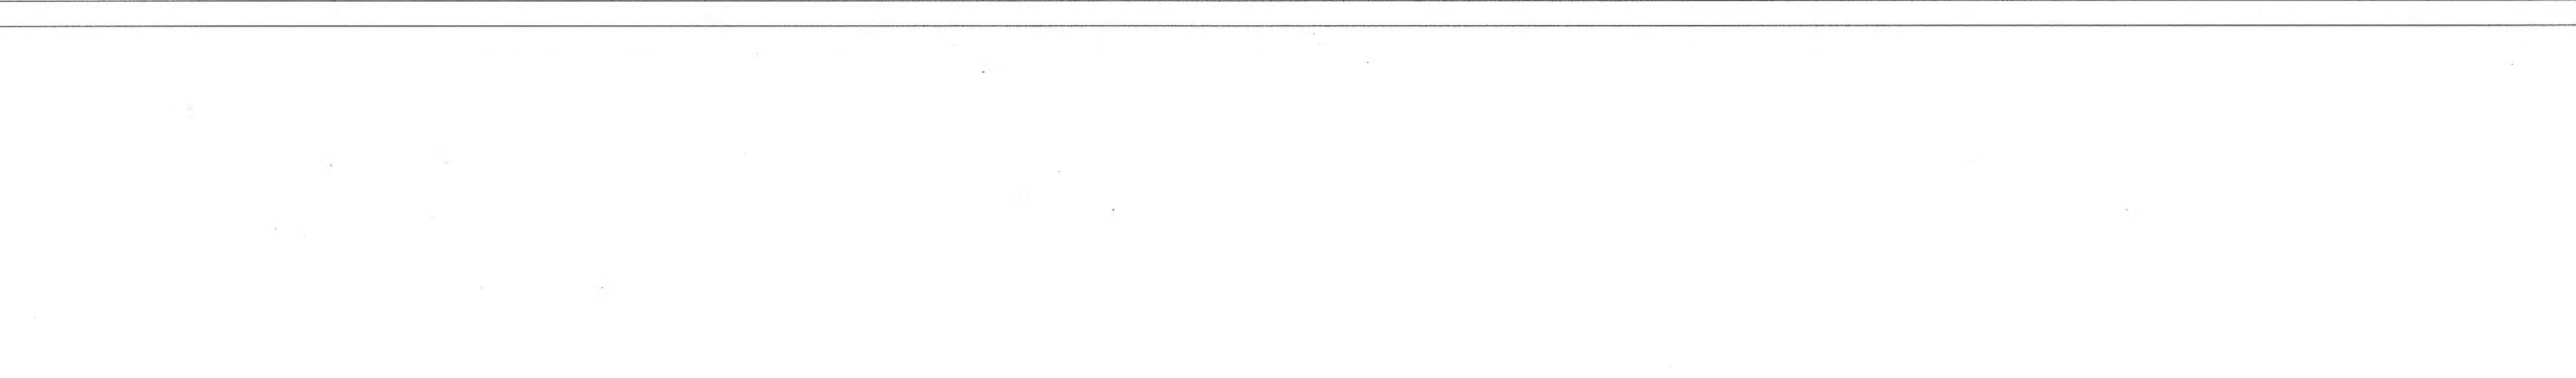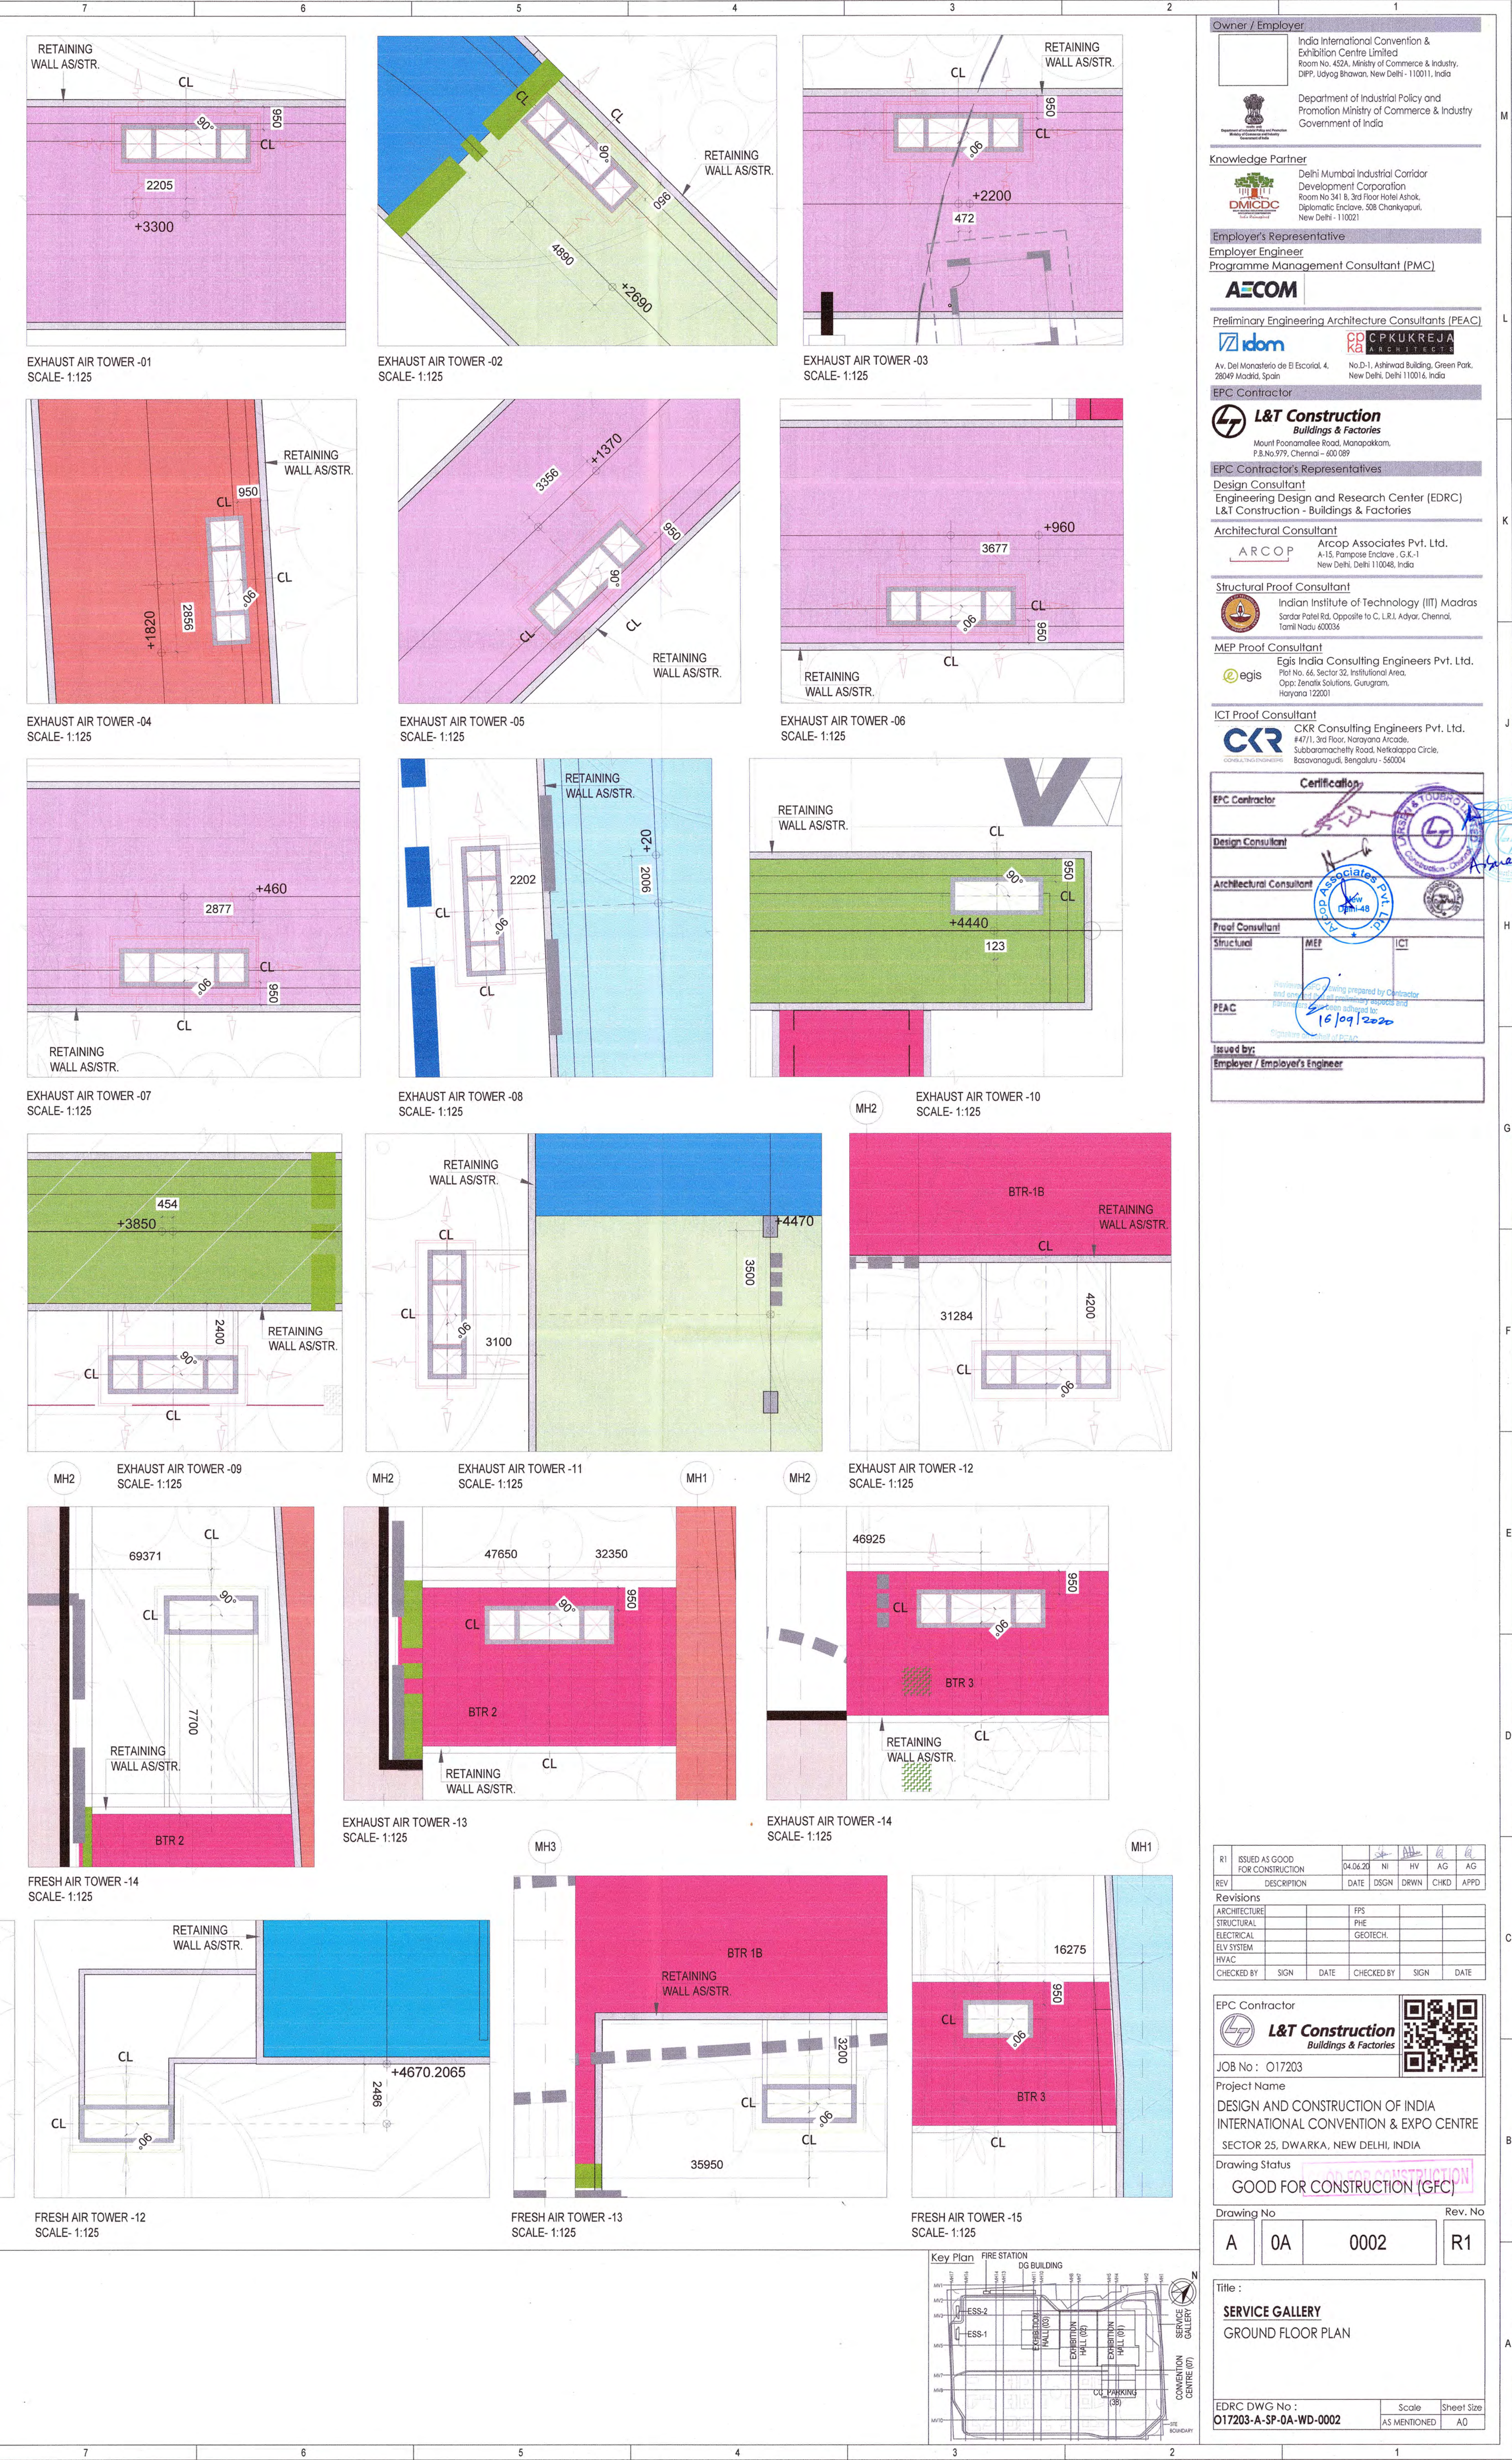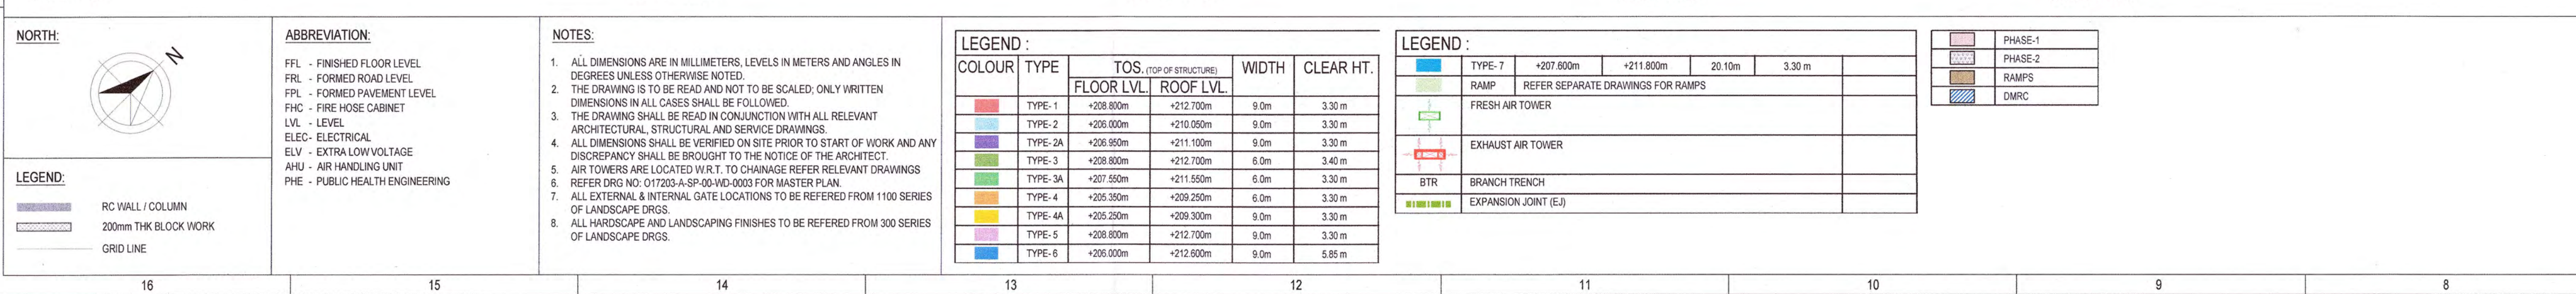

Not to be used for any other purpose without the written permission of the Engineer.

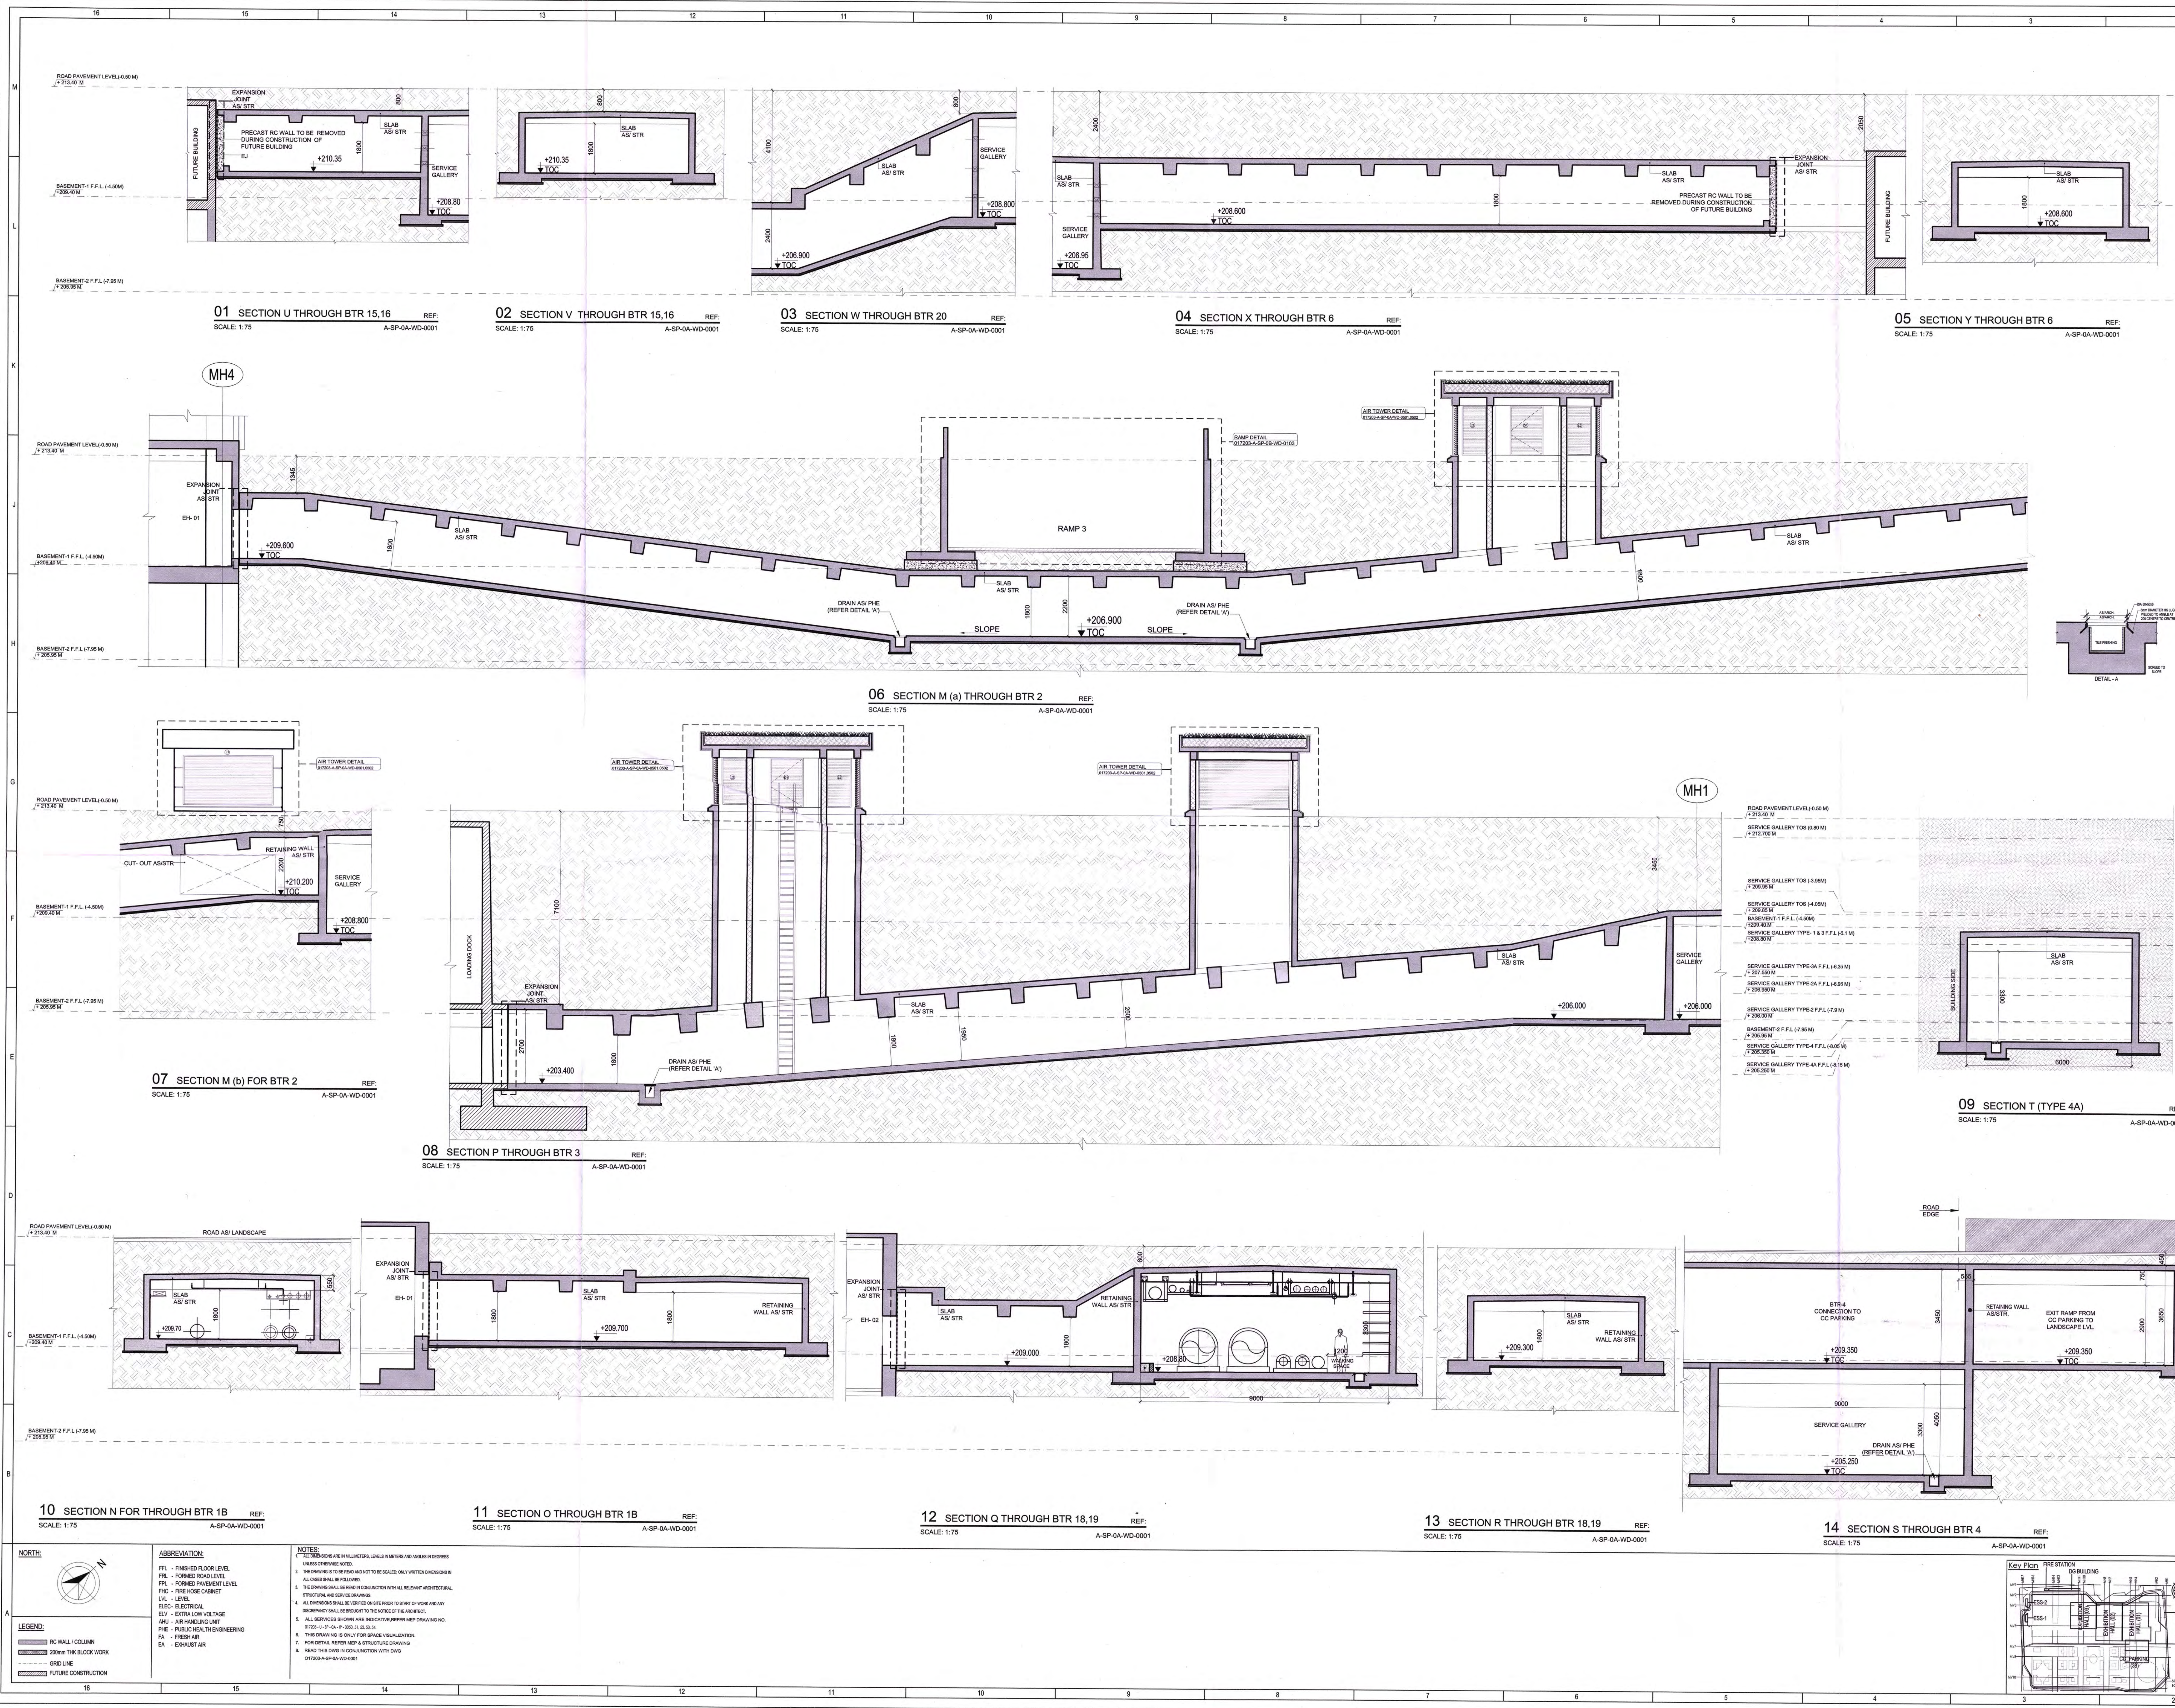

Owner / Employer
India International Convention & Exhibition Centre Limited
Room No. 424, Ministry of Commerce & Industry
DPI, Lodhi Road, New Delhi - 110011, India
Department of Industrial Policy and Promotion, Ministry of Commerce & Industry
Government of India

Knowledge Partner
Delhi Mumbai Industrial Corridor
Development Corporation
Room No. 341 & 3rd Floor, Hotel Anshu,
Gurgaon, Haryana, 122002, India
New Delhi - 110011

Employer's Representative
Employer Engineer
Programme Management Consultant (PMC)
AECOM

Preliminary Engineering Architecture Consultants (PEAC)
idom **CPKUREJA**
Au. Del. Mandate de B. Eclair. 4, No. D-1, Ashwini Building, Green Park,
28th Floor, New Delhi - 110016, India

EPC Contractor
L&T Construction
Mount Road, Madurai, Tamil Nadu,
625 001, India

EPC Contractor's Representatives
Design Consultant
Engineering Design and Research Center (EDRC)
L&T Construction - Buildings & Factories
Architectural Consultant
ARCOP Arcop Associates Pvt. Ltd.
New Delhi, Delhi 110048, India

Structural Proof Consultant
Indian Institute of Technology (IIT) Madras
Chennai, Tamil Nadu 600035, India

MEP Proof Consultant
Egis India Consulting Engineers Pvt. Ltd.
Plot No. 46, Sector 29, Indira Park, Gurgaon,
Haryana 122002, India

ICT Proof Consultant
CKR Consulting Engineers Pvt. Ltd.
A-11, 3rd Floor, Naraina Arcade,
Subhash Chandra Road, Indraprastha Circle,
Basant Nagar, New Delhi - 110028, India

Certification
EPC Contractor
Design Consultant
Architectural Consultant
Proof Consultant
Structural
MEP
ICT
Reviewed GFC drawing prepared by Consultant and
checked that all primary aspects and parameters
have been addressed.
Signed as Employer's Engineer
Date: 14/01/2023

09 SECTION T (TYPE 4A) REF: A-SP-QA-WD-0001
SCALE: 1:75

10 SECTION N FOR THROUGH BTR 1B REF: A-SP-QA-WD-0001
SCALE: 1:75

11 SECTION O THROUGH BTR 1B REF: A-SP-QA-WD-0001
SCALE: 1:75

12 SECTION Q THROUGH BTR 18,19 REF: A-SP-QA-WD-0001
SCALE: 1:75

13 SECTION R THROUGH BTR 18,19 REF: A-SP-QA-WD-0001
SCALE: 1:75

14 SECTION S THROUGH BTR 4 REF: A-SP-QA-WD-0001
SCALE: 1:75

Key Plan
CONVENTION CENTRE BUILDING
SERVICE GALLERY
SECTION

Legend
RC WALL / COLUMN
200mm THK BLOCK WORK
GRD LINE
FUTURE CONSTRUCTION


Abbreviations
F.F.L. - FINISHED FLOOR LEVEL
F.R. - FORMED ROAD LEVEL
F.P.L. - FORMED PAVEMENT LEVEL
F.C. - FIRE HOSE CABINET
LVL. - LEVEL
ELEC. - ELECTRICAL
ELEV. - ELEVATION
A.H.U. - AIR HANDLING UNIT
P.H.E. - PUBLIC HEALTH ENGINEERING
F.A. - FRESH AIR
E.A. - EXHAUST AIR

Notes
1. ALL DIMENSIONS ARE IN METERS, UNLESS OTHERWISE SPECIFIED.
2. THE DRAWING IS TO BE USED AS A GUIDE ONLY. ALL DIMENSIONS MUST BE CHECKED ON SITE.
3. THE DRAWING IS TO BE USED IN CONJUNCTION WITH ALL RELEVANT ARCHITECTURAL, STRUCTURAL AND SERVICE DRAWINGS.
4. ALL DIMENSIONS MUST BE CHECKED ON SITE PRIOR TO START OF WORK AND ANY DISCREPANCY SHALL BE REPORTED TO THE ARCHITECT.
5. ALL SERVICES SHOWN ARE INDICATIVE. REFER NEP DRAWING NO. 017203-A-SP-QA-WD-0001 FOR DETAILS.
6. THIS DRAWING IS ONLY FOR SPACE VISUALIZATION.
7. FOR DETAILS REFER NEP & STRUCTURE DRAWINGS.
8. READ THIS DRAWING IN CONJUNCTION WITH DWG 017203-A-SP-QA-WD-0001.

Revision Table

NO.	REVISION	DATE	BY	CHKD	APPD
01	ISSUED AS GOOD FOR CONSTRUCTION	21.01.18	N	RV	RV

Approval
EPC Contractor
L&T Construction
JCB No.: 017203
Project Name
DESIGN AND CONSTRUCTION OF INDIA INTERNATIONAL CONVENTION & EXPO CENTRE
SECTION 25, DWARKA, NEW DELHI, INDIA
Drawing Status
GOOD FOR CONSTRUCTION (GFC)
Drawing No.
A 0A 0102
Rev. No.
R0
Title
SERVICE GALLERY SECTIONS
EDRC DWG No.: 017203-A-SP-QA-WD-0102
Scale
1:75
Sheet Size
A0

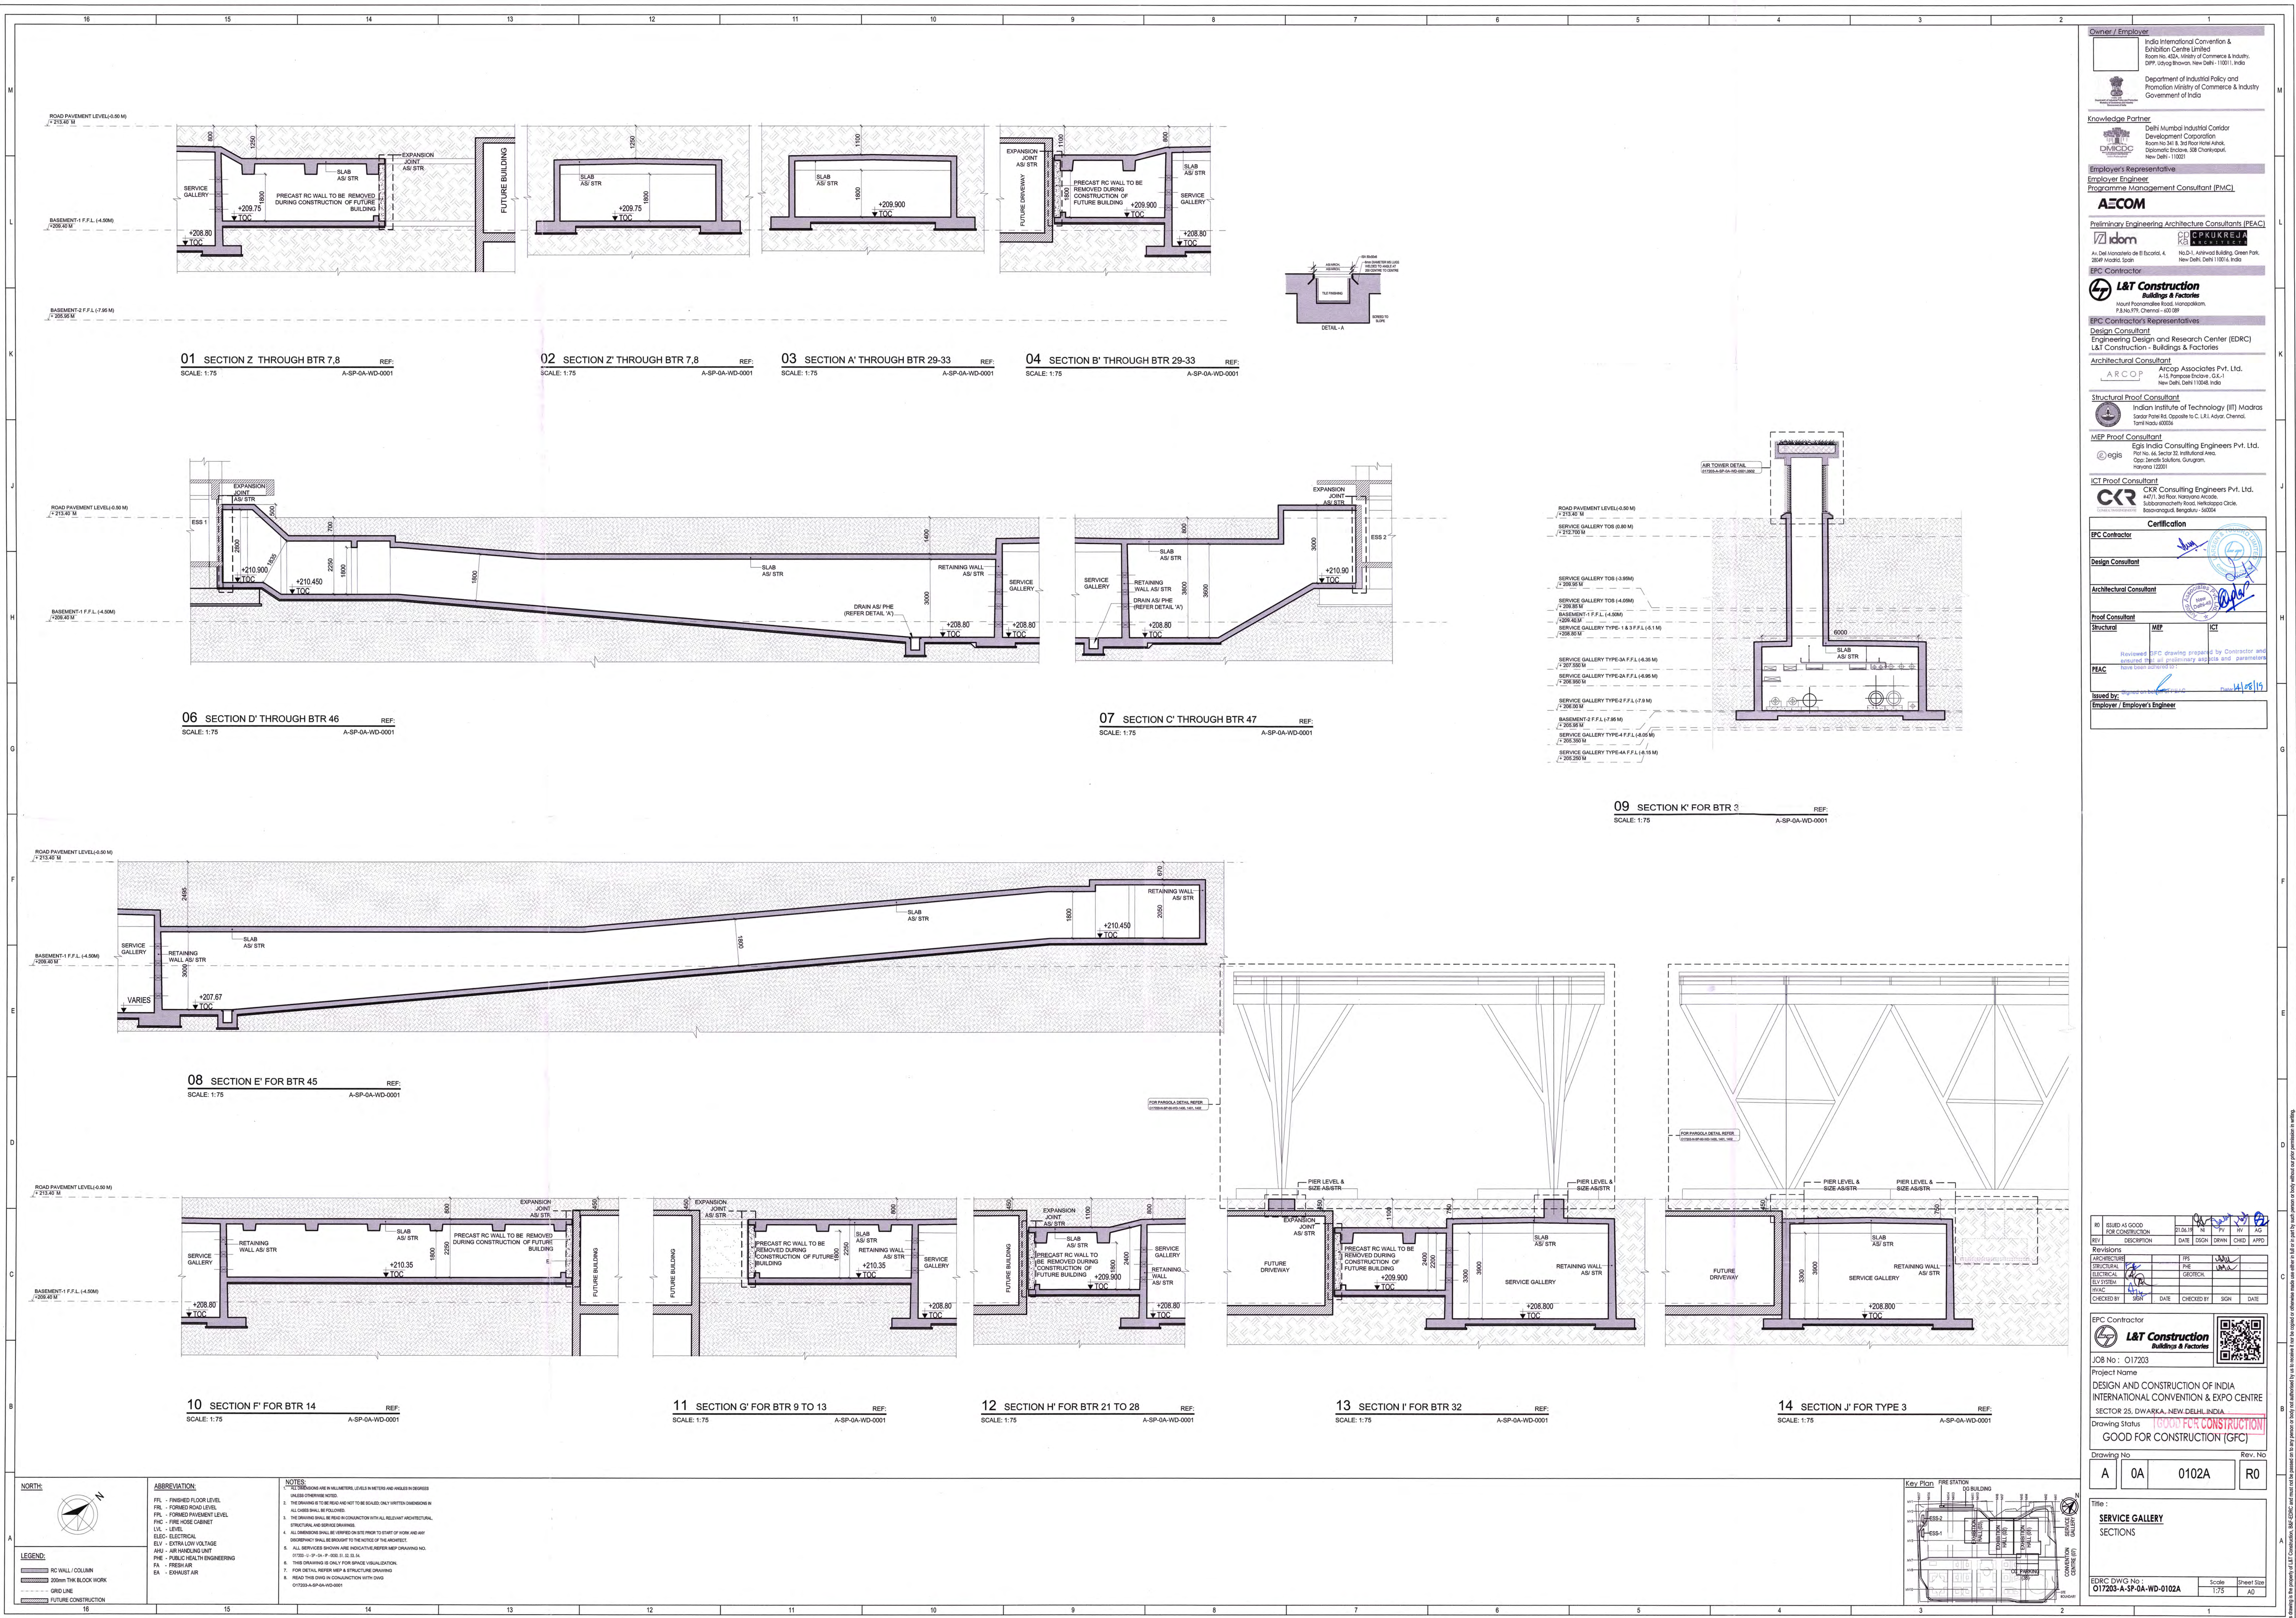

Owner / Employer

India International Convention & Exhibition Centre Limited
Room No. 404, Ministry of Commerce & Industry,
DPP, Lodhi Road, New Delhi - 110011, India

Department of Industrial Policy and Promotion Ministry of Commerce & Industry
Government of India

Knowledge Partner

Delhi Mumbai Industrial Corridor Development Corporation
Room No. 341 & 342, Post Office, New Delhi - 110011, India

Employer's Representative

Programme Management Consultant (PMC)

AECOM

Preliminary Engineering Architecture Consultants (PEAC)

idm **CPKUREJA**

A-1, D-1, Approved Building, Green Park, 28th Floor, New Delhi - 110016, India

Contractor

L&T Construction

Account: Panchsheel Road, Manasikot, Panchsheel Road, New Delhi - 110016, India

EPC Contractor's Representatives

Design Consultant

Engineering Design and Research Center (EDRC)

L&T Construction - Buildings & Factories

Architectural Consultant

ARCOP

ARCOP Associates Pvt. Ltd., New Delhi - 110016, India

Structural Proof Consultant

Indian Institute of Technology (IIT) Madras

Superstructure, Opposite to C. L. A. Road, Chennai, Tamil Nadu - 600034

MEP Proof Consultant

Egis India Consulting Engineers Pvt. Ltd.

Plot No. 44, Sector 75, Industrial Area, Opp. Janta Sankh, Gurgaon, Haryana - 122001

ICT Proof Consultant

CKR Consulting Engineers Pvt. Ltd.

4071, 3rd Floor, Naraina Vihar, Subhash Chandra Road, Naraina Vihar, New Delhi - 110028

EPC Contractor

Design Consultant

Architectural Consultant

Proof Consultant

MEP

ICT

PEAC

Reviewed EPC drawing prepared by Contractor and issued for all preliminary aspects and parameters have been checked.

14/05/19

Used by:

Employer / Employer's Engineer

Revision

NO	REASON	DATE	BY	CHKD	APPD
01	REVIEW AT GOOD FOR CONSTRUCTION	14/05/19	SV	SV	SV

EPC Contractor

L&T Construction


Project Name: DESIGN AND CONSTRUCTION OF INDIA INTERNATIONAL CONVENTION & EXPO CENTRE SECTOR 25, DWARKA, NEW DELHI, INDIA

Drawing Status: **GOOD FOR CONSTRUCTION (GFC)**


Drawing No: A 0A 0102A Rev. No: R0

EDRC DWG No: 017203-A-SP-0A-WD-0102A Scale: 1:75 Sheet Size: A0

This drawing is the property of L&T Construction. All rights reserved. No part of this drawing may be reproduced or transmitted in any form or by any means electronic or mechanical, including photocopying, recording, or by any information storage or retrieval system, without prior written permission from L&T Construction.

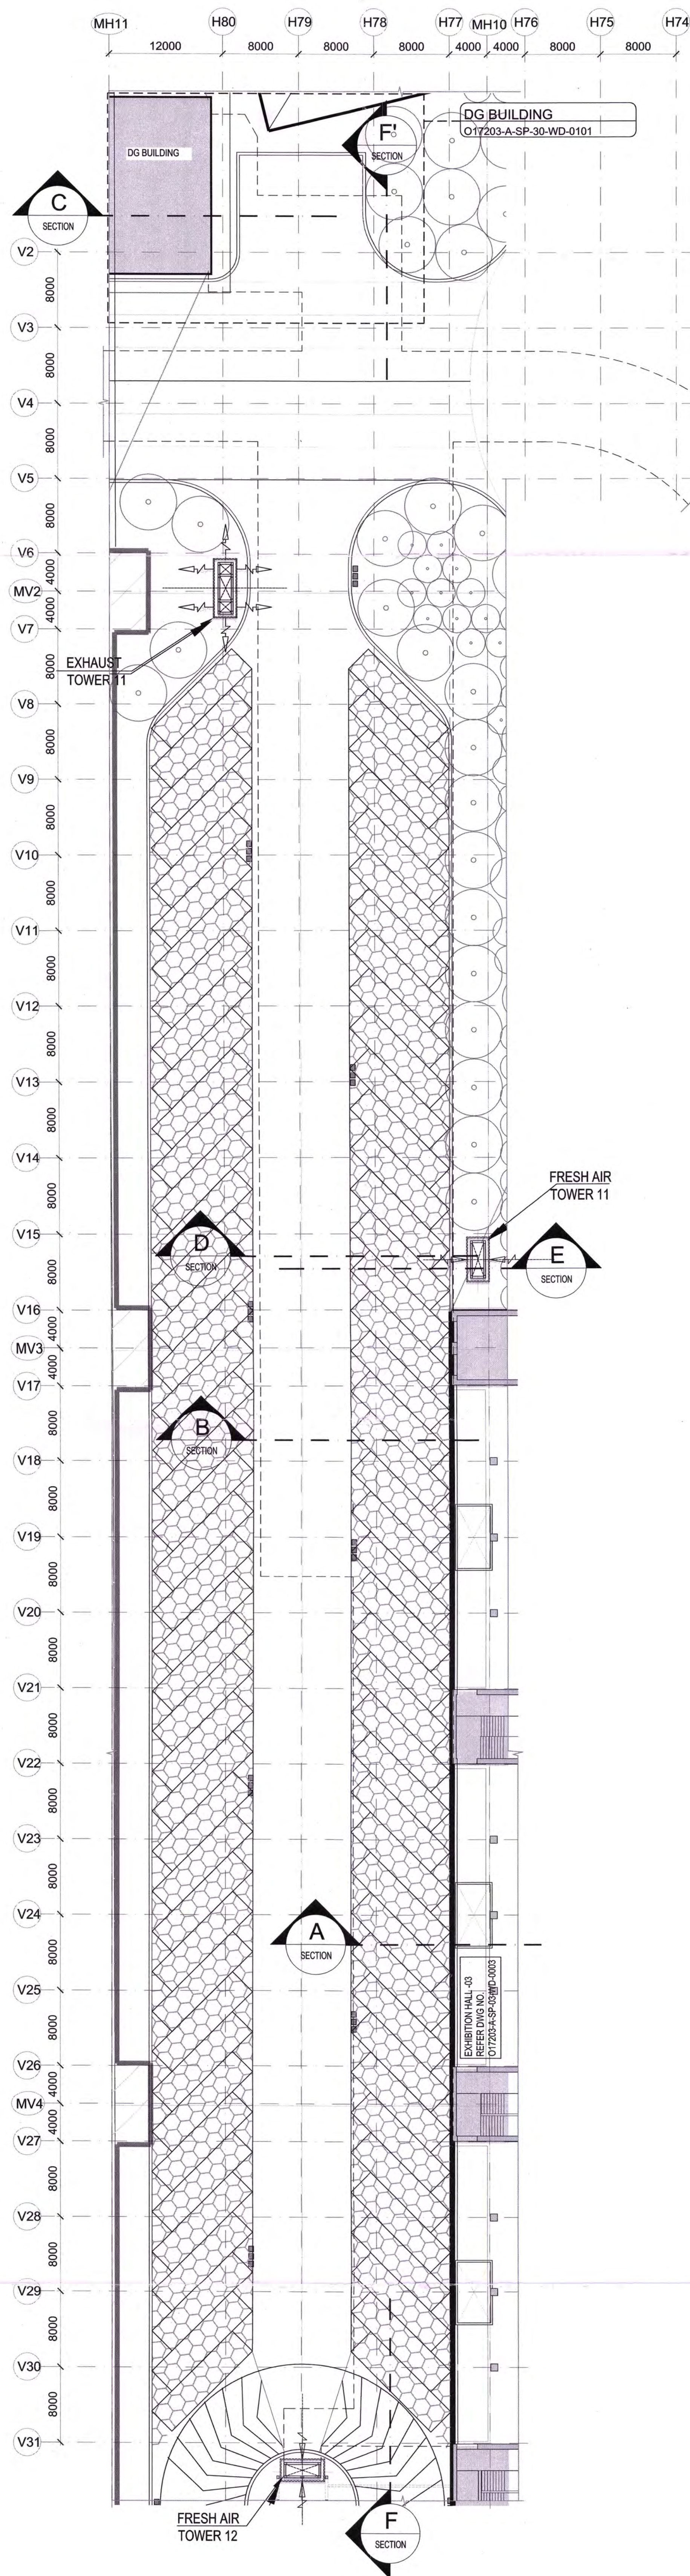

01 GROUND FLOOR PLAN
SCALE: 1:300
A-SP-0A-WD-0117

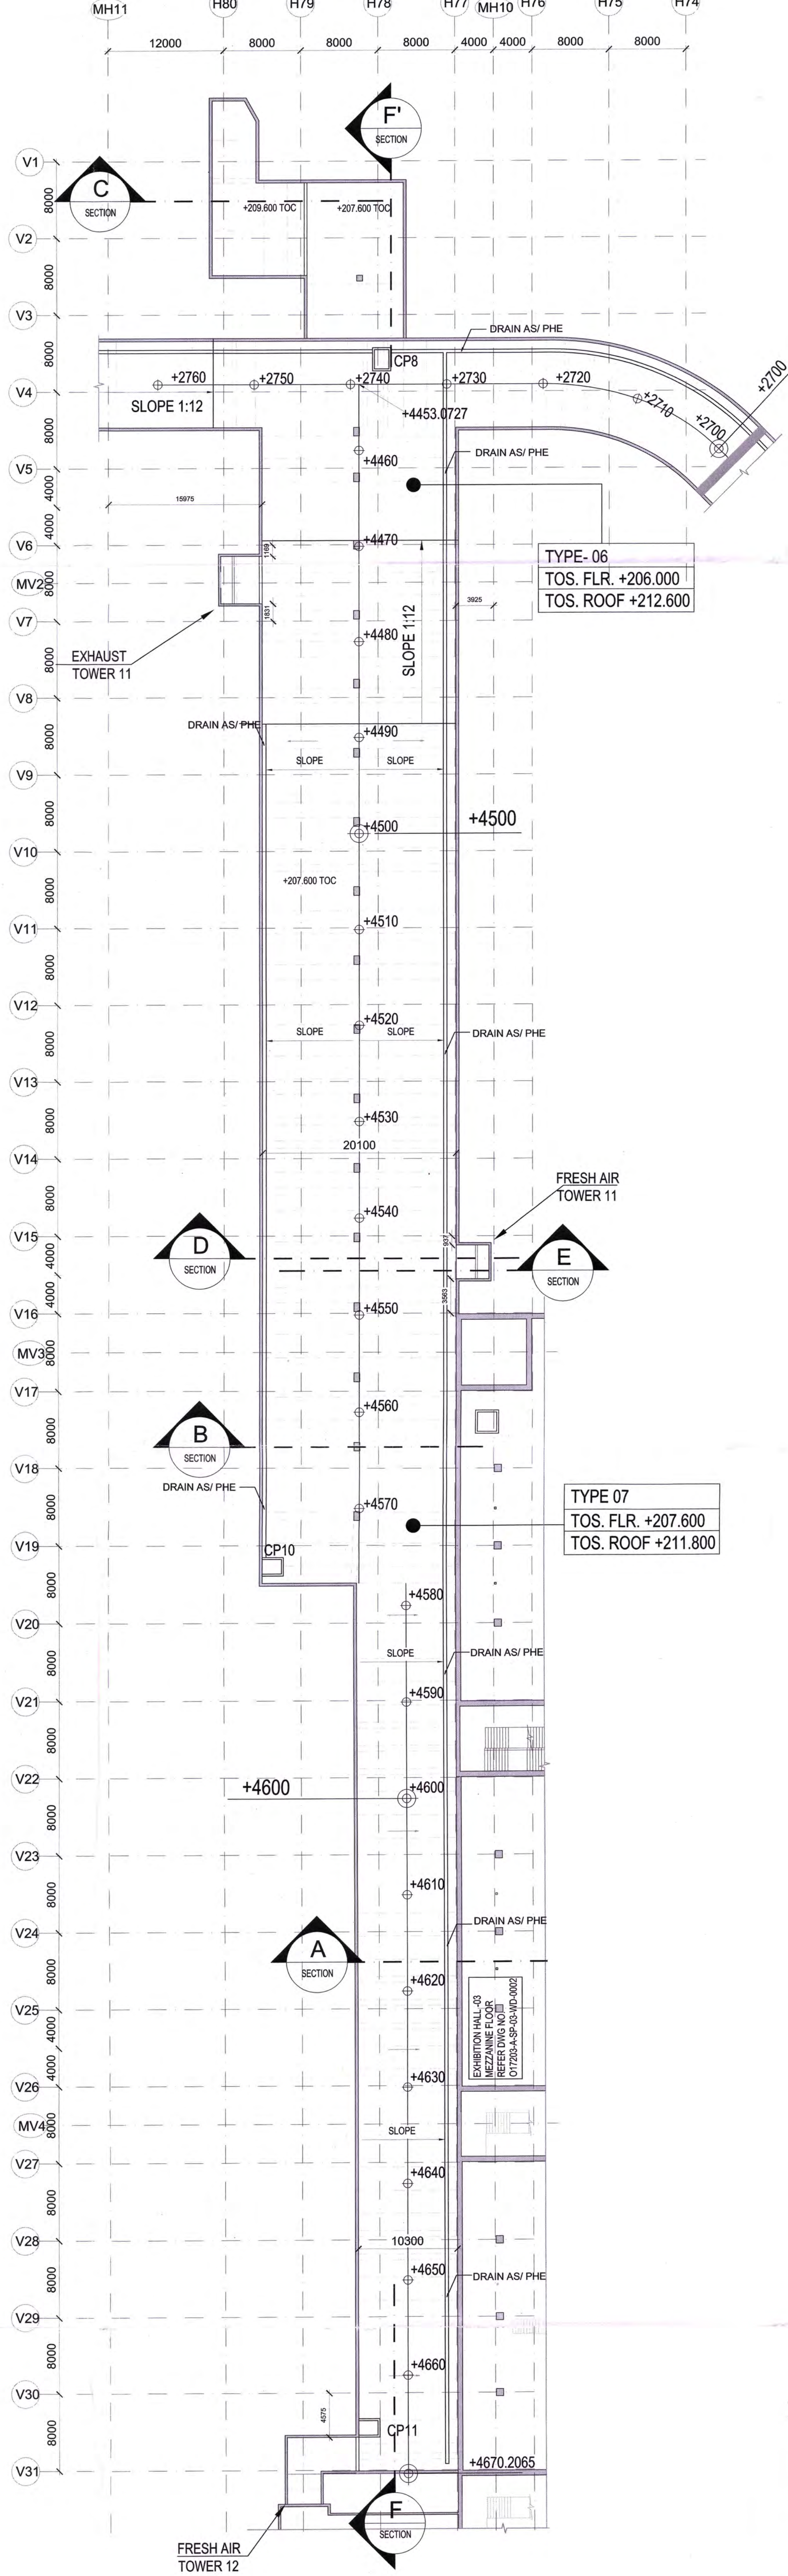


02 -1 BASEMENT PLAN
SCALE: 1:300
A-SP-0A-WD-0117



LEGEND:
RC WALL / COLUMN
300mm THK BLOCK WORK
GRID LINE
FUTURE CONSTRUCTION

ABBREVIATION:
F.F.L. - FINISHED FLOOR LEVEL
P.F.L. - FORMED FLOOR LEVEL
P.F.L. - FORMED PAVEMENT LEVEL
P.H.C. - FIRE HOSE CABINET
L.V. - LEVEL
ELEC. - ELECTRICAL
E.V. - EXTRA LOW VOLTAGE
A.H.U. - AIR HANDLING UNIT
P.H.E. - PUBLIC HEALTH ENGINEERING
F.A. - FRESH AIR
E.A. - EXHAUST AIR

NOTES:
1. ALL DIMENSIONS ARE IN MILLIMETERS, LEVELS IN METERS AND ANGLES IN DEGREES UNLESS OTHERWISE NOTED.
2. THE DRAWING IS TO BE READ AND NOT TO BE SCALED; ONLY WRITTEN DIMENSIONS IN ALL CASES SHALL BE FOLLOWED.
3. THE DRAWING SHALL BE READ IN CONJUNCTION WITH ALL RELEVANT ARCHITECTURAL, STRUCTURAL, AND SERVICE DRAWINGS.
4. ALL DIMENSIONS SHALL BE VERIFIED ON SITE PRIOR TO START OF WORK AND ANY DISCREPANCY SHALL BE BROUGHT TO THE NOTICE OF THE ARCHITECT.
5. ALL SERVICES SHOWN ARE INDICATIVE; REFER MEP DRAWING NO. 017203-01-SP-0A-P-0001, 017203-01-SS-01-04.
6. FOR DETAIL REFER MEP & STRUCTURE DRAWING.
7. READ THIS DWG IN CONJUNCTION WITH DWG 017203-A-SP-0A-WD-0001

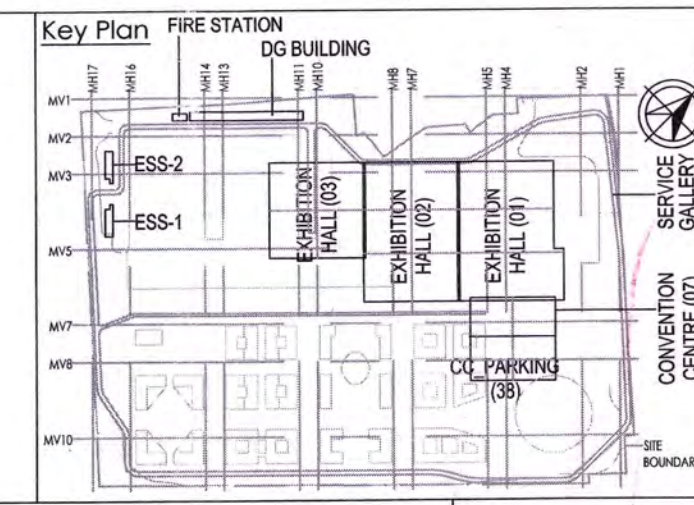

Owner / Employer
Indo International Convention & Exhibition Centre Limited
Room No. 302, Ministry of Commerce & Industry
2/F, Wing 3, New Delhi - 110011, India
Department of Industrial Policy and Promotion Ministry of Commerce & Industry Government of India

Knowledge Partner
Delhi Mumbai Industrial Corridor Development Corporation
Room No. 302, 3rd Floor, New Delhi, India
2/F, Wing 3, New Delhi - 110011, India

Employer's Representative
Employer Engineer
Programme Management Consultant (PMC)
AECOM

Preliminary Engineering Architecture Consultants (PEAC)
idom
idom - International Design Office
Room No. 302, 3rd Floor, New Delhi, India
2/F, Wing 3, New Delhi - 110011, India

EPC Contractor
L&T Construction
Buildings & Factories
Room No. 302, 3rd Floor, New Delhi, India
2/F, Wing 3, New Delhi - 110011, India

EPC Contractor's Representatives
Design Consultant
Engineering Design and Research Center (EDRC)
L&T Construction - Buildings & Factories
Architectural Consultant
ARCOP Associates Pvt. Ltd.
A-15, Panchsheel Park, G-6, 1
New Delhi, India - 110017, India

Structural Proof Consultant
Indian Institute of Technology (IIT) Madras
Sector 25, Dwarka, New Delhi - 110011, India

MEP Proof Consultant
Egis India Consulting Engineers Pvt. Ltd.
Plot No. 44, Sector 25, Institutional Area,
Gurgaon, Haryana - 122001, India

ICT Proof Consultant
CCR Consulting Engineers Pvt. Ltd.
K-171, 3rd Floor, Naraina Arcade,
Suburban, New Delhi - 110028, India

Certification
EPC Contractor
Design Consultant
Architectural Consultant
Proof Consultant
Structural
MEP
ICT

Issued by: Employer / Employer's Engineer

Revision

NO	REASON FOR CONSTRUCTION	DATE	DESIGN	CHKD	APPRO
01	ISSUED AS GOOD FOR CONSTRUCTION	28.08.18	DESIGN	CHKD	APPRO

Revisions

NO	REASON FOR CONSTRUCTION	DATE	DESIGN	CHKD	APPRO
01	ISSUED AS GOOD FOR CONSTRUCTION	28.08.18	DESIGN	CHKD	APPRO

EPC Contractor
L&T Construction
Buildings & Factories

Project Name
DESIGN AND CONSTRUCTION OF INDO INTERNATIONAL CONVENTION & EXPO CENTRE
SECTOR 25, DWARKA, NEW DELHI, INDIA

Drawing Status
GOOD FOR CONSTRUCTION (GFC)

Drawing No
A 0A 0116


Rev. No
R0

Title
SERVICE GALLERY
ADJACENT TO EHS - PLANS

EDRC DWG NO.
017203-A-SP-0A-WD-0116

Scale
1:300

Sheet Size
A0

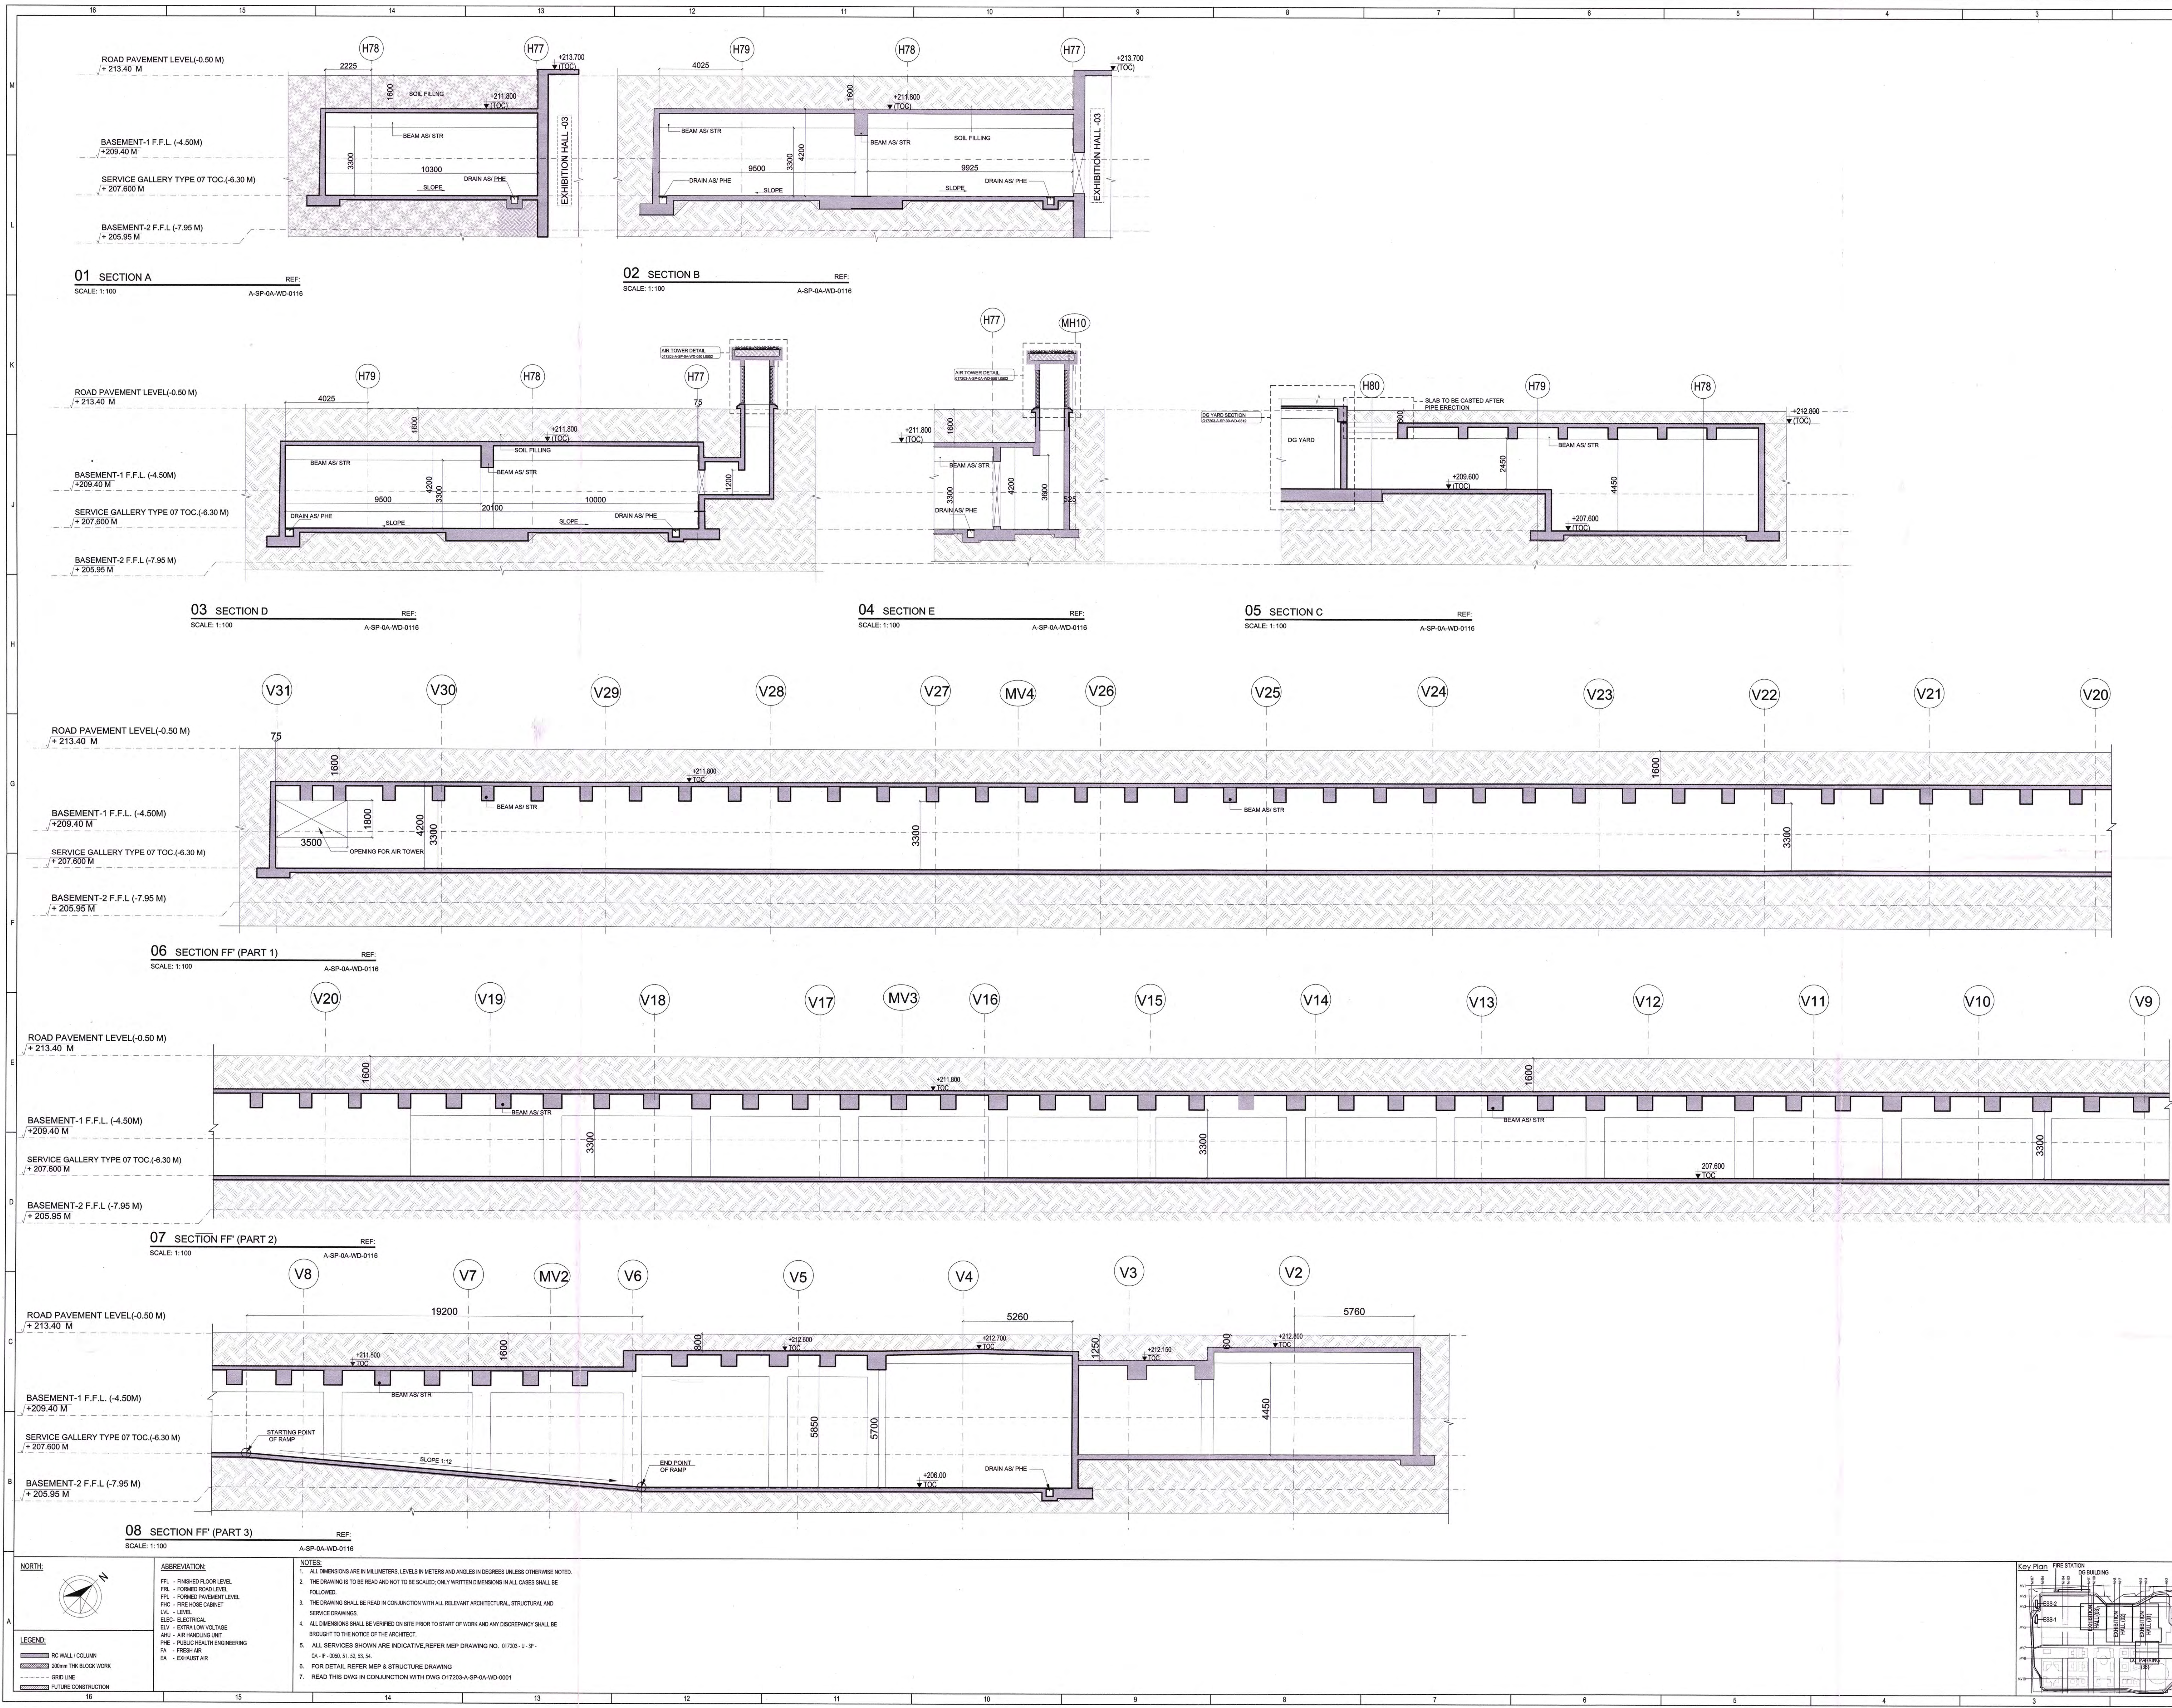

Owner / Employer
India International Convention & Exhibition Centre Limited
Room No. 405A, Ministry of Commerce & Industry, BPO, Lodhi Road, New Delhi - 110011, India

Department of Industrial Policy and Promotion
Ministry of Commerce & Industry
Government of India

Knowledge Partner
Delhi Mumbai Industrial Corridor Development Corporation
Room No. 341 & 3rd Floor New Delhi, 200016 India
New Delhi - 110021

Employer's Representative
Employee Engineer
Programme Management Consultant (PMC)

AECOM
Preliminary Engineering Architecture Consultants (PEAC)

idom
No. D-1, Ashwini Building, Green Park, 200016 India
New Delhi - 110016 India

EPC Contractor
L&T Construction
Buildings & Factories
House No. 100/100A, Connaught Place, New Delhi - 110048 India

EPC Contractor's Representatives
Design Consultant
Engineering Design and Research Center (EDRC)
L&T Construction - Buildings & Factories

Architectural Consultant
ARCO
Arco Associates Pvt. Ltd.
A-13, Panchsheel Enclave, Connaught Place, New Delhi - 110048 India

Structural Proof Consultant
Indian Institute of Technology (IIT) Madras
Sector 8, Opposite to C. L. R. Ash, Chennai, Tamil Nadu - 600036

MEP Proof Consultant
Egis India Consulting Engineers Pvt. Ltd.
Plot No. 44, Sector 22, Institutional Area, Gurgaon, Haryana - 122001

ICT Proof Consultant
CR Consulting Engineers Pvt. Ltd.
H-11, 3rd Floor, Naraina Pocket, Subramanyam Road, New Delhi - 110028

Certification
EPC Contractor
Design Consultant
Architectural Consultant
Proof Consultant
Structural
MEP
ICT
Reviewed: GFC drawing created by Contractor and has been approved by PEAC
Issued by: Signed on behalf of PEAC
Employer / Employer's Engineer

REVISIONS

NO.	DESCRIPTION	DATE	BY	CHKD	APPD
01	ISSUED AS GOOD FOR CONSTRUCTION	20.06.18	VP	HY	MD

Revisions

NO.	DESCRIPTION	DATE	BY	CHKD	APPD
01	ARCHITECTURE		VP		
02	STRUCTURAL		VP		
03	ELECTRICAL		VP		
04	MEP SYSTEM		VP		
05	MEP		VP		
06	MEP		VP		

Checked by: VP Date: 20.06.18

EPC Contractor
L&T Construction
Buildings & Factories

JOB No: O17203

Project Name
DESIGN AND CONSTRUCTION OF INDIA INTERNATIONAL CONVENTION & EXPO CENTRE
SECTOR 25, DWARKA, NEW DELHI, INDIA

Drawing Status
GOOD FOR CONSTRUCTION (GFC)

Drawing No
A 0A 0117

 
 


Rev. No
R0


Title
SERVICE GALLERY
ADJACENT TO EH3 - SECTIONS

EDRC DWG No: O17203-A-SP-QA-WD-0117


Scale
1:100

Sheet Size
A0

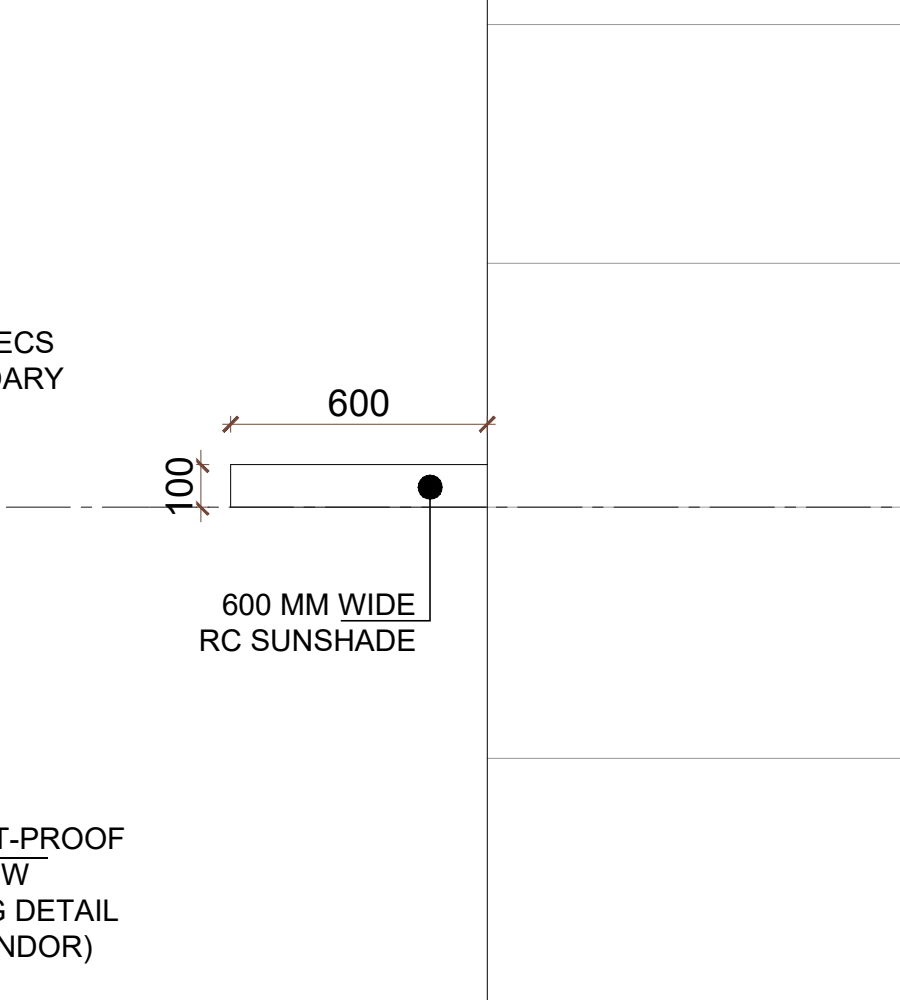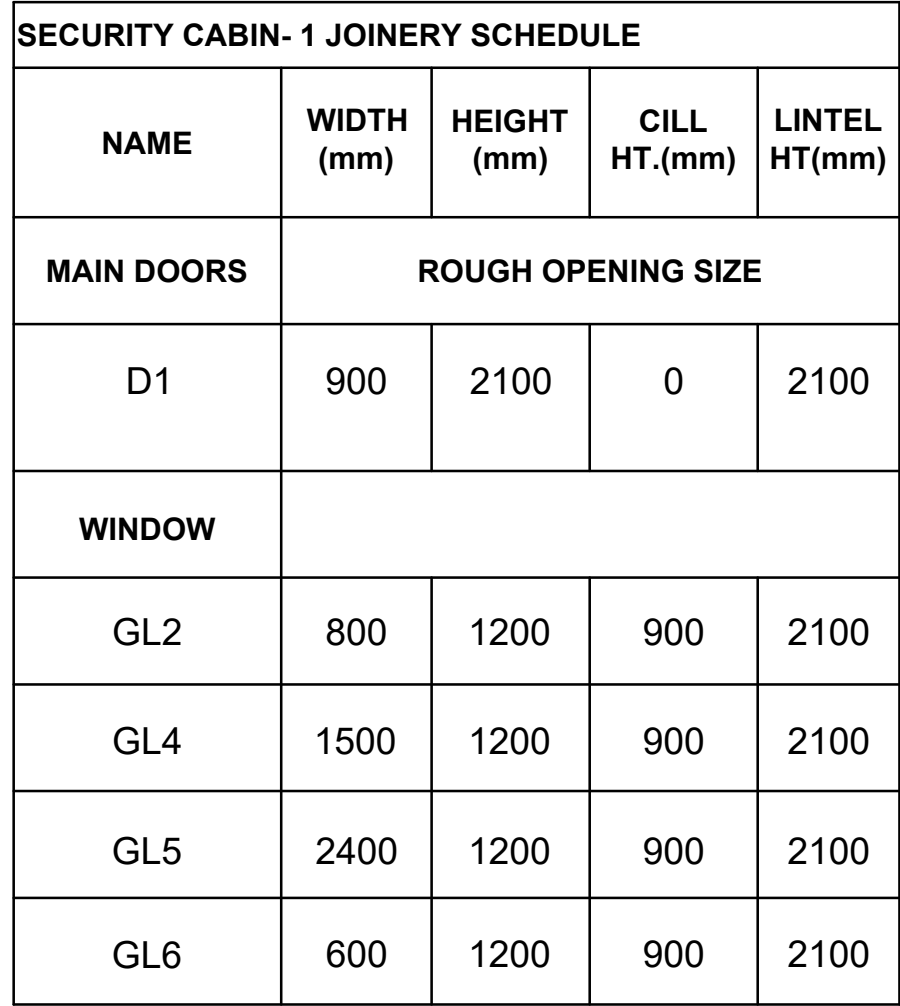

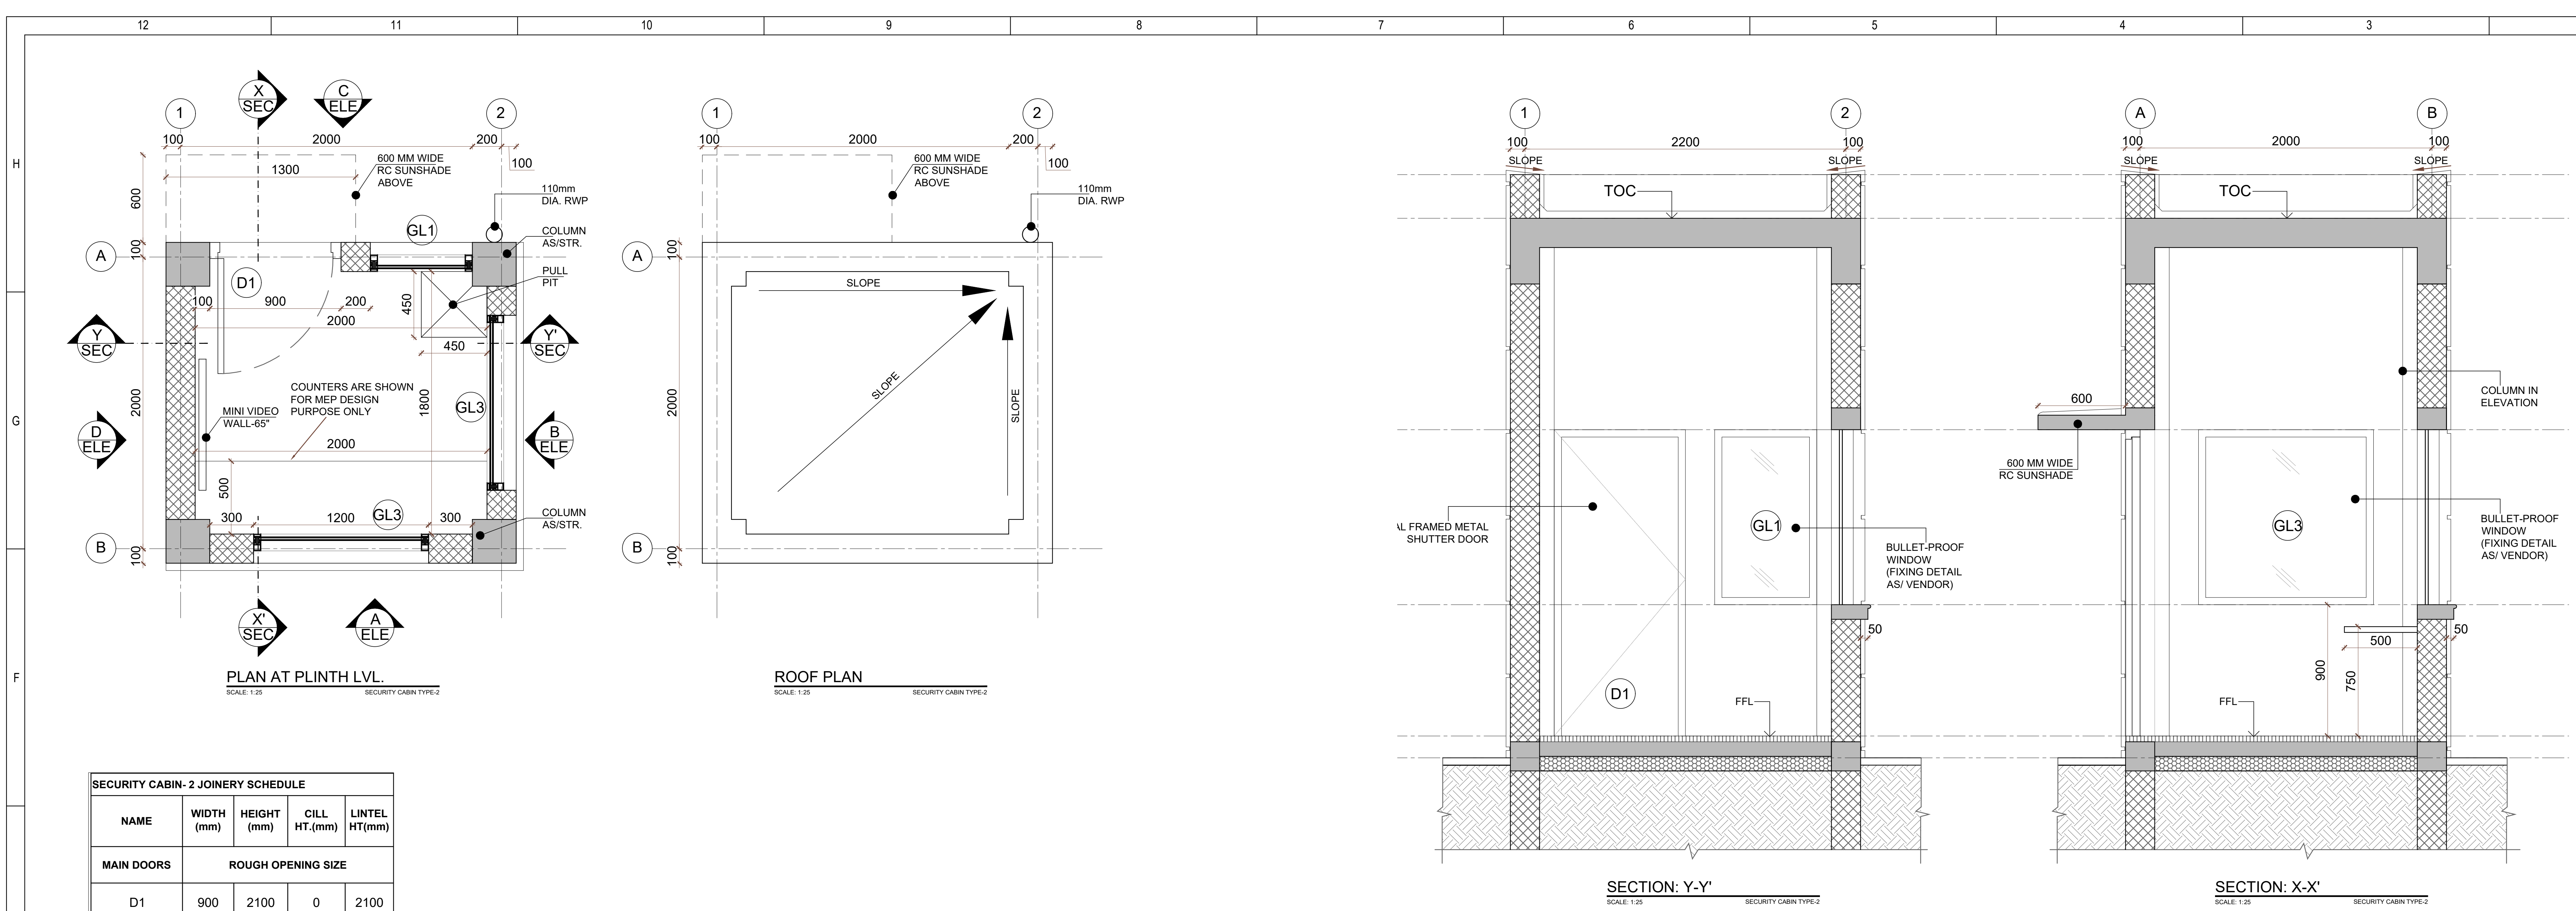

SECURITY CABIN- 2 JOINERY SCHEDULE				
NAME	WIDTH (mm)	HEIGHT (mm)	CILL HT.(mm)	LINTEL HT.(mm)
MAIN DOORS				
D1	900	2100	0	2100
WINDOW				
GL1	700	1200	900	2100
GL3	1200	1200	900	2100

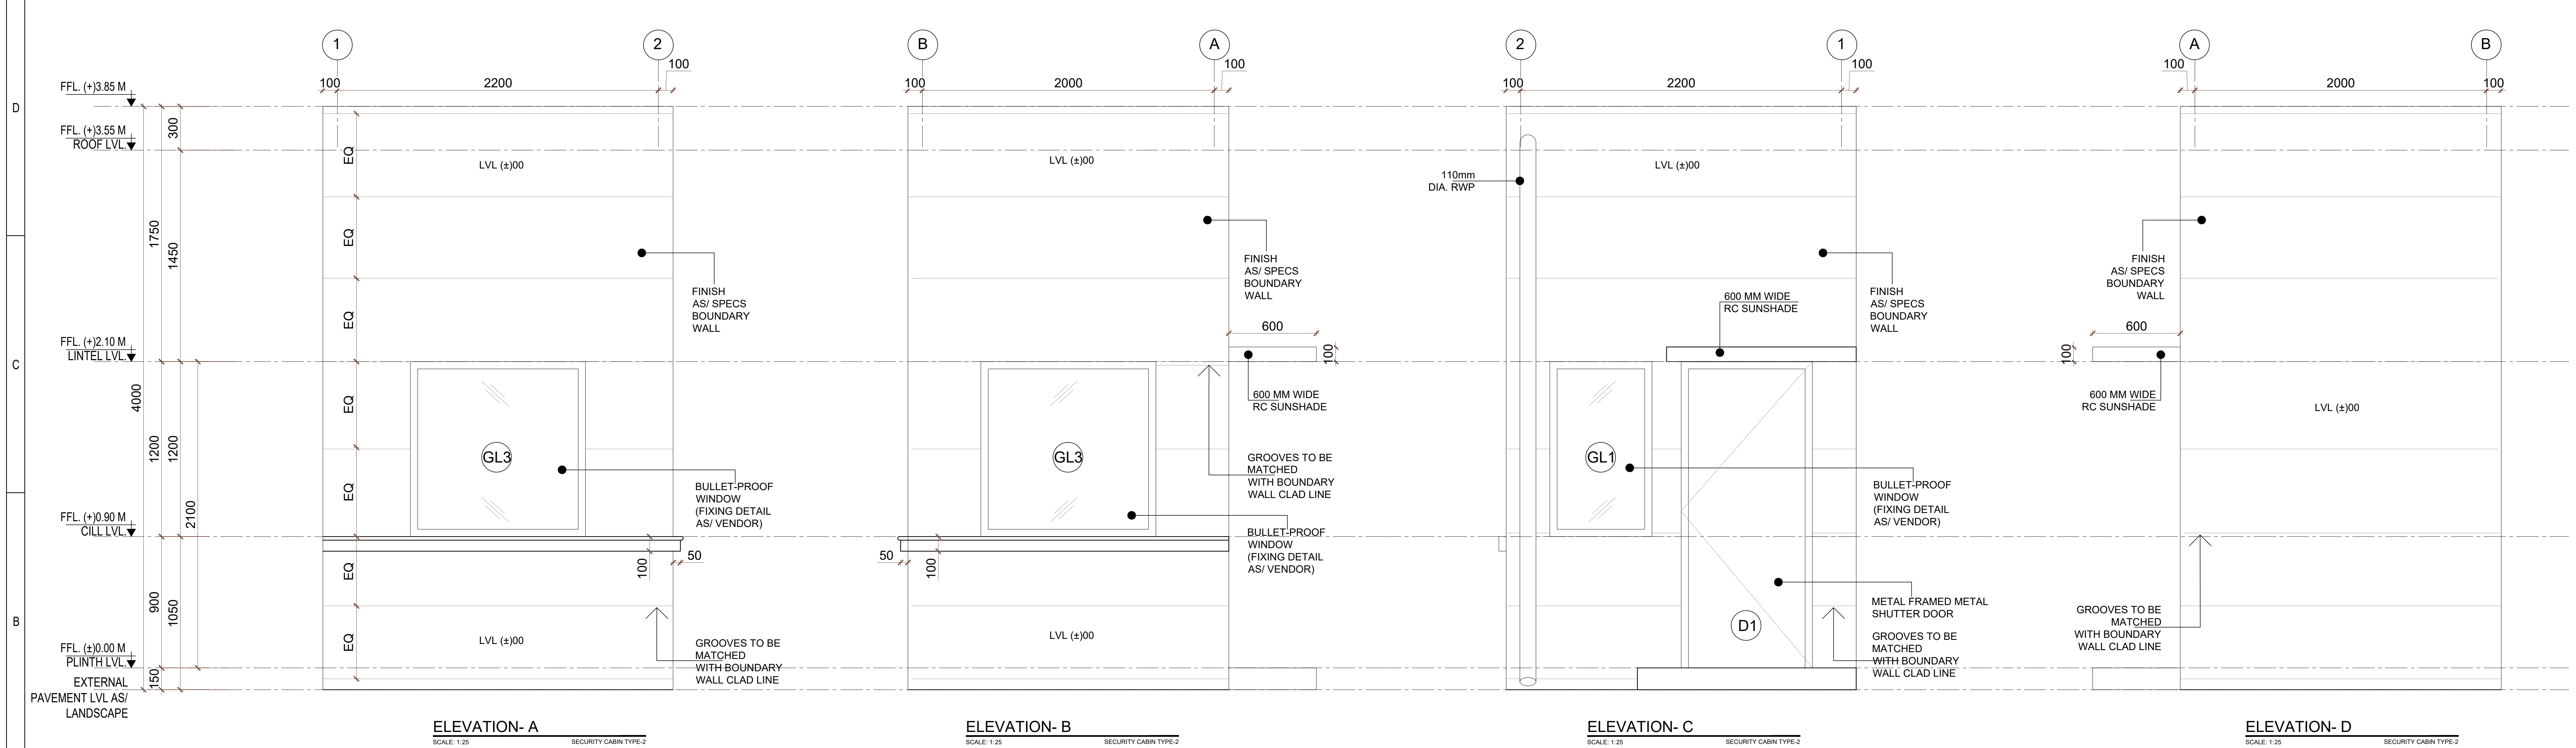

LEGEND:

- RC WALL / COLUMN
- 200mm THK LIGHT WEIGHT BLOCK WORK
- GRID LINE

ABBREVIATION:

FFL - FINISHED FLOOR LEVEL
FRL - FORMED ROAD LEVEL
FPL - FORMED PAVEMENT LEVEL
FHC - FIRE HOSE CABINET
LVL - LEVEL
ELEC - ELECTRICAL
ELV - EXTRA LOW VOLTAGE
AHU - AIR HANDLING UNIT
PHE - PUBLIC HEALTH ENGINEERING
TOC - TOP OF CONCRETE

NOTES:

- ALL DIMENSIONS ARE IN MILLIMETERS. LEVELS IN METERS AND ANGLES IN DEGREES UNLESS OTHERWISE NOTED.
- THE DRAWING IS TO BE READ AND NOT TO BE SCALED; ONLY WRITTEN DIMENSIONS IN ALL CASES SHALL BE FOLLOWED.
- THE DRAWING SHALL BE READ IN CONJUNCTION WITH ALL RELEVANT ARCHITECTURAL, STRUCTURAL AND SERVICE DRAWINGS.
- ALL DIMENSIONS SHALL BE VERIFIED ON SITE PRIOR TO START OF WORK AND ANY DISCREPANCY SHALL BE BROUGHT TO THE NOTICE OF THE ARCHITECT.
- READ THIS DRAWING IN CONJUNCTION WITH 017203-A-SP-00-WD-0003

Key Plan

Diagram showing the location of the security cabin within the site layout, including labels for FIRE STATION, DG BUILDING, EXHIBITION HALL, and CAR PARKING.

Owner / Employer

India International Convention & Exhibition Centre Limited
Room No. 452A, Ministry of Commerce & Industry, DIPP, Udyog Bhawan, New Delhi - 110011, India

Department of Industrial Policy and Promotion
Ministry of Commerce & Industry
Government of India

Knowledge Partner

Delhi Mumbai Industrial Corridor Development Corporation
Room No 341 & 3rd Floor Hotel Ashok, Diplomatic Enclave, 508 Conkhyapuri, New Delhi - 110021

Employer's Representative
Employer's Engineer
Programme Management Consultant (PMC)

AECOM

Preliminary Engineering Architecture Consultants (PEAC)
idom
Av. Del Monasterio de El Escorial, 4, 28049 Madrid, Spain

CPKUREJA ARCHITECTS
No.D-1, Ashwini Building, Green Park, New Delhi, Delhi 110016, India

EPC Contractor

L&T Construction
Buildings & Factories
Mount Poonamallee Road, Manapakkam, P.B.No.979, Chennai - 600 089

EPC Contractor's Representatives

Design Consultant
Engineering Design and Research Center (EDRC)
L&T Construction - Buildings & Factories

Architectural Consultant
ARCOP
Arcop Associates Pvt. Ltd., A-15, Pamposh Enclave, G.K.-1 New Delhi, Delhi 110048, India

Structural Proof Consultant
Indian Institute of Technology (IIT) Madras
Sadar Patel Rd, Opposite to C. L.R.I. Ashar, Chennai, Tamil Nadu 600036

MEP Proof Consultant
Egis India Consulting Engineers Pvt. Ltd.
Plot No. 66, Sector 32, Institutional Area, Opp: Zenatrix Solutions, Gurgaon, Haryana 122001

ICT Proof Consultant
CKR IT Consulting
Bld. No.47/1, 3rd Floor, Narayana Arcade, Subbaramachetty Road, Nerikottappa Circle, Basavanagudi, Bengaluru - 560004

Certification

EPC Contractor

Design Consultant

Architectural Consultant

Proof Consultant

Structural	MEP	ICT
------------	-----	-----

PEAC

Issued by:
Employer / Employer's Engineer

R0	ISSUED FOR GFC	23.04.20	NI	HV	AG	AG
REV	DESCRIPTION	DATE	DSGN	DRWN	CHKD	APPD

Revisions

ARCHITECTURE	PPS				
STRUCTURAL	PHE				
ELECTRICAL	GEOTECH.				
ELV SYSTEM					
HVAC					
CHECKED BY	SIGN	DATE	CHECKED BY	SIGN	DATE

EPC Contractor

L&T Construction
Buildings & Factories

JOB No : 017203

Project Name
DESIGN AND CONSTRUCTION OF INDIA INTERNATIONAL CONVENTION & EXPO CENTRE
SECTOR 25, DWARKA, NEW DELHI, INDIA

Drawing Status
GOOD FOR CONSTRUCTION (GFC)

Drawing No
N 00 0051

Rev. No
R0

Title :


TYPICAL SECURITY CABIN DETAIL-TYPE-2
(CARPET AREA 3.60 SQ. M.)

EDRC DWG No : **017203-N-SP-00-WD-0051**


Scale
1:25

Sheet Size
A1


This drawing is the property of L&T Construction B&F-EDRC and must not be passed on to any person or body not authorised by us to receive it nor be copied or otherwise made use either in full or in part by such person or body without our prior permission in writing.

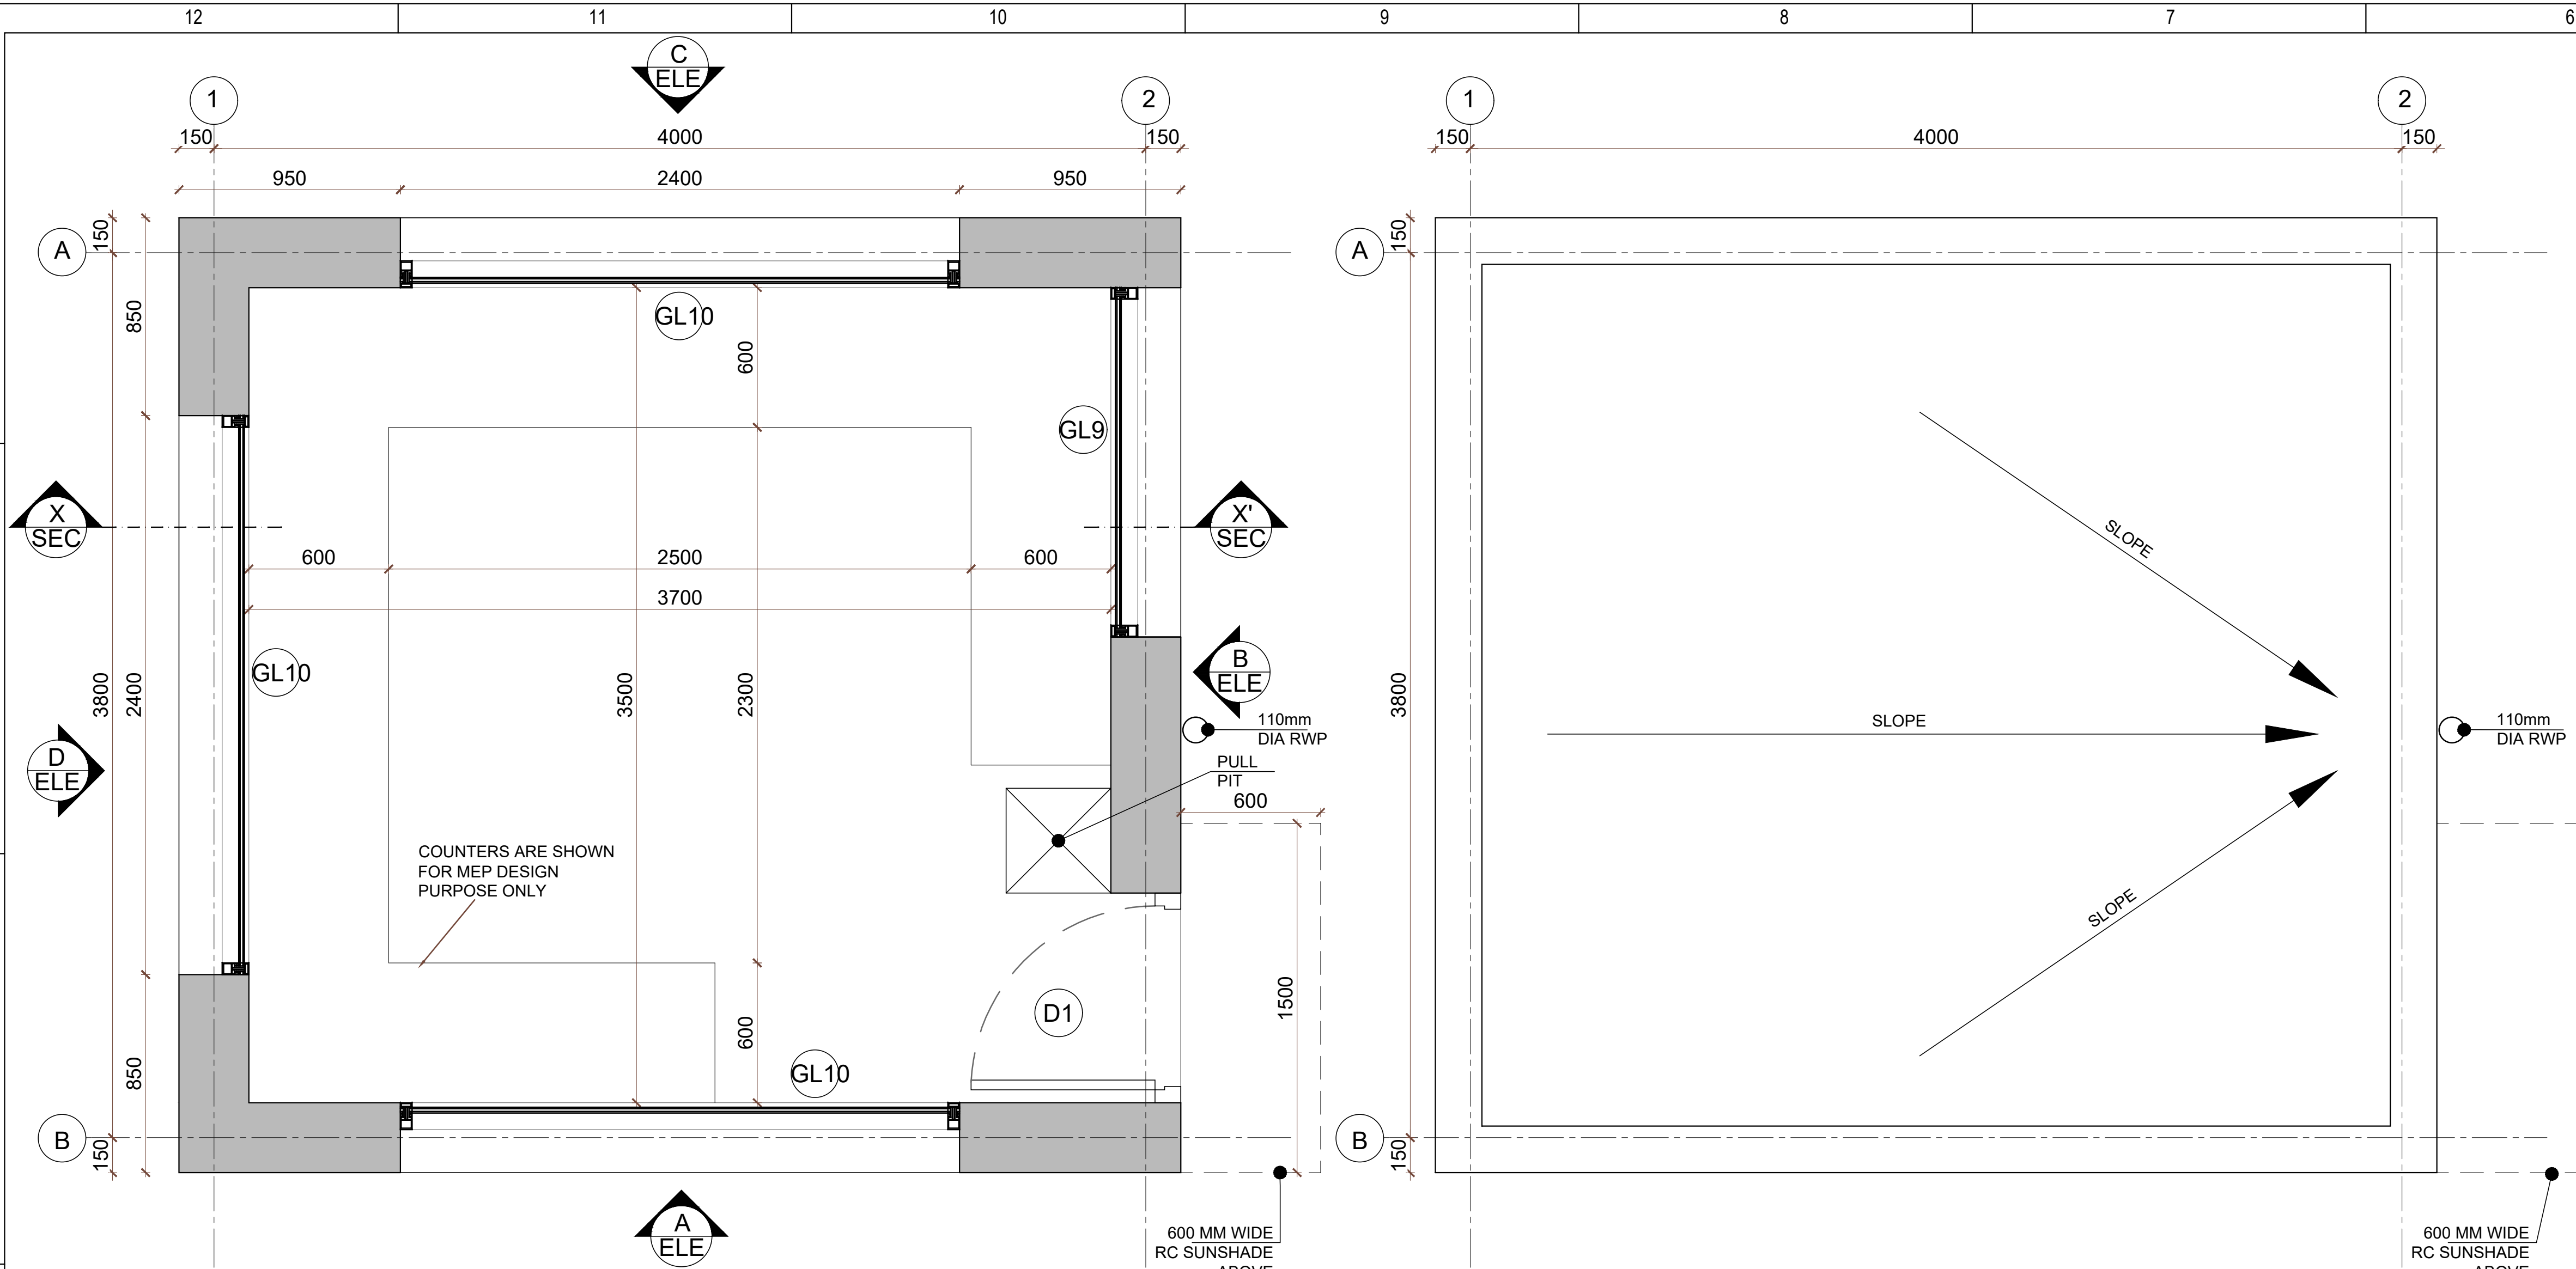

PILL BOX-1 JOINERY SCHEDULE				
NAME	WIDTH (mm)	HEIGHT (mm)	CILL HT.(mm)	LINTEL HT.(mm)
MAIN DOORS				
ROUGH OPENING SIZE				
D1	900	2100	0	2100
WINDOW				
GL9	1500	1200	900	2100
GL10	2400	1200	900	2100

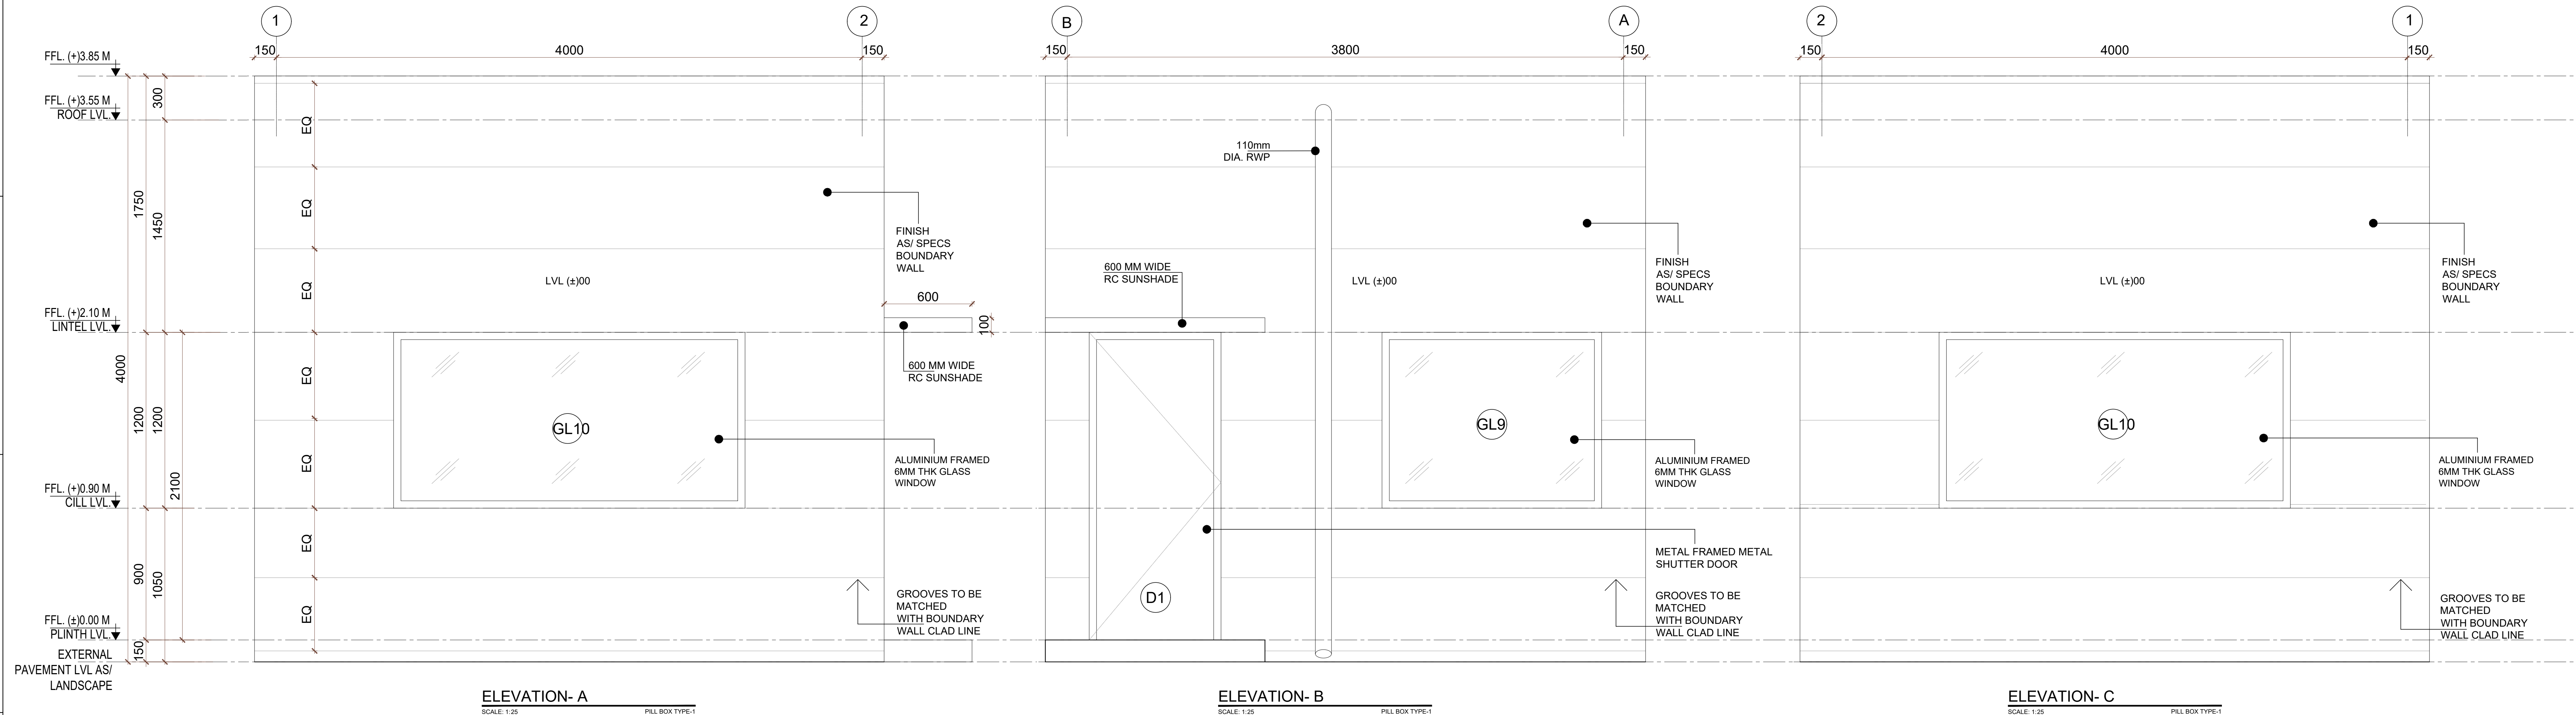

LEGEND: RC WALL / COLUMN 200mm THK LIGHT WEIGHT BLOCK WORK GRID LINE	ABBREVIATION: FFL - FINISHED FLOOR LEVEL FRL - FORMED ROAD LEVEL FPL - FORMED PAVEMENT LEVEL FHC - FIRE HOSE CABINET LVL - LEVEL ELEC - ELECTRICAL ELV - EXTRA LOW VOLTAGE AHU - AIR HANDLING UNIT PHE - PUBLIC HEALTH ENGINEERING TOC - TOP OF CONCRETE	NOTES: 1. ALL DIMENSIONS ARE IN MILLIMETERS, LEVELS IN METERS AND ANGLES IN DEGREES UNLESS OTHERWISE NOTED. 2. THE DRAWING IS TO BE READ AND NOT TO BE SCALED; ONLY WRITTEN DIMENSIONS IN ALL CASES SHALL BE FOLLOWED. 3. THE DRAWING SHALL BE READ IN CONJUNCTION WITH ALL RELEVANT ARCHITECTURAL, STRUCTURAL AND SERVICE DRAWINGS. 4. ALL DIMENSIONS SHALL BE VERIFIED ON SITE PRIOR TO START OF WORK AND ANY DISCREPANCY SHALL BE BROUGHT TO THE NOTICE OF THE ARCHITECT. 5. READ THIS DRAWING IN CONJUNCTION WITH 017203-A-SP-00-WD-0003

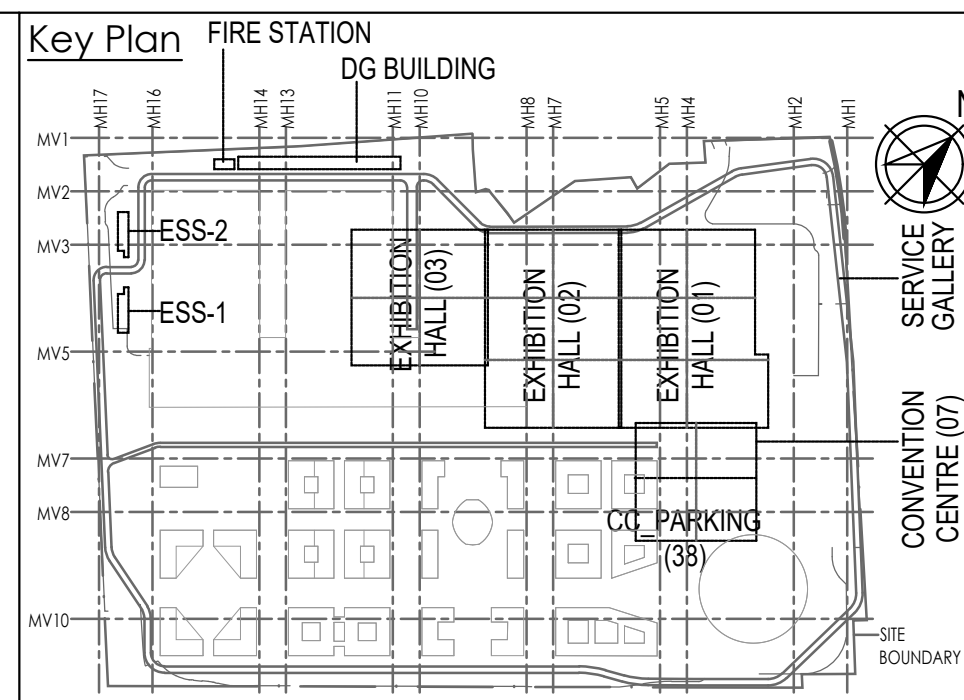

Owner / Employer
India International Convention & Exhibition Centre Limited
Room No. 452A, Ministry of Commerce & Industry, DIPP, Udyog Bhawan, New Delhi - 110011, India
Department of Industrial Policy and Promotion Ministry of Commerce & Industry Government of India

Knowledge Partner
Delhi Mumbai Industrial Corridor Development Corporation
Room No. 341 B, 3rd Floor Hotel Ashok, Diplomatic Enclave, 508 Connaught Place, New Delhi - 110021

Employer's Representative
Employer's Engineer
Programme Management Consultant (PMC)

AECOM
Preliminary Engineering Architecture Consultants (PEAC)
Av. Del Monasterio de El Escorial, 4, 28049 Madrid, Spain
No.D-1, Ashirwad Building, Green Park, New Delhi, Delhi 110016, India

EPC Contractor
L&T Construction
Buildings & Factories
Mount Poornamallee Road, Manappakkam, P.B.No.979, Chennai - 600 089

EPC Contractor's Representatives
Design Consultant
Engineering Design and Research Center (EDRC)
L&T Construction - Buildings & Factories
Architectural Consultant
ARCOP
Arcop Associates Pvt. Ltd., A-15, Pamposh Enclave, G.K.-1 New Delhi, Delhi 110048, India

Structural Proof Consultant
Indian Institute of Technology (IIT) Madras
Sardar Patel Rd, Opposite to C. L.R.I, Adyar, Chennai, Tamil Nadu 600036

MEP Proof Consultant
Egis India Consulting Engineers Pvt. Ltd.
Plot No. 66, Sector 32, Institutional Area, Opp: Zenatrix Solutions, Gurgaon, Haryana 122001

ICT Proof Consultant
CKR IT Consulting
Bld. No.47/1, 3rd Floor, Narayana Arcade, Subbaramachetty Road, Nerikolappa Circle, Basavanagudi, Bengaluru - 560004

Certification		
EPC Contractor		
Design Consultant		
Architectural Consultant		
Proof Consultant		
<u>Structural</u>	<u>MEP</u>	<u>ICT</u>
PEAC		
Issued by:		
Employer / Employer's Engineer		

Revisions	PPS		
ARCHITECTURE	PHE		
STRUCTURAL	GEO TECH.		
ELECTRICAL			
ELV SYSTEM			
HVAC			
CHECKED BY	SIGN	DATE	CHECKED BY
	SIGN	DATE	

EPC Contractor	
JOB No : 017203	
Project Name	
DESIGN AND CONSTRUCTION OF INDIA INTERNATIONAL CONVENTION & EXPO CENTRE	
SECTOR 25, DWARKA, NEW DELHI, INDIA	
Drawing Status	
GOOD FOR CONSTRUCTION (GFC)	
Drawing No	Rev. No
N 00 0052	R0

Title :		
TYPICAL PILL BOX DETAIL- TYPE-1 (CARPET AREA - 12.95 SQ.M)		
EDRC DWG No : 017203-N-SP-00-WD-0052	Scale 1:25	Sheet Size A1