



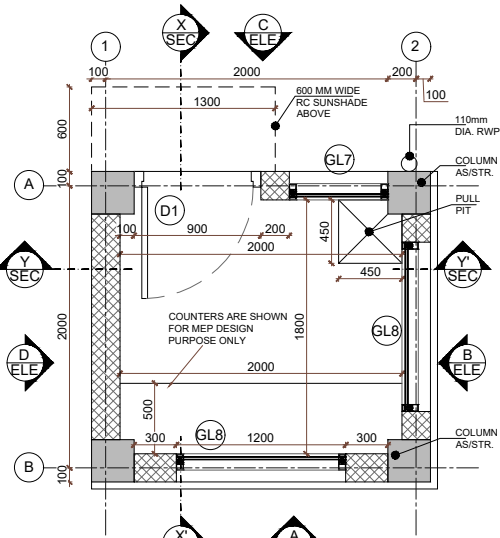


PLAN AT PLINTH LVL.
SCALE: 1:25
PILL BOX TYPE-2

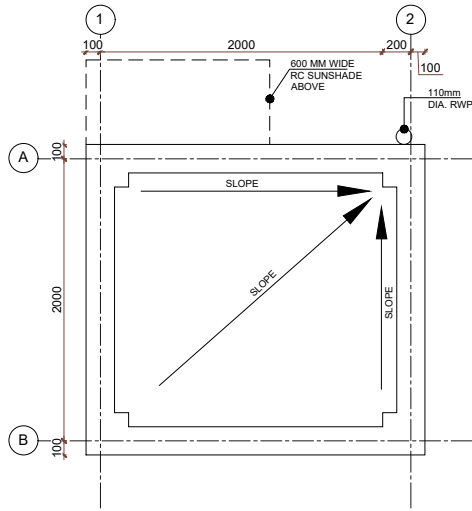


ROOF PLAN
SCALE: 1:25
PILL BOX TYPE-2


PILL BOX-2 JOINERY SCHEDULE				
NAME	WIDTH (mm)	HEIGHT (mm)	CILL HT. (mm)	LINTEL HT. (mm)
MAIN DOORS				
ROUGH OPENING SIZE				
D1	900	2100	0	2100
WINDOW				
GL7	700	1200	900	2100
GL8	1200	1200	900	2100

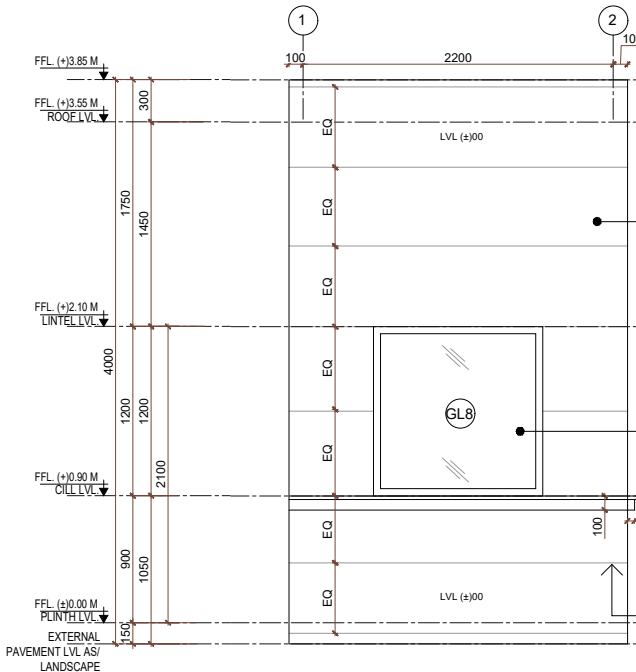


ELEVATION-A
SCALE: 1:25
PILL BOX TYPE-2

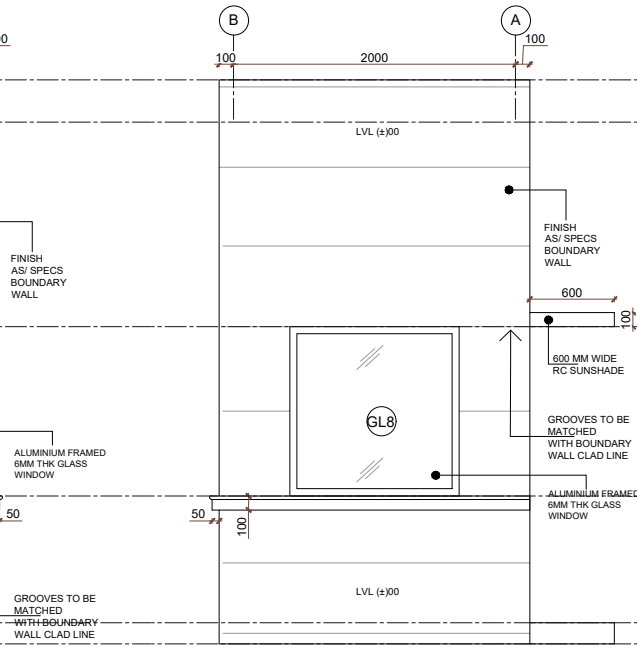

ELEVATION-B
SCALE: 1:25
PILL BOX TYPE-2

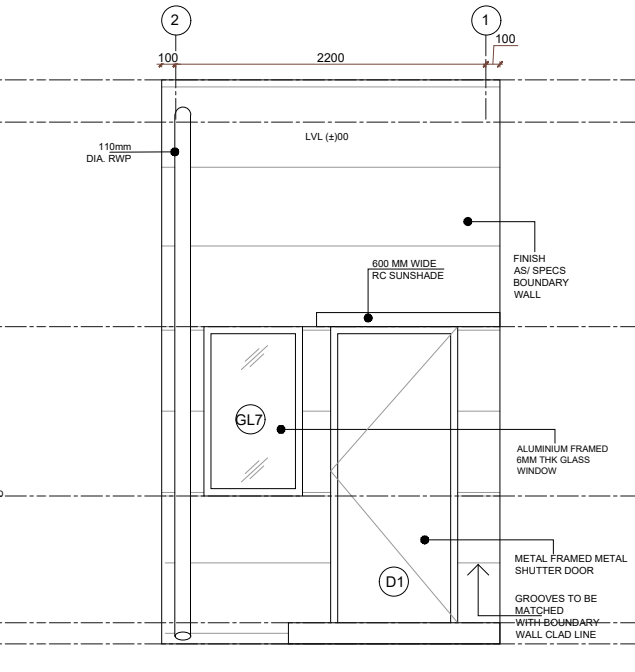

ELEVATION-C
SCALE: 1:25
PILL BOX TYPE-2

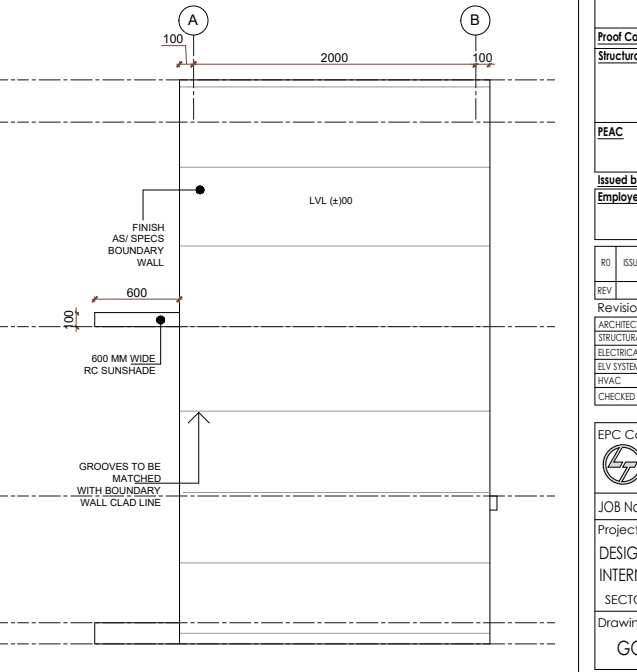


ELEVATION-D
SCALE: 1:25
PILL BOX TYPE-2


ABBREVIATION:	
FFL	- FINISHED FLOOR LEVEL
FRL	- FORMED ROAD LEVEL
FPL	- FORMED PAVEMENT LEVEL
FHC	- FIRE HOSE CABINET
LVL	- LEVEL
ELEC	- ELECTRICAL
ELV	- EXTRA LOW VOLTAGE
AHU	- AIR HANDLING UNIT
PHE	- PUBLIC HEALTH ENGINEERING
TOC	- TOP OF CONCRETE

NOTES:	
1.	ALL DIMENSIONS ARE IN MILLIMETERS, LEVELS IN METERS AND ANGLES IN DEGREES UNLESS OTHERWISE NOTED.
2.	THE DRAWING IS TO BE READ AND NOT TO BE SCALED; ONLY WRITTEN DIMENSIONS IN ALL CASES SHALL BE FOLLOWED.
3.	THE DRAWING SHALL BE READ IN CONJUNCTION WITH ALL RELEVANT ARCHITECTURAL, STRUCTURAL AND SERVICE DRAWINGS.
4.	ALL DIMENSIONS SHALL BE VERIFIED ON SITE PRIOR TO START OF WORK AND ANY DISCREPANCY SHALL BE BROUGHT TO THE NOTICE OF THE ARCHITECT.
5.	READ THIS DRAWING IN CONJUNCTION WITH 017203-A-SP-00-WD-0003

LEGEND:	
	RC WALL / COLUMN
	200mm THK LIGHT WEIGHT BLOCK WORK
	GRID LINE

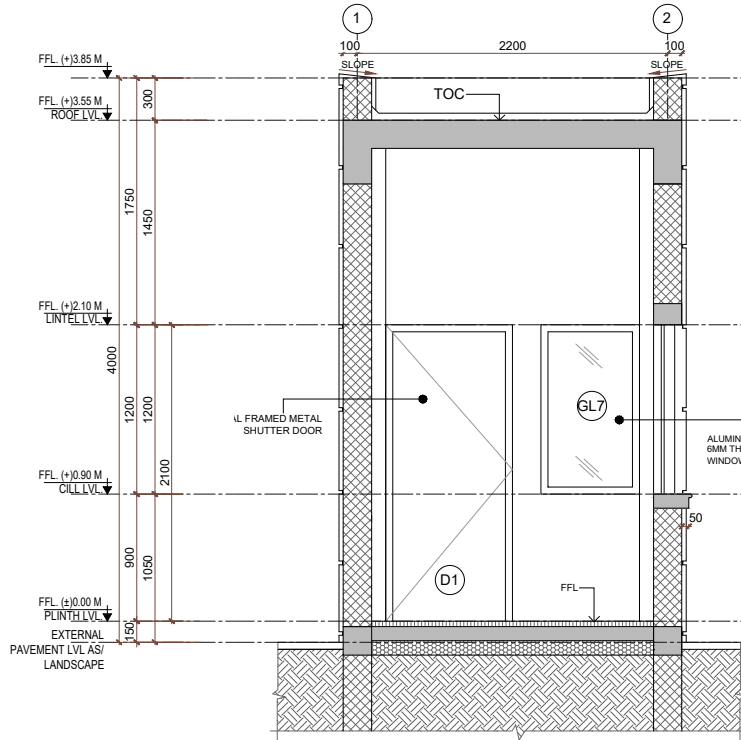

SECTION: Y-Y'
SCALE: 1:25
PILL BOX TYPE-2

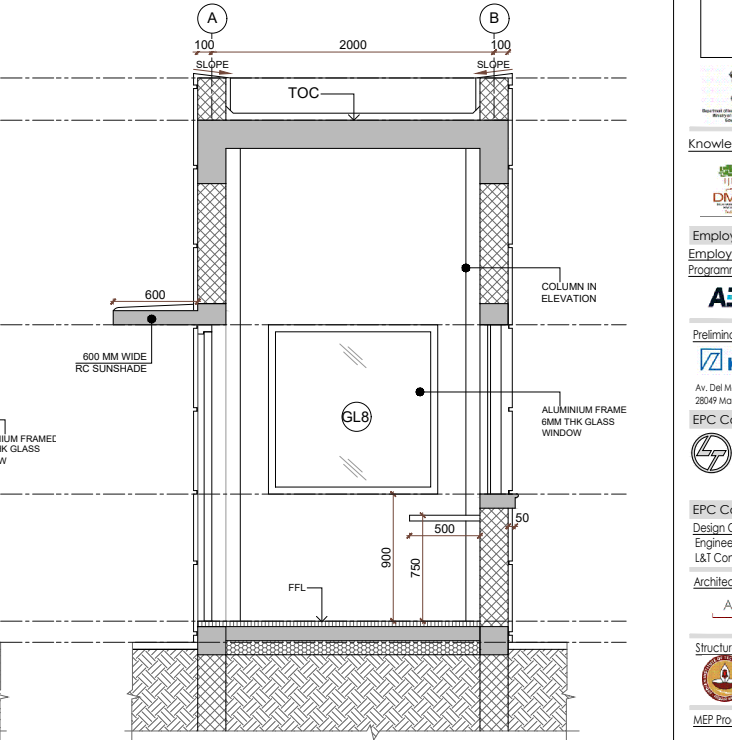

SECTION: X-X'
SCALE: 1:25
PILL BOX TYPE-2

Owner / Employer

India International Convention & Exhibition Centre Limited
Room No. 452A, Ministry of Commerce & Industry,
DIP, Udyog Bhawan, New Delhi - 110011, India

Department of Industrial Policy and Promotion Ministry of Commerce & Industry Government of India

Knowledge Partner

Delhi Mumbai Industrial Corridor Development Corporation
Room No 341 8, 3rd Floor Hotel Ashok, Diplomatic Enclave, 5/8 Chankyapuri, New Delhi - 110021

Employer's Representative

Employer's Engineer
Programme Management Consultant (PMC)

AECOM

Preliminary Engineering Architecture Consultants (PEAC)

idom **CPKUREJA**
Av. Del Montecarlo de El Escorial, 4, No D-1, Ashwini Building, Green Park, 28049 Madrid, Spain
New Delhi, Delhi 110016, India

EPC Contractor

L&T Construction
Buildings & Factories
Mount Poonamallee Road, Manapakkam, P.O. No. 77, Chennai - 600 089

EPC Contractor's Representatives

Design Consultant
Engineering Design and Research Center (EDRC)
L&T Construction - Buildings & Factories

Architectural Consultant

ARCOP Arcop Associates Pvt. Ltd.
A-13, Pampore Enclave, G.K.-1 New Delhi, Delhi 110046, India

Structural Proof Consultant

Indian Institute of Technology (IIT) Madras
Sardar Patel Rd. Opposite to C. L.R.I. Adyar, Chennai, Tamil Nadu - 600036

MEP Proof Consultant

Egis India Consulting Engineers Pvt. Ltd.
Plot No. 66, Sector 32, Institutional Area, Opp. Zensar Solutions, Gurugram, Haryana 122001

ICT Proof Consultant

CKR IT Consulting
Bld. No.47/1, 3rd Floor, Narayana Arcade, Subaramachetty Road, Nellore, Andhra Pradesh, Basavanagudi, Bengaluru - 560004

Certification

EPC Contractor

Design Consultant

Architectural Consultant

Proof Consultant

Structural	MEP	ICT

PEAC

Issued by:

Employer / Employer's Engineer

RD	ISSUED FOR GFC	23.04.20	NI	HV	AG	AG
REV	DESCRIPTION	DATE	DSGN	DRWN	CHKD	APPD

Revisions

ARCHITECTURE			FFS			
STRUCTURAL			PHE			
ELECTRICAL			GEOTECH			
ENVIRONMENTAL						
MECHANICAL						
CHECKED BY	SIGN	DATE	CHECKED BY	SIGN	DATE	

EPC Contractor

L&T Construction
Buildings & Factories

JOB No: O17203

Project Name

DESIGN AND CONSTRUCTION OF INDIA INTERNATIONAL CONVENTION & EXPO CENTRE
SECTOR 25, DWARKA, NEW DELHI, INDIA

Drawing Status

GOOD FOR CONSTRUCTION (GFC)

Drawing No

N 00 0053

Rev. No

R0

Title:

TYPICAL PILL BOX DETAIL- TYPE-2
(CARPET AREA 3.60 SQ. M.)

EDRC DWG No:


O17203-N-SP-00-WD-0053

Scale

1:25

Sheet Size

A1

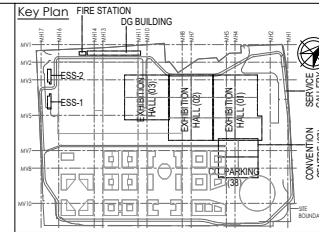

This drawing is the property of L&T Construction. B&F-EDRC and must not be passed on to any person or body not authorised by us to receive it nor be copied or otherwise made use either in full or in part by such person or body without our prior permission in writing.

8	7	6	5	4	3	2	1																																																																																																																																																															
SECURITY CABIN- 1 & 2- JOINERY SCHEDULE <table><thead><tr><th>NAME</th><th>DESCRIPTION</th><th>WIDTH (mm)</th><th>HEIGHT (mm)</th><th>CILL HT.(mm)</th><th>LINTEL HT(mm)</th></tr></thead><tbody><tr><td colspan="2">MAIN DOORS</td><td colspan="4">ROUGH OPENING SIZE</td></tr><tr><td>D1</td><td>METAL FRAMED METAL SHUTTER DOOR</td><td>900</td><td>2100</td><td>0</td><td>2100</td></tr><tr><td colspan="2">WINDOW</td><td colspan="4"></td></tr><tr><td>GL1</td><td>BULLET-PROOF WINDOW</td><td>700</td><td>1200</td><td>900</td><td>2100</td></tr><tr><td>GL2</td><td>BULLET-PROOF WINDOW</td><td>800</td><td>1200</td><td>900</td><td>2100</td></tr><tr><td>GL3</td><td>BULLET-PROOF WINDOW</td><td>1200</td><td>1200</td><td>900</td><td>2100</td></tr><tr><td>GL4</td><td>BULLET-PROOF WINDOW</td><td>1500</td><td>1200</td><td>900</td><td>2100</td></tr><tr><td>GL5</td><td>BULLET-PROOF WINDOW</td><td>2400</td><td>1200</td><td>900</td><td>2100</td></tr><tr><td>GL6</td><td>BULLET-PROOF WINDOW</td><td>600</td><td>1200</td><td>900</td><td>2100</td></tr></tbody></table> PILL BOX-1 & 2- JOINERY SCHEDULE <table><thead><tr><th>NAME</th><th>DESCRIPTION</th><th>WIDTH (mm)</th><th>HEIGHT (mm)</th><th>CILL HT.(mm)</th><th>LINTEL HT(mm)</th></tr></thead><tbody><tr><td colspan="2">MAIN DOORS</td><td colspan="4">ROUGH OPENING SIZE</td></tr><tr><td>D1</td><td>METAL FRAMED METAL SHUTTER DOOR</td><td>900</td><td>2100</td><td>0</td><td>2100</td></tr><tr><td colspan="2">WINDOW</td><td colspan="4"></td></tr><tr><td>GL7</td><td>ALUMINIUM FRAMED 6MM THK GLASS WINDOW</td><td>700</td><td>1200</td><td>900</td><td>2100</td></tr><tr><td>GL8</td><td>ALUMINIUM FRAMED 6MM THK GLASS WINDOW</td><td>1200</td><td>1200</td><td>900</td><td>2100</td></tr><tr><td>GL9</td><td>ALUMINIUM FRAMED 6MM THK GLASS WINDOW</td><td>1500</td><td>1200</td><td>900</td><td>2100</td></tr><tr><td>GL10</td><td>ALUMINIUM FRAMED 6MM THK GLASS WINDOW</td><td>2400</td><td>1200</td><td>900</td><td>2100</td></tr></tbody></table>						NAME	DESCRIPTION	WIDTH (mm)	HEIGHT (mm)	CILL HT.(mm)	LINTEL HT(mm)	MAIN DOORS		ROUGH OPENING SIZE				D1	METAL FRAMED METAL SHUTTER DOOR	900	2100	0	2100	WINDOW						GL1	BULLET-PROOF WINDOW	700	1200	900	2100	GL2	BULLET-PROOF WINDOW	800	1200	900	2100	GL3	BULLET-PROOF WINDOW	1200	1200	900	2100	GL4	BULLET-PROOF WINDOW	1500	1200	900	2100	GL5	BULLET-PROOF WINDOW	2400	1200	900	2100	GL6	BULLET-PROOF WINDOW	600	1200	900	2100	NAME	DESCRIPTION	WIDTH (mm)	HEIGHT (mm)	CILL HT.(mm)	LINTEL HT(mm)	MAIN DOORS		ROUGH OPENING SIZE				D1	METAL FRAMED METAL SHUTTER DOOR	900	2100	0	2100	WINDOW						GL7	ALUMINIUM FRAMED 6MM THK GLASS WINDOW	700	1200	900	2100	GL8	ALUMINIUM FRAMED 6MM THK GLASS WINDOW	1200	1200	900	2100	GL9	ALUMINIUM FRAMED 6MM THK GLASS WINDOW	1500	1200	900	2100	GL10	ALUMINIUM FRAMED 6MM THK GLASS WINDOW	2400	1200	900	2100	Owner / Employer India International Convention & Exhibition Centre Limited Room No. 452A, Ministry of Commerce & Industry, DPP, Udyog Bhawan, New Delhi - 110011, India Department of Industrial Policy and Promotion Ministry of Commerce & Industry Government of India Knowledge Partner Delhi Mumbai Industrial Corridor Development Corporation Room No 341 B, 3rd Floor Hotel Ashok, Diplomatic Enclave, 508 Chanakyapuri, New Delhi - 110021 Employer's Representative Employer Engineer Programme Management Consultant (PMC) AECOM Preliminary Engg. Architecture Consultants (PEAC) EPC Contractor L&T Construction Buildings & Factories Mount Poonamallee Road, Manapakkam, P.B.No.979, Chennai – 600 089 EPC Contractor's Representatives Design Consultant Engineering Design and Research Center (EDRC) L&T Construction - Buildings & Factories Architectural Consultant ARCOP Arcop Associates Pvt. Ltd. A-15, Pamposh Enclave, G.K.-1 New Delhi, Delhi 110048, India Structural Proof Consultant Indian Institute of Technology (IIT) Madras Sadar Patel Rd. Opposite to C. L.R.I, Adyar, Chennai, Tamil Nadu 600036 MEP Proof Consultant Egis India Consulting Engineers Pvt. Ltd. Plot No. 66, Sector 32, Institutional Area, Opp: Zenatix Solutions, Gurugram, Haryana 122001 ICT Proof Consultant CKR Consulting Engineers Pvt. Ltd. #47/1, 3rd Floor, Narayana Arcade, Subbaramachetty Road, Netkalappa Circle, Basavanagudi, Bengaluru - 560004 <table><tr><td>R0</td><td>ISSUED AS GOOD FOR CONSTRUCTION</td><td>23.06.20</td><td>NI</td><td>HV</td><td>AG</td><td>AG</td></tr><tr><td>REV</td><td>DESCRIPTION</td><td>DATE</td><td>DSGN</td><td>DRWN</td><td>CHKD</td><td>APPD</td></tr></table> Revisions <table><tr><td>ARCHITECTURE</td><td></td><td></td><td>FPS</td><td></td><td></td></tr><tr><td>STRUCTURAL</td><td></td><td></td><td>PIPING</td><td></td><td></td></tr><tr><td>ELECTRICAL</td><td></td><td></td><td>PHE</td><td></td><td></td></tr><tr><td>ELV SYSTEM</td><td></td><td></td><td>GIS</td><td></td><td></td></tr><tr><td>HVAC</td><td></td><td></td><td>GEOTECH.</td><td></td><td></td></tr><tr><td>CHECKED BY</td><td>SIGN</td><td>DATE</td><td>CHECKED BY</td><td>SIGN</td><td>DATE</td></tr></table> EPC Contractor L&T Construction Buildings & Factories JOB No : O17203 Project Name DESIGN AND CONSTRUCTION OF INDIA INTERNATIONAL CONVENTION & EXPO CENTRE SECTOR 25, DWARKA, NEW DELHI, INDIA Drawing Status GOOD FOR CONSTRUCTION (GFC) Drawing No Rev. No N 00 0054 R0 Title : SECURITY CABIN TYPE-1 & 2 AND PILL BOX TYPE-1 & 2 DOOR & WINDOW SCHEDULE EDRC DWG No : Scale : Sheet Size O17203-N-SP-00-WD-0054 NTS A3		R0	ISSUED AS GOOD FOR CONSTRUCTION	23.06.20	NI	HV	AG	AG	REV	DESCRIPTION	DATE	DSGN	DRWN	CHKD	APPD	ARCHITECTURE			FPS			STRUCTURAL			PIPING			ELECTRICAL			PHE			ELV SYSTEM			GIS			HVAC			GEOTECH.			CHECKED BY	SIGN	DATE	CHECKED BY	SIGN	DATE	1
NAME	DESCRIPTION	WIDTH (mm)	HEIGHT (mm)	CILL HT.(mm)	LINTEL HT(mm)																																																																																																																																																																	
MAIN DOORS		ROUGH OPENING SIZE																																																																																																																																																																				
D1	METAL FRAMED METAL SHUTTER DOOR	900	2100	0	2100																																																																																																																																																																	
WINDOW																																																																																																																																																																						
GL1	BULLET-PROOF WINDOW	700	1200	900	2100																																																																																																																																																																	
GL2	BULLET-PROOF WINDOW	800	1200	900	2100																																																																																																																																																																	
GL3	BULLET-PROOF WINDOW	1200	1200	900	2100																																																																																																																																																																	
GL4	BULLET-PROOF WINDOW	1500	1200	900	2100																																																																																																																																																																	
GL5	BULLET-PROOF WINDOW	2400	1200	900	2100																																																																																																																																																																	
GL6	BULLET-PROOF WINDOW	600	1200	900	2100																																																																																																																																																																	
NAME	DESCRIPTION	WIDTH (mm)	HEIGHT (mm)	CILL HT.(mm)	LINTEL HT(mm)																																																																																																																																																																	
MAIN DOORS		ROUGH OPENING SIZE																																																																																																																																																																				
D1	METAL FRAMED METAL SHUTTER DOOR	900	2100	0	2100																																																																																																																																																																	
WINDOW																																																																																																																																																																						
GL7	ALUMINIUM FRAMED 6MM THK GLASS WINDOW	700	1200	900	2100																																																																																																																																																																	
GL8	ALUMINIUM FRAMED 6MM THK GLASS WINDOW	1200	1200	900	2100																																																																																																																																																																	
GL9	ALUMINIUM FRAMED 6MM THK GLASS WINDOW	1500	1200	900	2100																																																																																																																																																																	
GL10	ALUMINIUM FRAMED 6MM THK GLASS WINDOW	2400	1200	900	2100																																																																																																																																																																	
R0	ISSUED AS GOOD FOR CONSTRUCTION	23.06.20	NI	HV	AG	AG																																																																																																																																																																
REV	DESCRIPTION	DATE	DSGN	DRWN	CHKD	APPD																																																																																																																																																																
ARCHITECTURE			FPS																																																																																																																																																																			
STRUCTURAL			PIPING																																																																																																																																																																			
ELECTRICAL			PHE																																																																																																																																																																			
ELV SYSTEM			GIS																																																																																																																																																																			
HVAC			GEOTECH.																																																																																																																																																																			
CHECKED BY	SIGN	DATE	CHECKED BY	SIGN	DATE																																																																																																																																																																	
Certification <table><tr><td> EPC Contractor </td><td> Architectural Consultant </td><td> Proof Consultant </td><td> PEAC </td><td> Issued by: </td><td> Employer / Employer's Engineer </td></tr><tr><td> Design Consultant </td><td></td><td> Structural </td><td> MEP </td><td> ICT </td><td></td></tr></table>						EPC Contractor	Architectural Consultant	Proof Consultant	PEAC	Issued by:	Employer / Employer's Engineer	Design Consultant		Structural	MEP	ICT		2																																																																																																																																																				
EPC Contractor	Architectural Consultant	Proof Consultant	PEAC	Issued by:	Employer / Employer's Engineer																																																																																																																																																																	
Design Consultant		Structural	MEP	ICT																																																																																																																																																																		
8	7	6	5	4	3	2	1																																																																																																																																																															

F


E

D

C

B

A

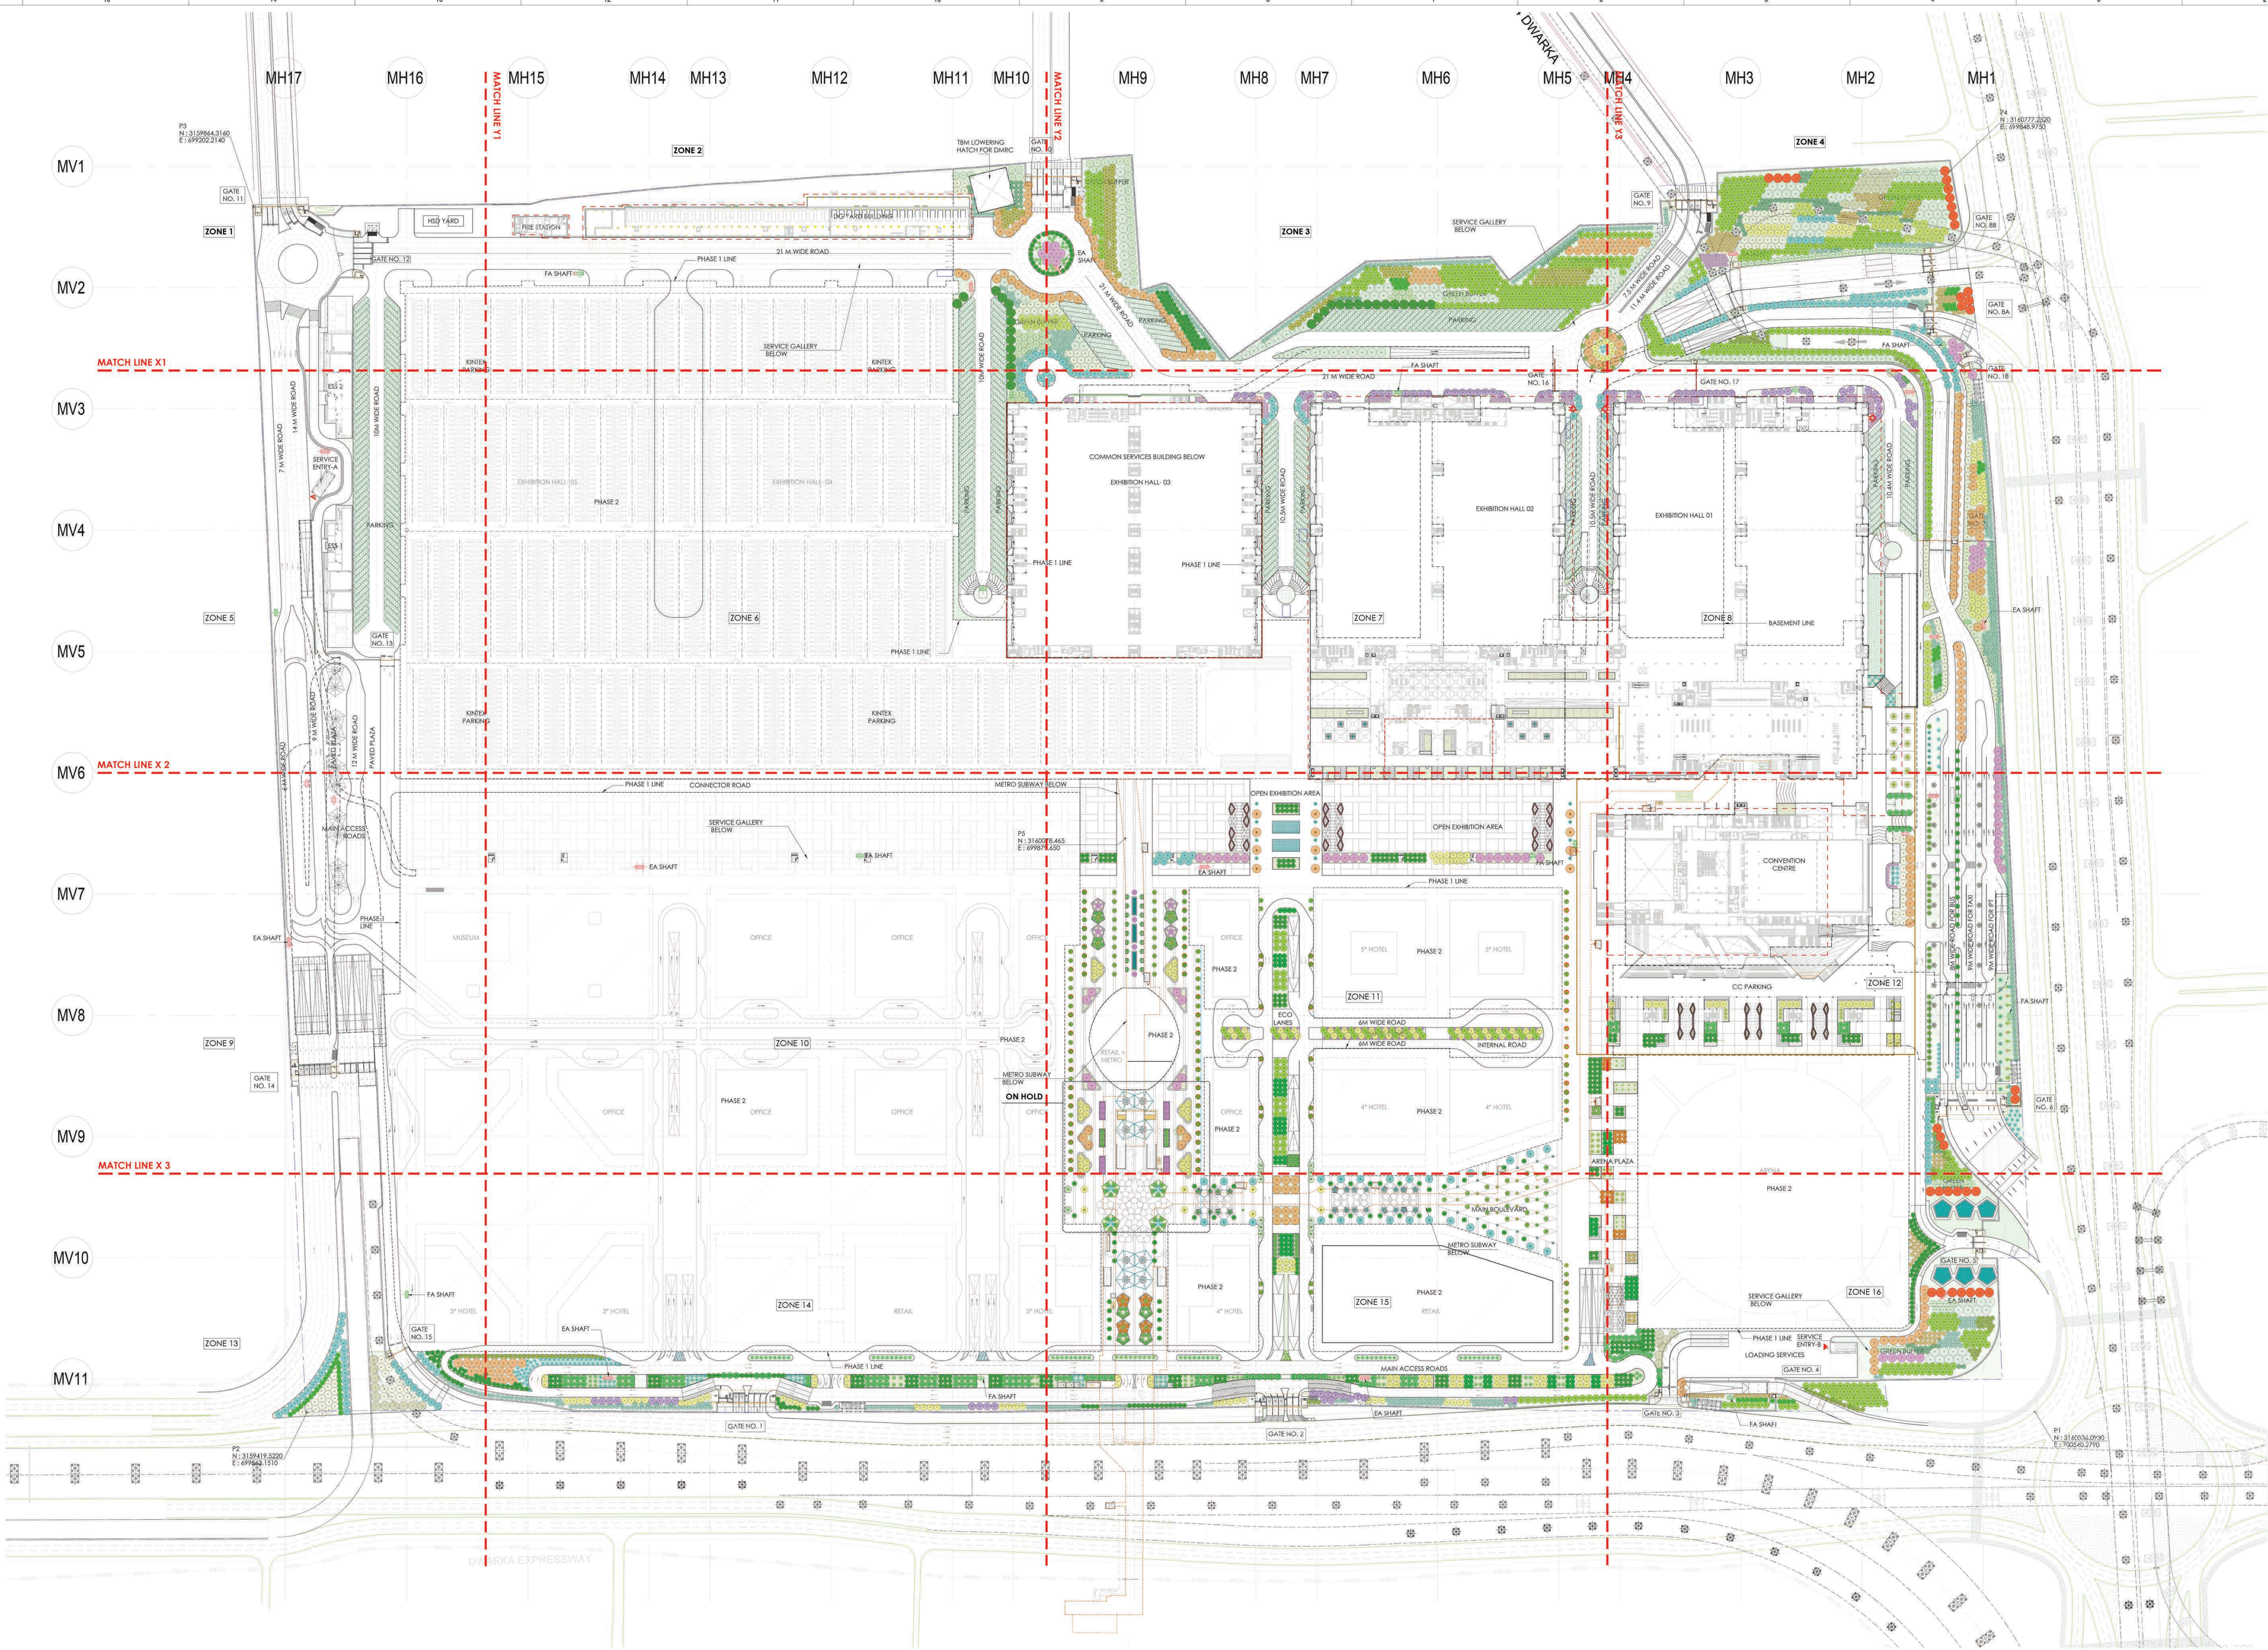

LEGEND FOR PLANTING PLAN - FOR COMPLETE PHASE 1			
SYMBOL	SPECIES NAME	COMMON NAME	C/C
	A in	Azadirachta indica	Neem tree 4.5
	A le	Albizia lebbek	Slk tree 6
	S va	Bauhinia variegata	Kachnar, Orchid Tree 4.15
	B ce	Bombax ceiba	Silk Cotton Tree 4
	C ti	Cassia fistula	Amaltas, Golden shower tree 4.5
	C sp	Celastrus speciosa	Silk floss tree 3.5
	C se	Cordia sebestena	Orange Geiger Tree 3
	C ci	Calotropis chinensis	Lemon bottlebrush 3

LEGEND FOR PLANTING PLAN - FOR COMPLETE PHASE 1			
SYMBOL	SPECIES NAME	COMMON NAME	C/C
	D re	Delonix regia	Flame Tree, Gulmohar 4
	D si	Dalbergia sissoo	Shisham 3
	E va	Erythrina variegata	Indian Coral Tree 3
	F el	Ficus elastica	Rubber fig 4.5
	F ly	Ficus lyrata	Fiddle Leaf fig 3
	F vi	Ficus virens	White fig 4
	J mi	Jacaranda mimosoides	Neel guldahur 5



LEGEND FOR PLANTING PLAN - FOR COMPLETE PHASE 1			
SYMBOL	SPECIES NAME	COMMON NAME	C/C
	L in	Lagerstroemia indica	Chapel myrtle 2
	L sp	Lagerstroemia speciosa	Pride of India 6
	M az	Melia azadirach	Neem tree 3
	M el	Mimosa elengi	Moukai, Spanish cherry 5
	M fe	Mesua ferrea	Nag Kesari, Cobra jaffan 3
	M ch	Michelia champaca	Champaka, Golden Champaka 3
	M al	Morus alba	White Mulberry 5

LEGEND FOR PLANTING PLAN - FOR COMPLETE PHASE 1			
SYMBOL	SPECIES NAME	COMMON NAME	C/C
	M pl	Mitella pinnatifida	Pongamia tree, Indian Beech tree 4.5
	P ab	Platanus obtusifolia	White frangipani 3
	P lo	Polyalthia longifolia	Ashok tree 3
	S cu	Syzgium cumini (JAM C/C)	Jamun tree, Jamun 6
	T in	Terminalia indica (SMC/C)	Tamarind 6
	T or	Terminalia ajuna (SMC/C)	Ajuna tree 4.5
	T be	Terminalia bellica (SMC/C)	Baheda 5

LEGEND FOR PLANTING PLAN - FOR COMPLETE PHASE 1			
SYMBOL	SPECIES NAME	COMMON NAME	C/C
	A ai	Archontophoenix alexandrina	King Palm, Majestic Palm 4
	C hu	Chamaecyparis humilis	Mediterranean fan palm 3
	H la	Hyophorba lagenicaulis	Bottle palm 3
	P ro	Phoenix roebelenii	Miniature date palm 3
	R re	Ravensara regia	Royal palm 3
	W si	Washingtonia filifera	Desert fan palm 3
	W bl	Wodyetia bulbocaulis	Fox tail palm 3

- 017203-N-SP-00-WD-0500 SERIES - PLANTING SET, TO BE REFERRED FOR FOLLOWING POINTS:
- All dimensions are in Meters. Dimensions to be read and shall not be measured from the drawing.
 - Total Quantity shown in legend for the tree plantation is for the complete site of phase 1.
 - For specifications of the proposed trees refer separate document.
 - Green areas and planting of upper canopy are shown in colored hatches. To get clear understanding print should be taken in colour.
 - Meta corridor line depiction in orange colour.
 - No building details shall be referred from planting plan drawing sets.
 - Service gallery and tunnel coming in green areas and landscape plazas to be designed for the tree loading.

- ABBREVIATIONS:
- FRL - FINISHED ROAD LEVEL
 - FPL - FINISHED PAVED LEVEL
 - FGL - FINISHED GROUND LEVEL
 - BPL - BUILDING PAVED LEVEL
 - TOF - TOP OF FILL

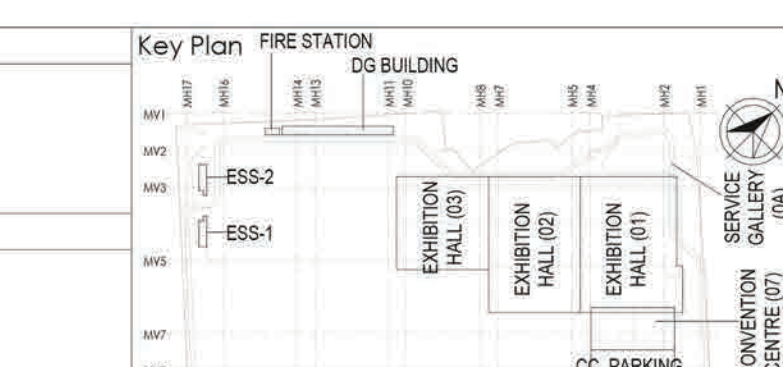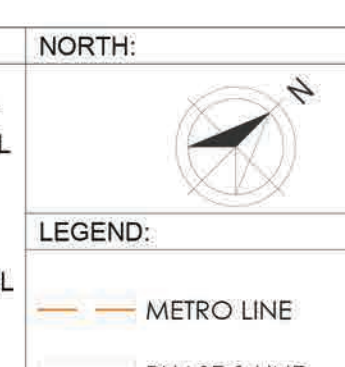

Owner / Employer

Indo International Convention & Exhibition Centre Limited
Room No. 450, Ministry of Commerce & Industry,
CPH, 15000, New Delhi - 110011, India

Department of Industrial Policy and Promotion
Ministry of Commerce & Industry
Government of India

Knowledge Partner

Delhi Mumbai Industrial Corridor
Development Corporation
Room No. 301 & 302, 3rd Floor, Green Park,
Sector 18, New Delhi - 110016, India

Employer's Representative

Programme Management Consultant (PMC)

AECOM

Preliminary Engineering Architecture Consultants (PEAC)

idom **CPKURUJA**

Av. Del Marquês de E. 400, 4.º, 28014 Madrid, Spain
No. 1, Ashwini Building, Green Park,
New Delhi - 110016, India

EPC Contractor

L&T Construction
Buildings & Factories
Mount Road, Madurai, Tamil Nadu - 625 005

EPC Contractor's Representatives

Design Consultant

Engineering Design and Research Center (EDRC)
L&T Construction - Buildings & Factories

Architectural Consultant

ARCOP
Arcop Associates Pvt. Ltd.,
A-15, Parkside Enclave, G-1,
New Delhi - 110016, India

Structural Proof Consultant

Indian Institute of Technology (IIT) Madras
Sardar Patel Rd, Opposite to C. L. R. Adyar, Chennai,
Tamil Nadu - 600035

MEP Proof Consultant

Egis India Consulting Engineers Pvt. Ltd.
Plot No. 46, Sector 32, Indira Nagar,
Gurgaon, Haryana - 122001

ICT Proof Consultant

CKR Consulting Engineers Pvt. Ltd.
40/11, 3rd Floor, Haridwar Road,
Subramanyam Road, Hyderabad Circle,
Bachchanpally, Bangalore - 560004

Certification

EPC Contractor

Design Consultant

Architectural Consultant

Proof Consultant

Structural **MEP** **ICT**

PEAC

Issued by:
Employer / Employer's Engineer

RE: GOOD FOR CONSTRUCTION

REV: 1

DESCRIPTION: DATE: DESIGNED: DRAWN: CHECKED: APPROVED:

Revisions:

NO.	DESCRIPTION	DATE	DESIGNED	DRAWN	CHECKED	APPROVED
1	ISSUED FOR CONSTRUCTION					

Checked by: SIGN DATE

Checked by: SIGN DATE

Checked by: SIGN DATE

EPC Contractor

L&T Construction
Buildings & Factories

JOB NO: 017203

Project Name:
DESIGN AND CONSTRUCTION OF INDIA
INTERNATIONAL CONVENTION & EXPO CENTRE
SECTOR 25, DWARKA, NEW DELHI, INDIA

Drawing Status:
GOOD FOR CONSTRUCTION (GFC)

Drawing No: N 00 0500 R0


Rev. No: R0

Title:
LANDSCAPE PLANTING PLAN -
UPPER CANOPY: OVERALL SITE

EDRC DWG No: 017203-N-SP-00-WD-0500

Scale: 1:1500

Sheet Size: A0

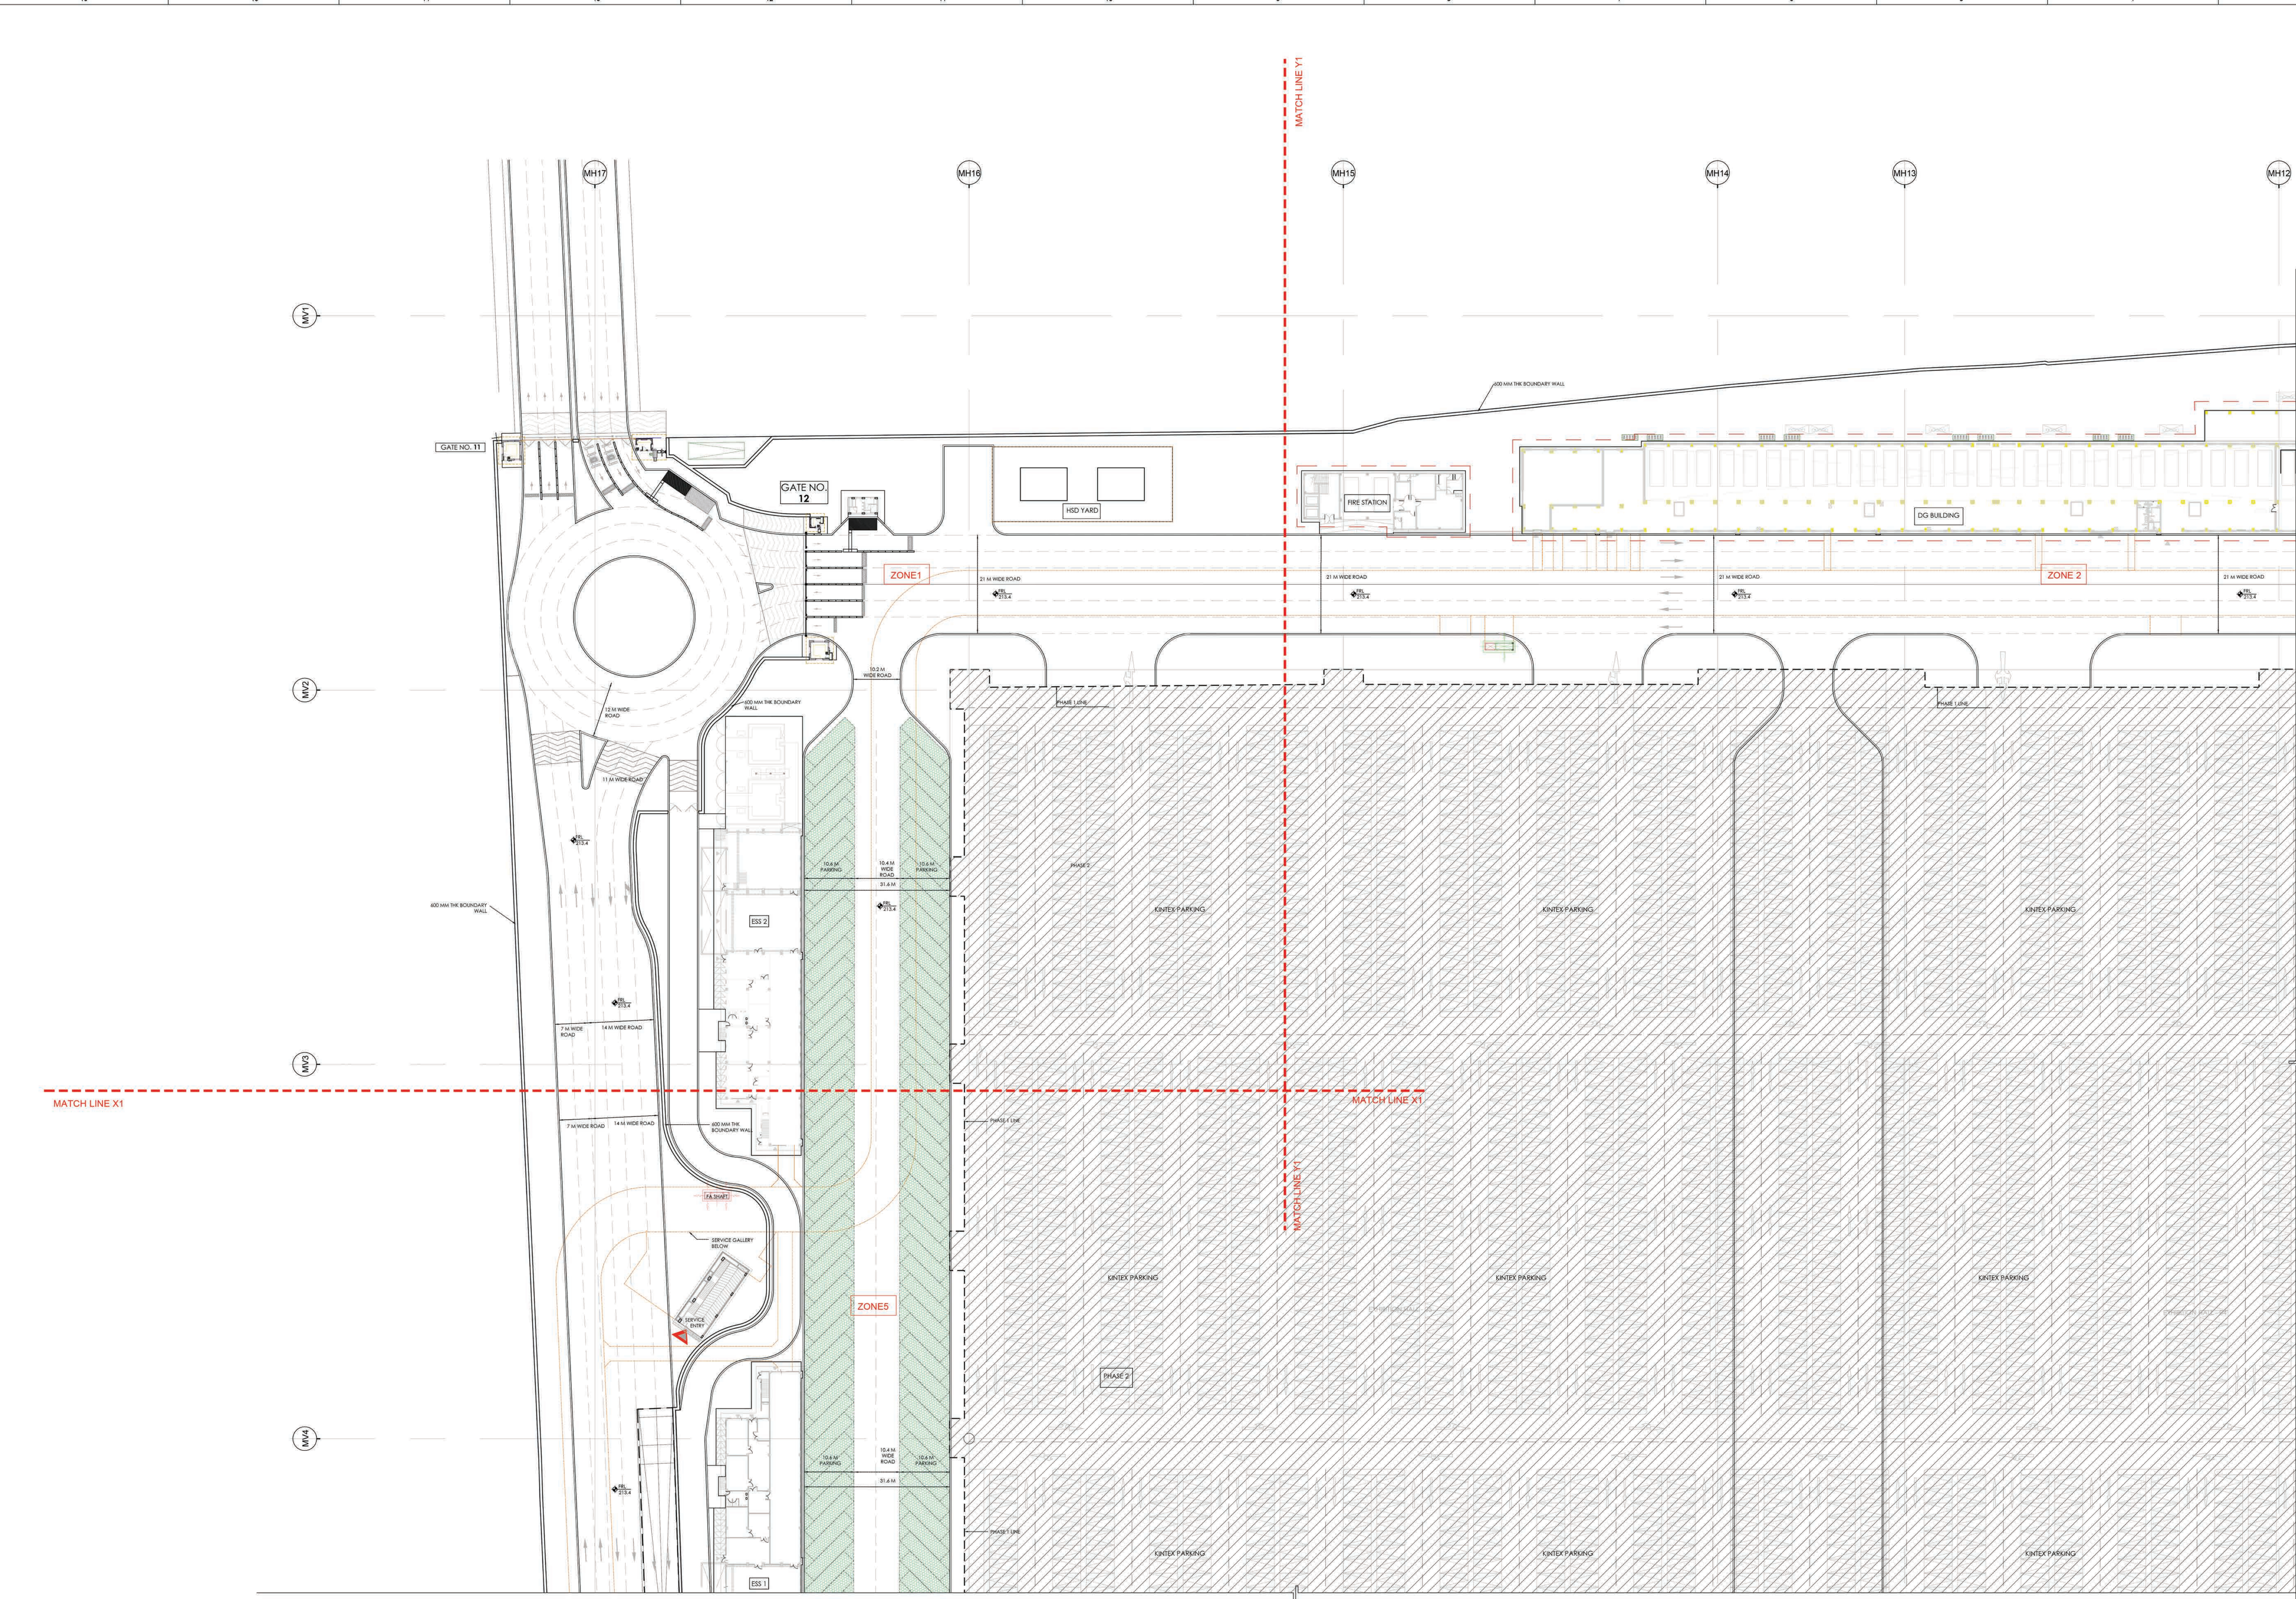

LEGEND FOR PLANTING PLAN - FOR COMPLETE PHASE I			
SYMBOL	SPECIES NAME	COMMON NAME	c/c
	A in	Azadirachta indica	Neem tree 4.5
	A le	Albizia lebbekii	Sils tree 6
	B va	Bauhinia variegata	Kochmar, Orchid Tree 4.15
	B ce	Bombax ceiba	Silk Cotton tree 4
	C fi	Cassia fistula	Amaltas, Golden shower tree 4.5
	C sp	Ceiba speciosa	Silk floss tree 3.5
	C se	Cordia sebestena	Orange Geliger tree 3
	C al	Cordia allamora	Lemon bottlebrush 3

LEGEND FOR PLANTING PLAN - FOR COMPLETE PHASE I			
SYMBOL	SPECIES NAME	COMMON NAME	c/c
	D re	Dalbergia regina	Flame Tree, Gulmohar 4
	D si	Dalbergia sissoo	Shisham 3
	E va	Erythrina variegata	Indian Coral Tree 3
	F re	Ficus religiosa	Rubber fig 4.5
	F ly	Ficus lyrata	Fig tree 3
	F vi	Ficus virens	White fig 4
	J mi	Jacaranda mimosoides	Neel gulmohar 5



LEGEND FOR PLANTING PLAN - FOR COMPLETE PHASE I			
SYMBOL	SPECIES NAME	COMMON NAME	c/c
	L in	Lagerstroemia indica	Grape myrtle 2
	L sp	Lagerstroemia speciosa	Pride of India 4
	M az	Melia azadirachta	Neem tree 3
	M pu	Mimosa pudica	Moukoti, Spanish cherry 5
	M fe	Mesua ferrea	Nag Kesari, Cobra lollipop 3
	M ch	Michelia champaca	Champaka, Golden Champaka 3
	M al	Morus alba	White Mulberry 5

LEGEND FOR PLANTING PLAN - FOR COMPLETE PHASE I			
SYMBOL	SPECIES NAME	COMMON NAME	c/c
	M pi	Mistletoe pinnata	Pongam tree, Indian Beech tree 4.5
	P al	Plumeria alba	White Frangipani 3
	P lo	Polyalthia longifolia	Ashok tree 3
	S cu	Syzygium cumini	Jawa plum, Jamun 6
	T in	Tamarindus indica	Tamarind 6
	T al	Terminalia alata	Adju tree 4.5
	T bi	Terminalia bitorata	Baheda 5

LEGEND FOR PLANTING PLAN - FOR COMPLETE PHASE I			
SYMBOL	SPECIES NAME	COMMON NAME	c/c
	A al	Archontophoenix alexandrinae	King Palm, Majestic Palm 4
	C hu	Chamaecyparis humilis	Mediterranean fan palm 4
	H la	Hyophorba lagenicaulis	Bottle palm 4
	P ro	Phoenix roebelenii	Miniature date palm 4
	R re	Roystonea regia	Royal palm 4
	W fi	Washingtonia filifera	Desert fan palm 4
	W bi	Wodyetia bifurcata	Fox tail palm 4

- 017203-N-SP-00-WD-0500 SERIES-PLANTING SET, TO BE REFERRED FOR FOLLOWING POINTS:
- All dimensions are in Meters. Dimensions to be read and shall not be measured from the drawing.
 - Total Quantity shown in legend for the tree plantation is for the complete site of phase 1.
 - For specifications of the proposed trees refer separate document.
 - Green areas and planting of upper canopy are shown in colored hatches. To get clear understanding print should be taken in colour.
 - Metra corridor line depiction in orange colour.
 - No building details shall be referred from planning plan drawing sets.
 - Service gallery and tunnel coming in green areas and landscape plazas to be designed for the tree loading.

- ABBREVIATIONS:
- FRL - FINISHED ROAD LEVEL
 - FPL - FINISHED PAVED LEVEL
 - FGL - FINISHED GROUND LEVEL
 - BPL - BUILDING PAVED LEVEL
 - TOF - TOP OF FILL

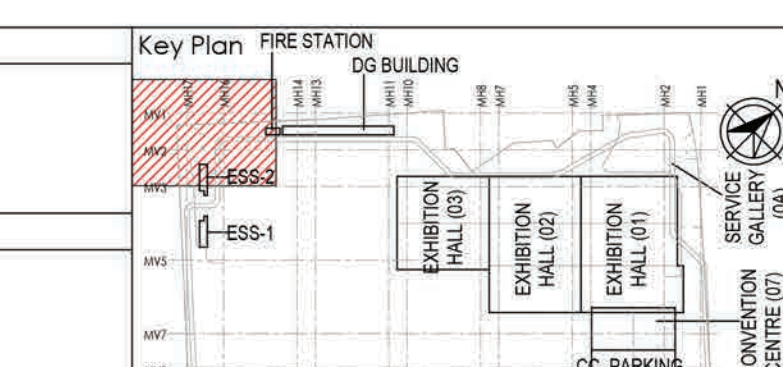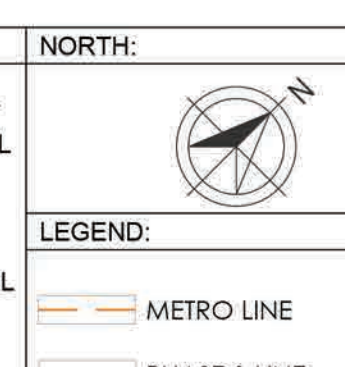

Owner / Employer

India International Convention & Exhibition Centre Limited
C-101, 10th Floor, New Delhi - 110011, India

Department of Industrial Policy and Promotion Ministry of Commerce & Industry Government of India

Knowledge Partner

Delhi Mumbai Industrial Corridor Development Corporation
Room No. 341 & 3rd floor Hotel Ashok, Connaught Place, New Delhi - 110011, India

Employer's Representative

Employer Engineer
Programme Management Consultant (PMC)

AECOM

Preliminary Engineering Architecture Consultants (PEAC)

idom

Av. Del Marquês de E. B. 4, 28041 Madrid, Spain

CPKUREJA

No. D-1, Ashwaz Building, Green Park, New Delhi, Delhi 110016, India

EPC Contractor

L&T Construction
Buildings & Factories
Mount Postgraduate Road, Mangalagiri, P. 83, 500 079, Chennai - 600 079

EPC Contractor's Representatives

Design Consultant
Engineering Design and Research Center (EDRC)
L&T Construction - Buildings & Factories

Architectural Consultant

ARCOP
Arcop Associates Pvt. Ltd., A-15, Parkside Enclave, G.D-1, New Delhi, Delhi 110016, India

Structural Proof Consultant

Indian Institute of Technology (IIT) Madras
Sardar Patel Rd, Opposite to C. L. R. A. Chavara, Chennai, Tamil Nadu - 600 004

MEP Proof Consultant

Egis India Consulting Engineers Pvt. Ltd.
Plot No. 46, Sector 35, Institutional Area, Gurgaon, Haryana 122001

ICT Proof Consultant

CCR
CCR Consulting Engineers Pvt. Ltd.
#401, 3rd floor, Naraina Arcade, Subramaniam Road, Naraina Circle, New Delhi - 110028

Certification

EPC Contractor

Design Consultant

Architectural Consultant

Proof Consultant

Structural **MEP** **ICT**

PEAC

Issued by:
Employer / Employer's Engineer

Revisions

REV	DESCRIPTION	DATE	SIGN	DRWN	CHKD	APPD
1	ARCHITECTURE					
2	STRUCTURAL					
3	ELECTRICAL					
4	MEP SYSTEM					
5	HWAC					

CHECKED BY: SIGN DATE CHECKED BY: SIGN DATE

EPC Contractor

L&T Construction
Buildings & Factories

JOB No: 017203

Project Name
DESIGN AND CONSTRUCTION OF INDIA INTERNATIONAL CONVENTION & EXPO CENTRE SECTOR 25, DWARKA, NEW DELHI, INDIA

Drawing Status
GOOD FOR CONSTRUCTION (GFC)

Drawing No
N 00 0501


Rev. No
R0

Title:
LANDSCAPE PLANTING PLAN - UPPER CANOPY: ZONE 1

EDRC DWG No: 017203-N-SP-00-WD-0501

Scale
1:500

Sheet Size
A0

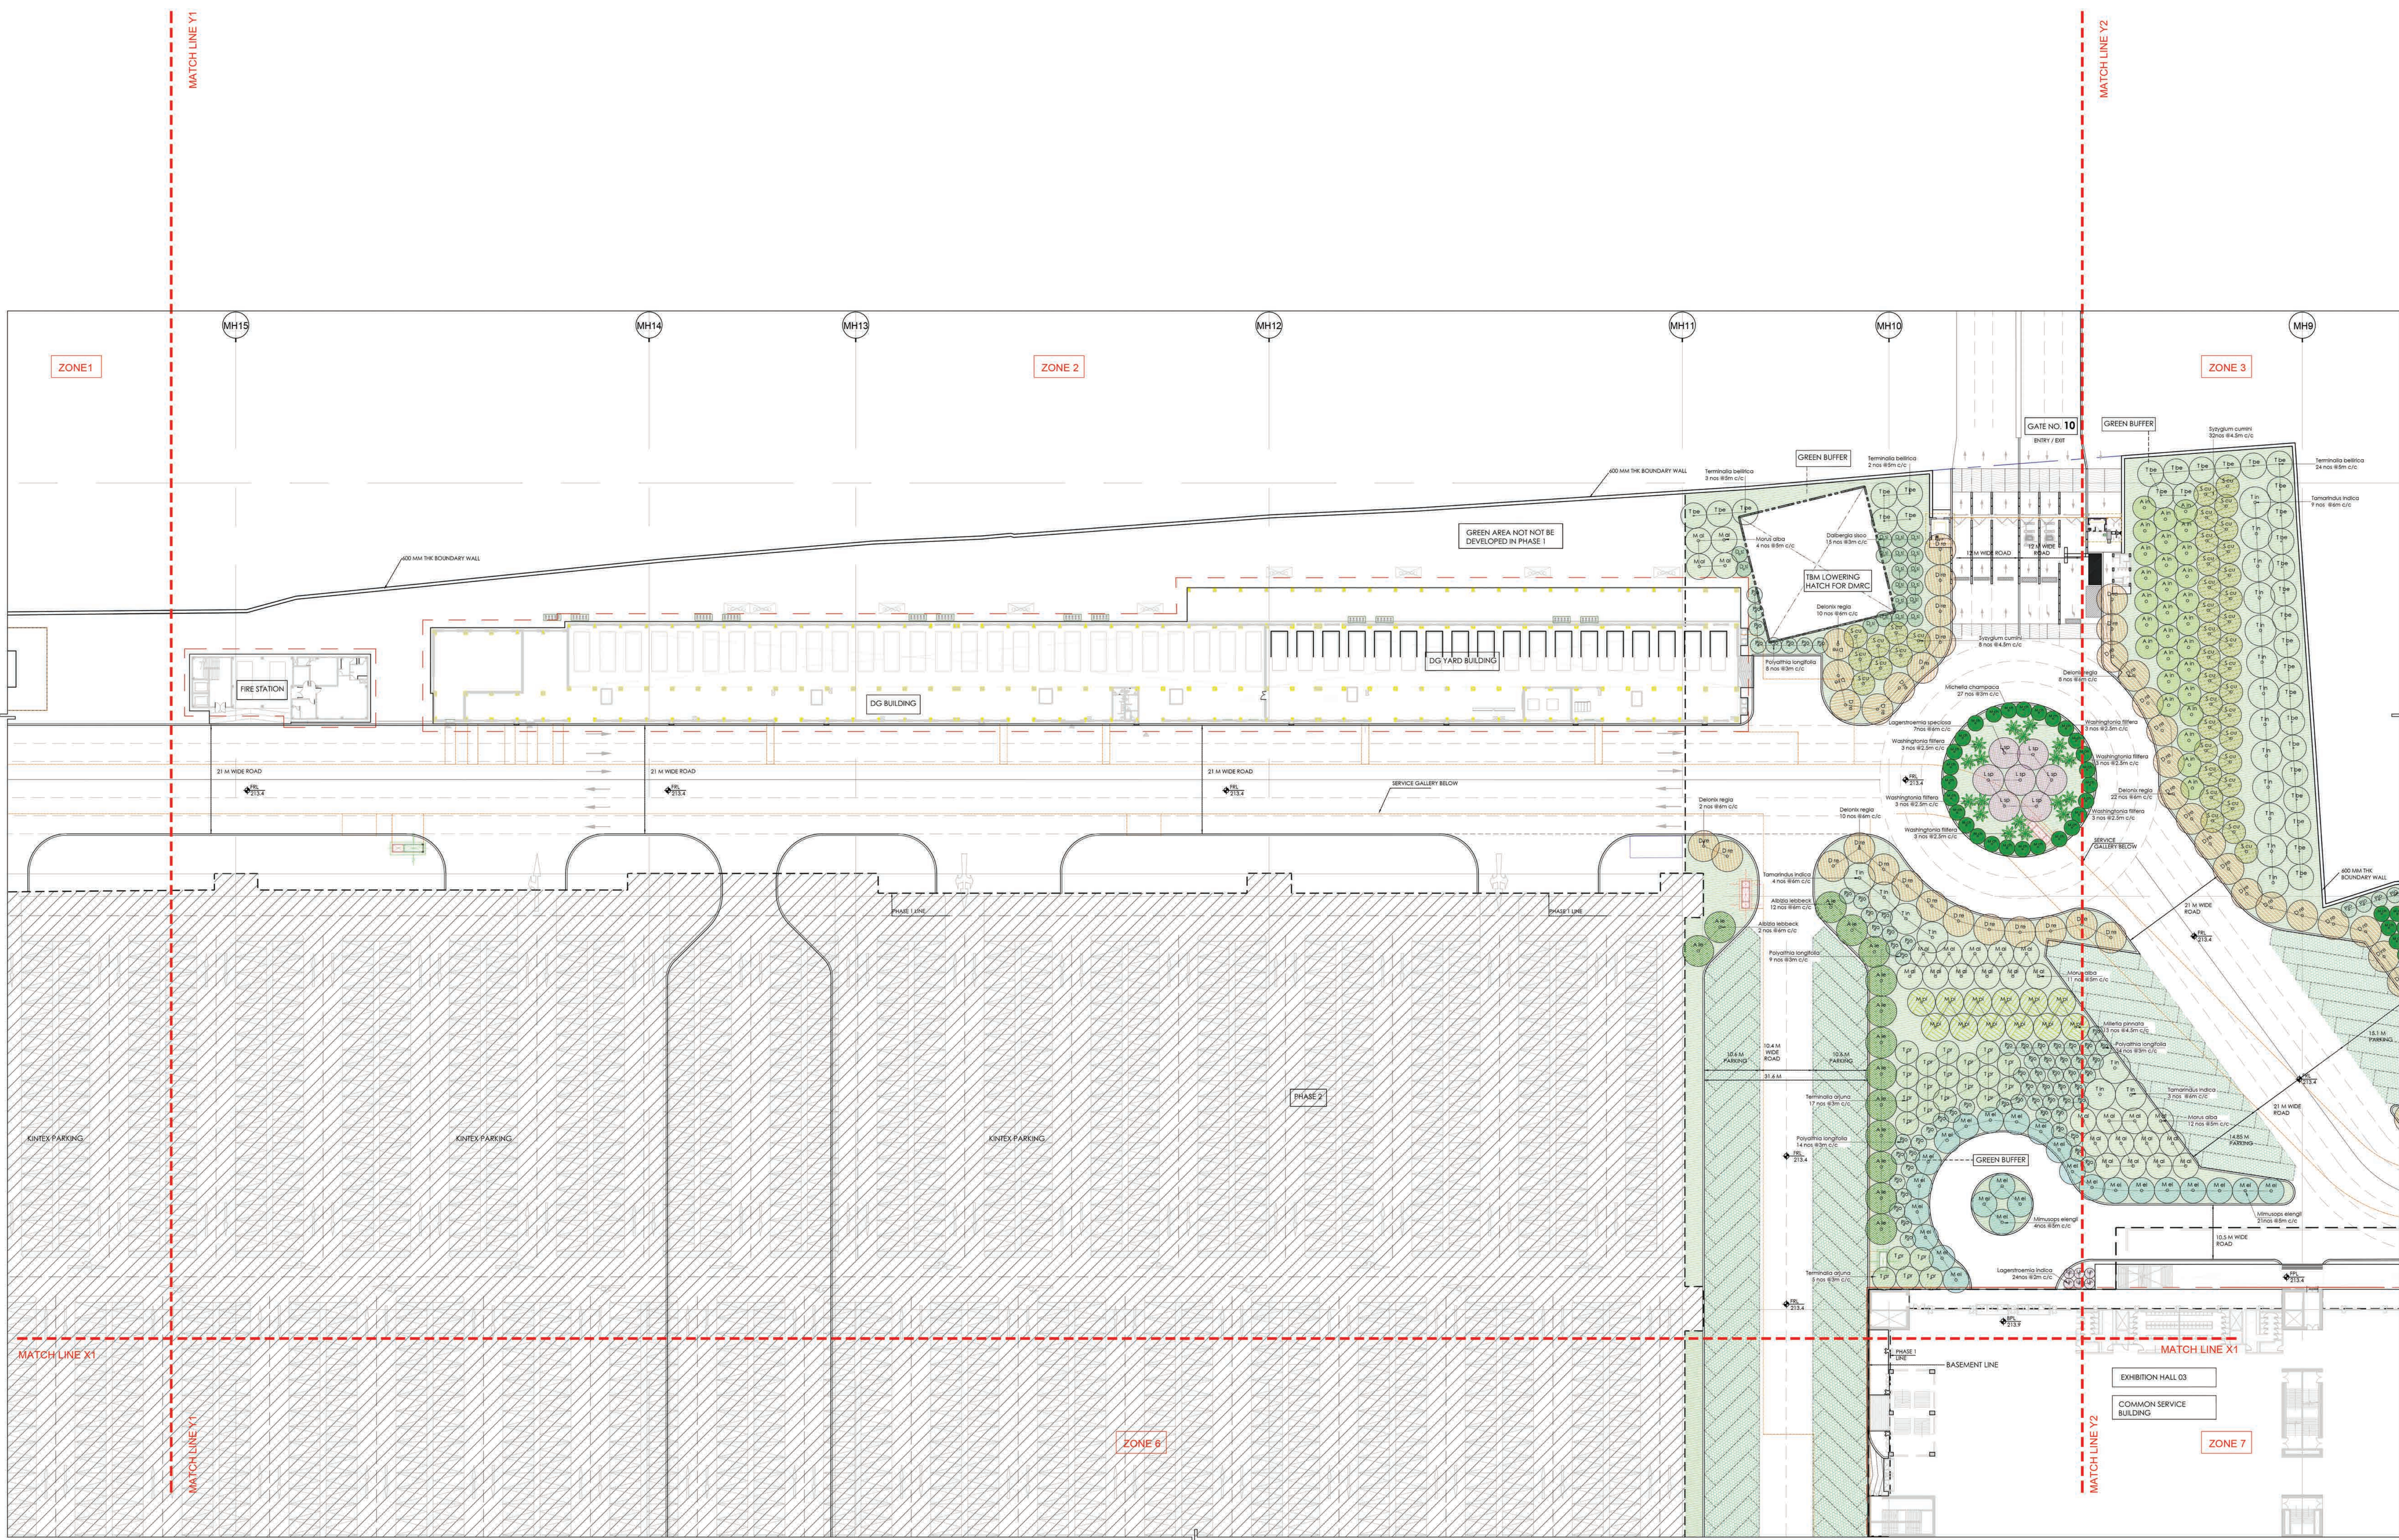

LEGEND FOR PLANTING PLAN - FOR COMPLETE PHASE I			
SYMBOL	SPECIES NAME	COMMON NAME	c/c
A in	Azadirachta indica	Neem tree	4.5
A le	Aibaya latbecki	Sit tree	6
S va	Saurhina variegata	Kashmir, Orchid Tree	4.15
B ce	Bombax ceiba	Silk Cotton Tree	6
C ti	Cassia fistula	Amaltas, Golden Shower tree	4.5
C sp	Celastrus speciosa	Silk floss tree	3.5
C re	Cordia sebestena	Orange Gager Tree	3
C ci	Cassia chinensis	Lemon bottlebrush	3

LEGEND FOR PLANTING PLAN - FOR COMPLETE PHASE I			
SYMBOL	SPECIES NAME	COMMON NAME	c/c
D re	Desmodium regia	Flame Tree, Gulmohar	4
D si	Dalbergia sissoo	Shisham	3
E va	Erythrina variegata	Indian Coral Tree	3
F el	Ficus elastica	Rubber fig	4.5
F ly	Ficus lyrata	iddle Leaf fig	3
F vi	Ficus virens	White fig	4
J ml	Jacaranda mimosaefolia	Neel gulmohar	5



LEGEND FOR PLANTING PLAN - FOR COMPLETE PHASE I			
SYMBOL	SPECIES NAME	COMMON NAME	c/c
L in	Lagerstroemia indica	Chaste myrtle	2
L sp	Lagerstroemia speciosa	Pride of India	6
M az	Melia azadirach	Pavani Ulat	3
M el	Mimusops elengi	Moulali, Spanish cherry	5
M fe	Mesua ferrea	Nag Kesor, Cobra jaffan	3
M ch	Michelia champaca	Champa, Golden Champa	3
M al	Morus alba	White Mulberry	5

LEGEND FOR PLANTING PLAN - FOR COMPLETE PHASE I			
SYMBOL	SPECIES NAME	COMMON NAME	c/c
M pl	Mitella pinnata	Pongam tree, Indian Beech tree	4.5
P ab	Platanus alba	White Frangipani	3
P lo	Polyalthia longifolia	Ashok tree	3
S cu	Syzygium cumini (4.5M C/C)	Jamun palm, Jamun	6
T in	Tamarindus indica (4M C/C)	Tamarind	6
T or	Terminalia ajuna (3M C/C)	Ajuna tree	4.5
T be	Terminalia bellirica (5M C/C)	Baheda	5

LEGEND FOR PLANTING PLAN - FOR COMPLETE PHASE I			
SYMBOL	SPECIES NAME	COMMON NAME	
A al	Anacardium occidentale	King Palm, Majestic Palm	
C hu	Chamaecyparis humilis	Mediterranean fan palm	
H la	Hyophorba lagenicaulis	Bottle palm	
P ro	Phoenix roebelenii	Miniature date palm	
R re	Ravenea regia	Royal palm	
W li	Washingtonia filifera	Desert fan palm	
W bl	Wodyetia bilucata	Fox tail palm	

- O17203-N-SP-00-WD-0502 SERIES - PLANTING SET, TO BE REFERRED FOR FOLLOWING POINTS:
1. All dimensions are in Meters. Dimensions to be read and shall not be measured from the drawing.
 2. Total Quantity shown in legends for the tree plantation is for the complete site of phase I.
 3. For specifications of the proposed trees refer separate documents.
 4. Green areas and planting of upper canopy are shown in colored hatches. To get clear understanding print should be taken in colour.
 5. Metro corridor line depiction in orange colour.
 6. No building details shall be referred from planning plan drawing sets.
 7. Service gallery and tunnel coming in green areas and landscape plazas to be designed for the tree loading.

- ABBREVIATIONS:
1. FRL - FINISHED ROAD LEVEL
 2. FPL - FINISHED PAVED LEVEL
 3. FGL - FINISHED GROUND LEVEL
 4. BPL - BUILDING PAVED LEVEL
 5. TOP - TOP OF FILL

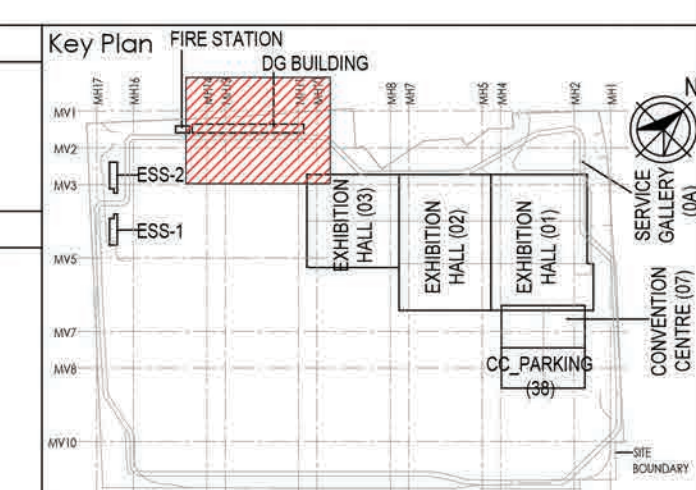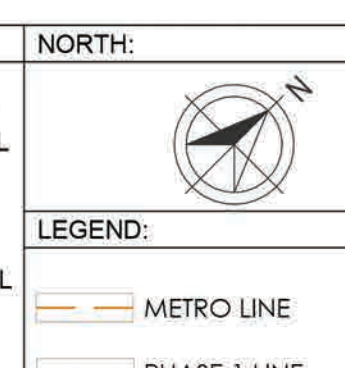

Owner / Employer

India International Convention & Exhibition Centre Limited
Room No. 402A, Ministry of Commerce & Industry,
CPRI, Lodhi Road, New Delhi - 110011, India

Department of Industrial Policy and Promotion Ministry of Commerce & Industry Government of India

Knowledge Partner

Delhi Mumbai Industrial Corridor Development Corporation
Room No. 301 & 302, 3rd Floor Hotel Ashok,
Rajendra Estate, JCB Chowk, New Delhi - 110021

Employer's Representative

Employer Engineer
Programme Management Consultant (PMC)

AECOM

Preliminary Engineering Architecture Consultants (PEAC)

idom **CPKUREJA**

Av. Del Marquês de E. Escorial, 4. No. 1, Ashok Building, Green Park,
28049 Madrid, Spain. New Delhi, Delhi 110016, India

EPC Contractor

L&T Construction
Buildings & Factories
Mount Road, Bangalore, Karnataka,
P. O. Box 17, Chennai - 600 008

EPC Contractor's Representatives

Design Consultant
Engineering Design and Research Center (EDRC)
L&T Construction - Buildings & Factories

Architectural Consultant
ARCOP
Arcop Associates Pvt. Ltd.,
A-15, Parkside Enclave, G.K. 1,
New Delhi, Delhi 110016, India

Structural Proof Consultant
Indian Institute of Technology (IT) Madras
Sardar Patel Rd, Opposite to C. L. K. Adyar, Chennai,
Tamil Nadu 600 006

MEP Proof Consultant
Egis India Consulting Engineers Pvt. Ltd.
Plot No. 46, Sector 32, Institutional Area,
Gurgaon, Haryana 122001

ICT Proof Consultant
CKR Consulting Engineers Pvt. Ltd.
#401, 3rd Floor, Narayana Arcade,
Subramaniam Road, Velupillai Circle,
Basavanagudi, Bengaluru - 560004

Certification

Design Consultant

Architectural Consultant

Proof Consultant

Structural **MEP** **ICT**

PEAC

Issued By:
Employer / Employer's Engineer

REVISIONS

NO	DESCRIPTION	DATE	DESIGN	DRWN	CHKD	APPD
01	GOOD FOR CONSTRUCTION	20/08	N/A	18	N/A	POA

Revisions

ARCHITECTURE	DESIGN	MEP	STRUCTURAL	GEOTECH	ENVIRONMENT	WATER

Checked By: SIGN DATE CHECKED BY: SIGN DATE

EPC Contractor

L&T Construction
Buildings & Factories

Job No: O17203

Project Name
DESIGN AND CONSTRUCTION OF INDIA
INTERNATIONAL CONVENTION & EXPO CENTRE
SECTOR 25, DWARKA, NEW DELHI, INDIA

Drawing Status
GOOD FOR CONSTRUCTION (GFC)

Drawing No **Rev. No**


N **00** **0502** **R0**

Title:
LANDSCAPE PLANTING PLAN - UPPER CANOPY: ZONE 2

EDRC DWG No: O17203-N-SP-00-WD-0502

Scale **Sheet Size**

1:500 **A0**

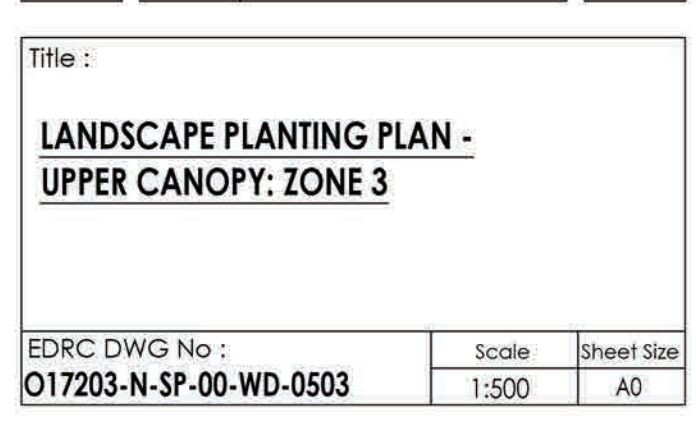

EPIC Contractor

L&T Construction

Buildings & Factories

JOR No : 017203



Project Name

Rev. No

**DESIGN AND CONSTRUCTION OF INDIA
INTERNATIONAL CONVENTION & EXPO CENTRE
SECTOR 25, DWARKA, NEW DELHI, INDIA**

Drawing Status

Rev. No

GOOD FOR CONSTRUCTION (GFC)

Drawing No

Rev. No

N

00

0503

R0

Title :

Rev. No

**LANDSCAPE PLANTING PLAN -
UPPER CANOPY: ZONE 3**

EDRC DWG No :


Scale

Sheet Size

O17203-N-SF-00-WD-0503

1:500

A0

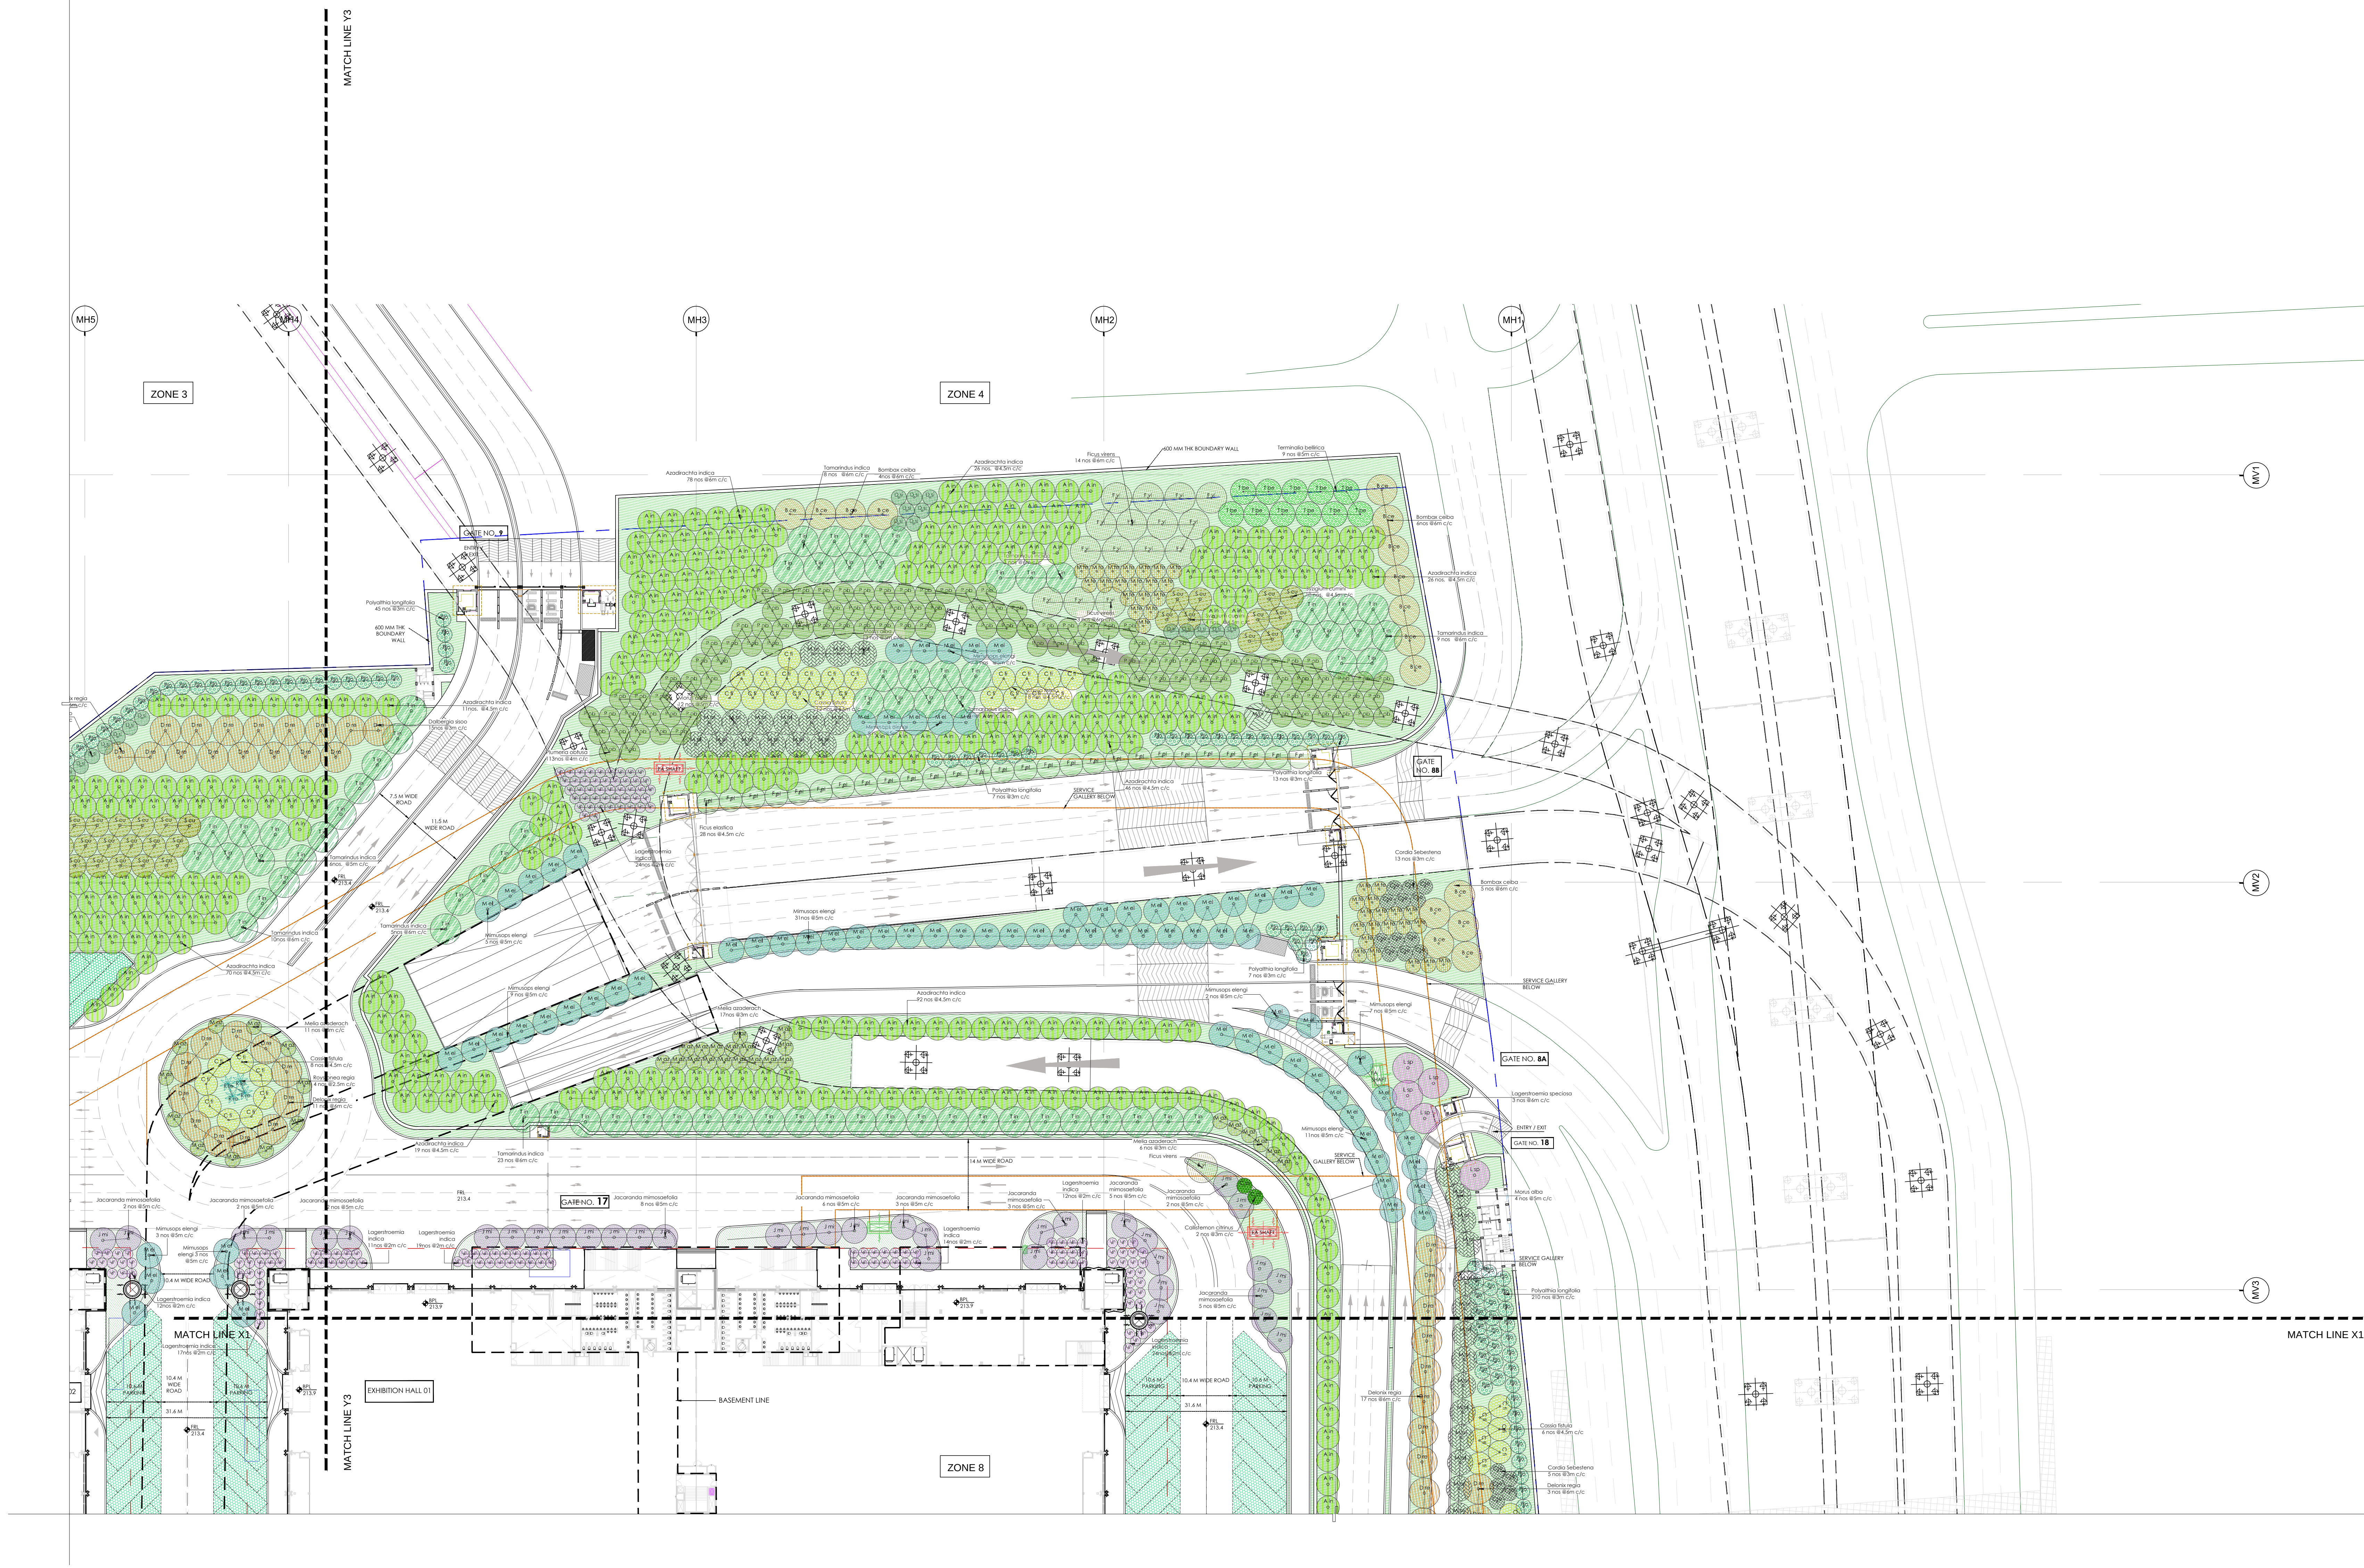

LEGEND FOR PLANTING PLAN - FOR COMPLETE PHASE 1			
SYMBOL	SPECIES NAME	COMMON NAME	C/C
	A in	Azadirachta indica	Neem tree 4.5
	A le	Albizia lebbek	Silk Tree 6
	B va	Bauhinia variegata	Kachnar, Orchid Tree 4.5
	B ce	Bombax ceiba	Silk Cotton tree 6
	C fi	Cassia fistula	Amaltas, Golden shower tree 4.5
	C sp	Cestrum speciosum	Silk Rose tree 3.5
	C al	Cordia alliodora	Orange Cascar tree 3
	C ci	Callistemon citrinus	Lemon bottlebrush 3

LEGEND FOR PLANTING PLAN - FOR COMPLETE PHASE 1			
SYMBOL	SPECIES NAME	COMMON NAME	C/C
	D re	Delonix regia	Flame tree, Gulmohar 6
	D si	Dalbergia sissoo	Shisham 3
	E va	Erythrina variegata	Indian Coral tree 3
	F el	Ficus elastica	Rubber tree 4.5
	F ly	Ficus lyrata	iddle Leaf fig 3
	F vi	Ficus virens	White fig 6
	J mi	Jacaranda mimosifolia	Neel gulmohar 5


LEGEND FOR PLANTING PLAN - FOR COMPLETE PHASE 1			
SYMBOL	SPECIES NAME	COMMON NAME	C/C
	L in	Lagerstroemia indica	Crape myrtle 2
	L sp	Lagerstroemia speciosa	Pride of India 6
	M az	Melia azadirachta	Parishad Uluc 3
	M el	Mimosa elengi	Moskato, Spanish cherry 5
	M fe	Mesua ferrea	Nag Kesari, Cobra luffa 3
	M ch	Michelia champaca	Champaka, Golden Champaka 3
	M al	Morus alba	White Mulberry 5

LEGEND FOR PLANTING PLAN - FOR COMPLETE PHASE 1			
SYMBOL	SPECIES NAME	COMMON NAME	C/C
	M pi	Miliaria pinnata	Pongamia tree, Indian Beech tree 4.5
	P ob	Plumeria obtusa	White frangipani 4
	P lo	Polyalthia longifolia	Ashok tree 3
	S cu	Syzygium cumini	Jamun plum, Jamun 6
	T in	Tamarindus indica	Tamarind 6
	T ar	Terminalia arjuna	Arjun tree 4.5
	T be	Terminalia bellica	Baheda 5

LEGEND FOR PLANTING PLAN - FOR COMPLETE PHASE 1			
SYMBOL	SPECIES NAME	COMMON NAME	C/C
	A al	Archontophoenix alexandrina	King Palm, Majestic Palm 6
	C hu	Chamaedorea humilis	Mediterranean fan palm 6
	H ha	Hypophyllum henricum	Butter palm 6
	P ro	Phoenix roebelenii	Miniature date palm 6
	R re	Roystonea regia	Royal palm 6
	W fi	Washingtonia filifera	Desert fan palm 6
	W bi	Wodyetia bilobata	Fox tail palm 6

- 017203-N-SP-00-WD-0500 SERIES-PLANTING SET, TO BE REFERRED FOR FOLLOWING POINTS:
1. FRL - FINISHED ROAD LEVEL
 2. FPL - FINISHED PAVED LEVEL
 3. FGL - FINISHED GRASS LEVEL
 4. BPL - BUILDING PAVED LEVEL
 5. TOF - TOP OF FILL

- ABBREVIATIONS:
1. FRL - FINISHED ROAD LEVEL
 2. FPL - FINISHED PAVED LEVEL
 3. FGL - FINISHED GRASS LEVEL
 4. BPL - BUILDING PAVED LEVEL
 5. TOF - TOP OF FILL

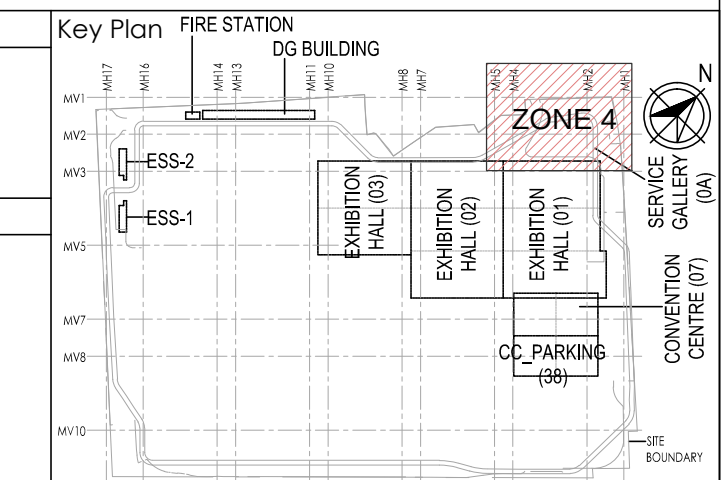

Owner / Employer
India International Convention & Exhibition Centre Limited
Department of Industrial Policy and Promotion Ministry of Commerce & Industry Government of India

Knowledge Partner
Delhi Mumbai Industrial Corridor Development Corporation
Room No. 341, E-3 Sector 29, Connaught Place, New Delhi - 110021

Employer's Representative
Employer Engineer
Programme Management Consultant (PMC)
AECOM

Preliminary Engineering Architecture Consultants (PEAC)
Av. Del Marquillo de B Escorial, 4, 28049 Madrid, Spain
No. D-1, Ashwini Building, Green Park, New Delhi, Delhi 110016, India

EPC Contractor
L&T Construction
Buildings & Factories
Mount Poonamallee Road, Poonamallee, Chennai - 600 089

EPC Contractor's Representatives
Design Consultant
Engineering Design and Research Center (EDRC)
L&T Construction - Buildings & Factories

Architectural Consultant
ARCO P
Atrop Associates Pvt. Ltd.
A-15 Pongose Endave, G-1-1 New Delhi, Delhi 110048, India

Structural Proof Consultant
Indian Institute of Technology (IIT) Madras
Sarda Patel Rd. Opposite to C.L.R.I. Achar, Chennai, Tamil Nadu 600036

MEP Proof Consultant
Egis India Consulting Engineers Pvt. Ltd.
A-101, 3rd Floor, Naraina Heights, Subramanyam Road, Naraina Heights Circle, New Delhi, Delhi 110028

ICT Proof Consultant
CKR Consulting Engineers Pvt. Ltd.
A-101, 3rd Floor, Naraina Heights, Subramanyam Road, Naraina Heights Circle, New Delhi, Delhi 110028

Certification
EPC Contractor
Design Consultant
Architectural Consultant
Proof Consultant
Structural **MEP** **ICT**

PEAC

Issued by:
Employer / Employer's Engineer

REV	DESCRIPTION	DATE	BY	CHKD	APPRO
01	GOOD FOR CONSTRUCTION	04/03/23	N.L.	N.L.	POK

Revisions

REV	DESCRIPTION	DATE	BY	CHKD	APPRO
01	GOOD FOR CONSTRUCTION	04/03/23	N.L.	N.L.	POK

EPC Contractor
L&T Construction
Buildings & Factories

Project Name
DESIGN AND CONSTRUCTION OF INDIA INTERNATIONAL CONVENTION & EXPO CENTRE
SECTOR 25, DWARKA, NEW DELHI, INDIA

Drawing Status
GOOD FOR CONSTRUCTION (GFC)

Drawing No
N 00 0504 R0

Title
LANDSCAPE PLANTING PLAN - UPPER CANOPY: ZONE 4

EDRC DWG No
017203-N-SP-00-WD-0504

Scale
1:500

Sheet Size
A0

LEGEND FOR PLANTING PLAN : FOR COMPLETE PHASE 1			
SYMBOL	SPECIES NAME	COMMON NAME	c/c
	A in	Azadirachta indica	Neem tree
	A le	Albizia lebbekii	Sils tree
	B va	Bauhinia variegata	Kachnar, Orchid Tree
	B ce	Bombax ceiba	Silk Cotton Tree
	C fi	Cassia fistula	Amaltas, Golden Shower tree
	C sp	Calceolaria speciosa	Silk Rose tree
	C se	Cordia sebestena	Orange Geiger Tree
	C al	Cordia allamanda	Lemon bottlebrush

LEGEND FOR PLANTING PLAN : FOR COMPLETE PHASE 1			
SYMBOL	SPECIES NAME	COMMON NAME	c/c
	D si	Dalbergia sissoo	Shisham
	E va	Erythrina variegata	Indian Coral Tree
	F el	Ficus elastica	Rubber fig
	F ly	Ficus lyrata	Hiddle Leaf fig
	F vi	Ficus virens	White fig
	J mi	Jacaranda mimosaeifolia	Neel gulmohar



LEGEND FOR PLANTING PLAN : FOR COMPLETE PHASE 1			
SYMBOL	SPECIES NAME	COMMON NAME	c/c
	L in	Lagerstroemia indica	Grape myrtle
	L sp	Lagerstroemia speciosa	Pride of India
	M az	Melia azadirachta	Neem tree
	M pu	Mimosa pudica	Shame flower
	N k	Nag Kesar	Cobra lily
	M ch	Michelia champaca	Champaka
	M di	Monarda didyma	White Mulberry

LEGEND FOR PLANTING PLAN : FOR COMPLETE PHASE 1			
SYMBOL	SPECIES NAME	COMMON NAME	c/c
	M pi	Mistletoe pinnata	King Palm, Majestic Palm
	P al	Plumeria alba	White Frangipani
	P lo	Polyalthia longifolia	Ashok tree
	S cu	Syzygium cumini	Jamun
	T in	Tamarindus indica	Tamarind
	T al	Terminalia alata	Adju tree
	T be	Terminalia bellicosa	Baheda

LEGEND FOR PLANTING PLAN : FOR COMPLETE PHASE 1			
SYMBOL	SPECIES NAME	COMMON NAME	c/c
	A sq	Annona squamosa	King Palm, Majestic Palm
	C hu	Chamaecyparis humilis	Mediterranean fan palm
	H gl	Hypochoeris glabra	Butter palm
	P ro	Phoenix roebelenii	Miniature date palm
	R re	Rostkia regia	Royal palm
	W fi	Washingtonia filifera	Desert fan palm
	W bi	Wodyetia bifurcata	Portulac palm

- 017203-N-SP-00-WD-0500 SERIES -PLANTING SET, TO BE REFERRED FOR FOLLOWING POINTS :
- All dimensions are in Metres. Dimensions to be read and shall not be measured from the drawing.
 - Total Quantity shown in legend for the tree plantation is for the complete site of phase 1.
 - For specifications of the proposed trees refer separate document.
 - Green areas and planting of upper canopy are shown in colored hatches. To get clear understanding print should be taken in colour.
 - Metro corridor line depiction in orange colour.
 - No building details shall be referred from planting plan drawing sets.
 - Service gallery and tunnel coming in green areas and landscape plazas to be designed for the tree loading.

- ABBREVIATIONS :
- FRL - FINISHED ROAD LEVEL
 - FPL - FINISHED PAVED LEVEL
 - FGL - FINISHED GROUND LEVEL
 - BPL - BUILDING PAVED LEVEL
 - TOP - TOP OF FILL

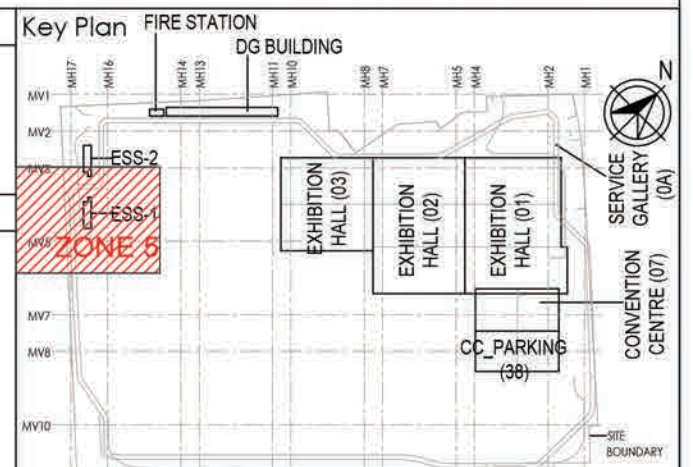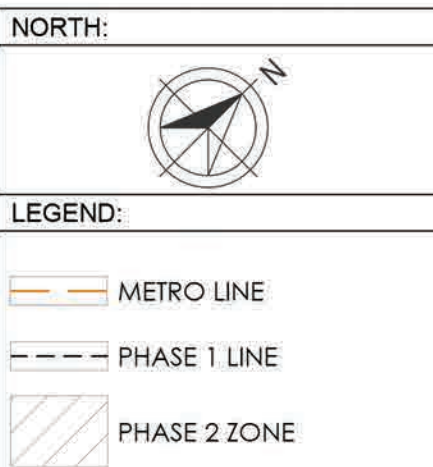

EDRC DWG No : 017203-N-SP-00-WD-0505

Scale : 1:500

Sheet Size : A0

Title : LANDSCAPE PLANTING PLAN - UPPER CANOPY: ZONE 5

REV	DESCRIPTION	DATE	DESIGN	DRAWN	CHECKED	APPD
1	GOOD FOR CONSTRUCTION	20/12/23	N.L.	S.R.	N.L.	P.O.

Revisions

ARCHITECTURE	IFS
STRUCTURAL	PFE
ELECTRICAL	GEORCH
ENV SYSTEM	
HVAC	
CHECKED BY	SIGN
DATE	CHECKED BY
SIGN	DATE

EPC Contractor

L&T Construction
Buildings & Factories

JOB No : 017203

Project Name
DESIGN AND CONSTRUCTION OF INDIA
INTERNATIONAL CONVENTION & EXPO CENTRE
SECTOR 25, DWARKA, NEW DELHI, INDIA

Drawing Status
GOOD FOR CONSTRUCTION (GFC)

Drawing No : N 00 0505 Rev. No : R0

Owner / Employer

India International Convention & Exhibition Centre Limited
Room No. 402A, Ministry of Commerce & Industry,
CPRI, Lodhi Road, New Delhi - 110011, India

Department of Industrial Policy and Promotion Ministry of Commerce & Industry Government of India

Knowledge Partner

Delhi Mumbai Industrial Corridor Development Corporation
Room No. 341 & 3rd floor Hotel Ashok, Rajendra Estate, SBI Colony, New Delhi - 110028

Employer's Representative

Employer Engineer
Programme Management Consultant (PMC)

AECOM

Preliminary Engineering Architecture Consultants (PEAC)

idom **CPKUREJA**

Av. Del Moralejo de El Escorial, 4, No. 2-1, Ashok Building, Green Park, New Delhi, Delhi 110016, India

EPC Contractor

L&T Construction
Buildings & Factories

Mount Road, Marolli Road, Marolli Road, P. B. No. 17, Chennai - 600009

EPC Contractor's Representatives

Design Consultant
Engineering Design and Research Center (EDRC)
L&T Construction - Buildings & Factories

Architectural Consultant

ARCOP
Arcop Associates Pvt. Ltd., A-15, Parkside Enclave, G.E.-1, New Delhi, Delhi 110048, India

Structural Proof Consultant

Indian Institute of Technology (IT) Madras
Sardar Patel Rd, Opposite to C. L. R. Adyar, Chennai, Tamil Nadu 600006

MEP Proof Consultant

Egis India Consulting Engineers Pvt. Ltd., Plot No. 46, Sector 32, Industrial Area, Opp. Sarathi Software, Gurgaon, Haryana 122001

ICT Proof Consultant

CKR
CKR Consulting Engineers Pvt. Ltd., #401, 3rd floor, Harpura Road, Subramanyam Road, Heliappa Circle, Basavanagudi, Bengaluru - 560004

Certification

Design Consultant

Architectural Consultant

Proof Consultant


Structural

MEP

ICT

PEAC

Issued by:
Employer / Employer's Engineer

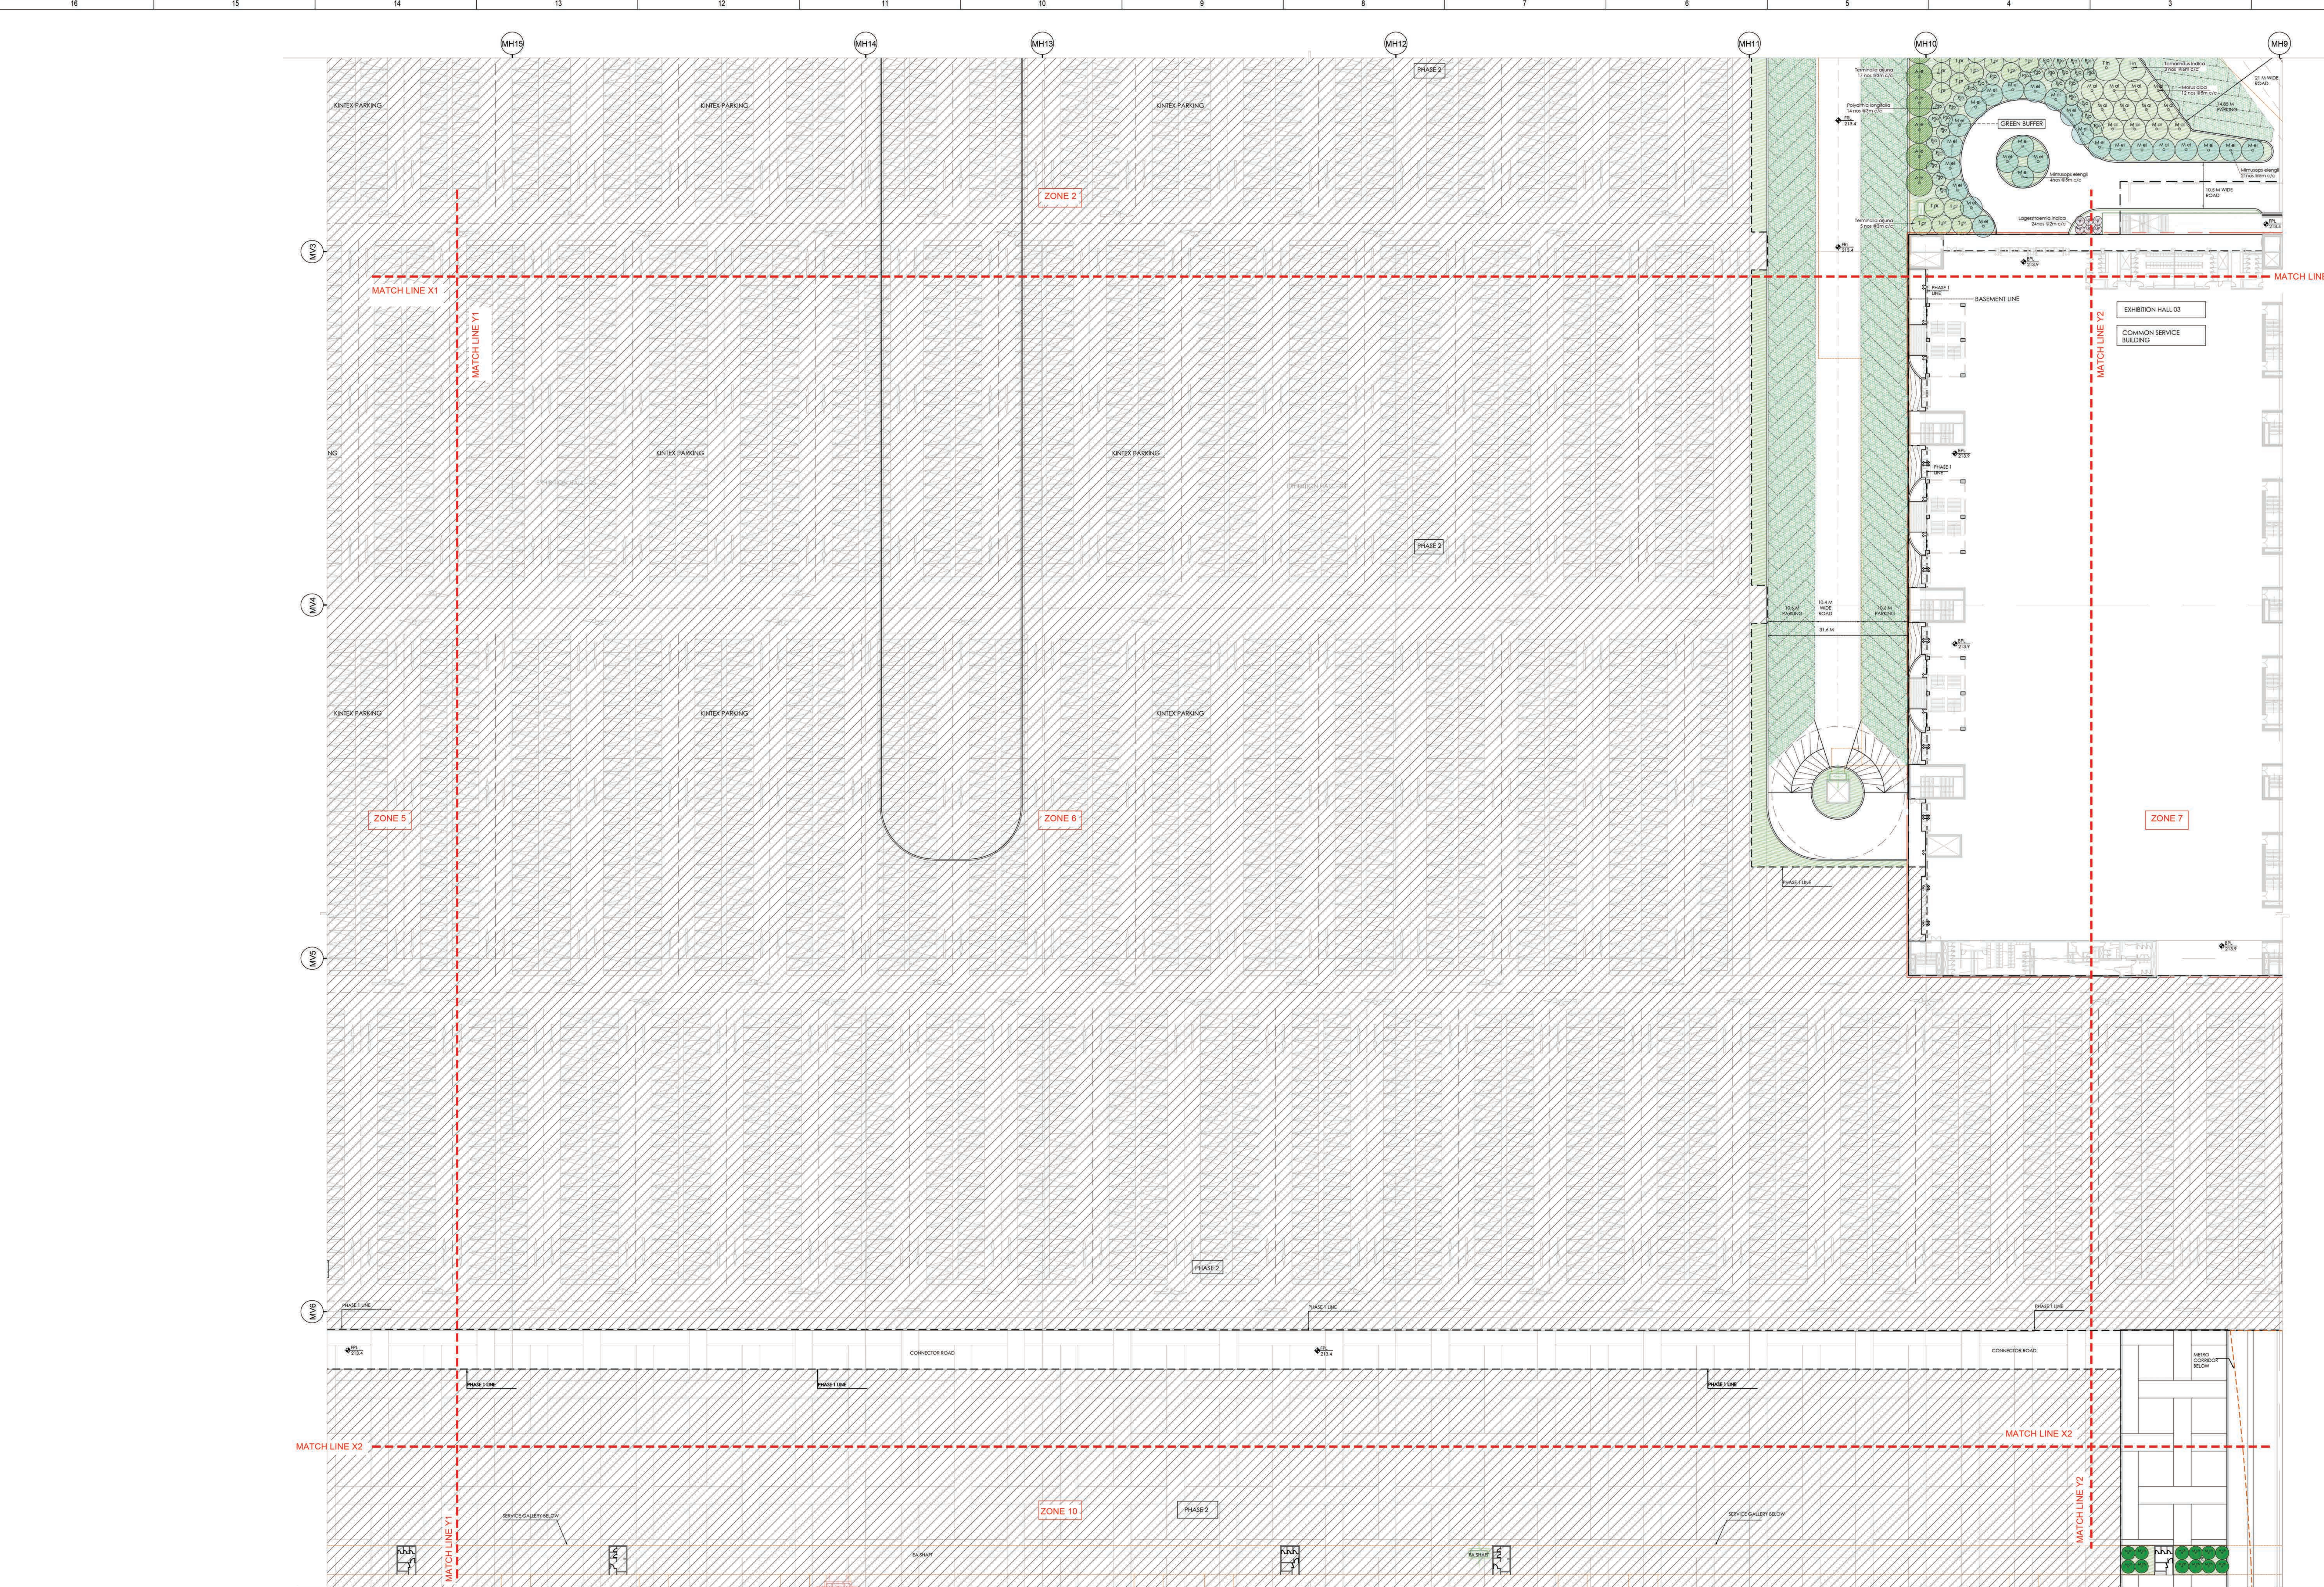

LEGEND FOR PLANTING PLAN : FOR COMPLETE PHASE I				
SYMBOL	SPECIES NAME	COMMON NAME	c/c	
	A in	Azadirachta indica	Neem tree	4.5
	A le	Albizia lebbek	Silk tree	6
	B va	Bauhinia variegata	Kochinar, Orchid Tree	4.15
	B ce	Bombax ceiba	Silk Cotton Tree	4
	C fi	Cassia fistula	Amaltas, Golden shower tree	4.5
	C sp	Ceiba speciosa	Silk floss tree	3.5
	C se	Cordia sebestena	Orange Geiger Tree	3
	C ci	Cordia alliodora	Lemon bottlebrush	3

LEGEND FOR PLANTING PLAN: FOR COMPLETE PHASE I				
SYMBOL		SPECIES NAME	COMMON NAME	c/c
	D si	Dalbergia sissoo	Flame tree, Gulmohar	6
	D si	Dalbergia sissoo	Shisham	3
	E va	Erythrina variegata	Indian Coral tree	3
	F el	Ficus elastica	Rubber fig	4.5
	F ly	Ficus lyrata	Fiddle Leaf fig	3
	F vi	Ficus virens	White Fig	6
	J mi	Jacaranda mimosaeifolia	Neel gulmohar	5



LEGEND FOR PLANTING PLAN : FOR COMPLETE PHASE I				
SYMBOL	SPECIES NAME		COMMON NAME	c/c
	L in	Lagerstroemia indica	Grape myrtle	2
	L sp	Lagerstroemia speciosa	Pride of India	6
	M az	Melia azadirach	Persian Lilac	3
	M el	Mimosa pudica	Moulart, Spanish cherry	5
	M fe	Mesua ferrea	Nag Kesar, Cobra saffron	3
	M ch	Michelia champaca	Champaka, Golden Champaka	3
	M al	Morus alba	White Mulberry	5

LEGEND FOR PLANTING PLAN FOR COMPLETE PHASE I				
SYMBOL	SPECIES NAME		COMMON NAME	c/c
	M pi	Milletia pinnata	Pongam tree, Indian Beech tree	4.5
	P ob	Plumeria obtusa	White Frangipani	3
	P lo	Polyalthia longifolia	Ashok tree	3
	S cu	Syzygium cumini (4.5M C/T)	Java plum, Jamun	6
	T in	Tamarindus indica (6M/C/T)	Tamarind	6
	T aj	Terminalia ajuna (3M/C/T)	Ajuna tree	4.5
	T be	Terminalia bellirica (5M/C/T)	Baheda	5

LEGEND FOR PLANTING PLAN : FOR COMPLETE PHASE I			
SYMBOL	SPECIES NAME		COMMON NAME
	A oc	Anacardophoenix alexandrina	King Palm, Majestic Palm
	C hu	Chamaecyparis humilis	Mediterranean fan palm
	H la	Hyophorba lagenicaulis	Bottle palm
	P ro	Phoenix roebelenii	Miniature date palm
	R re	Roystonea regia	Royal palm
	W fi	Washingtonia filifera	Desert fan palm
	W bi	Wodyetia bifurcata	Fox tail palm

- 017203-N-SP-00-WD-0500 SERIES-PLANTING SET, TO BE REFERRED FOR FOLLOWING POINTS :
- All dimensions are in Meters. Dimensions to be read and shall not be measured from the drawing.
 - Total Quantity shown in legend for the tree plantation is for the complete site of phase 1.
 - For specifications of the proposed trees refer separate document.
 - Green areas and Planting of upper canopy are shown in colored hatches. To get clear understanding print should be taken in colour.
 - Metro corridor line depiction in orange color.
 - No building details shall be referred from planning plan drawing sets.
 - Service gallery and tunnel coming in green areas and landscape plazas to be designed for the tree loading.

- ABBREVIATIONS :
- FRL - FINISHED ROAD LEVEL
 - FPL - FINISHED PAVED LEVEL
 - FGL - FINISHED GROUND LEVEL
 - BPL - BUILDING PAVED LEVEL
 - TOF - TOP OF FILL

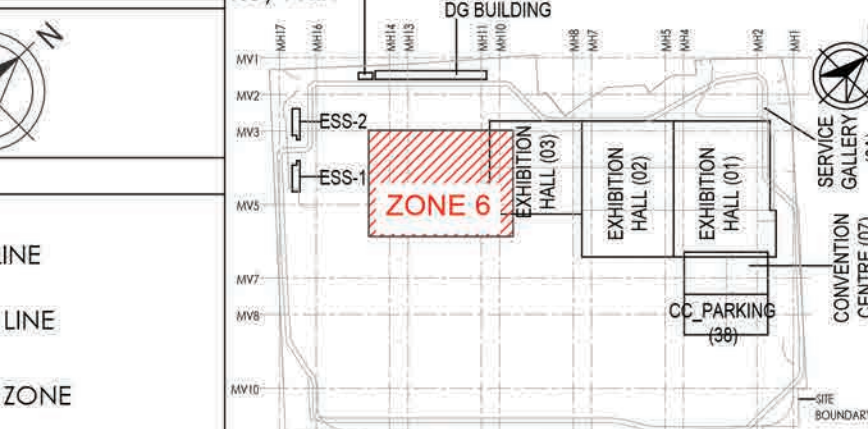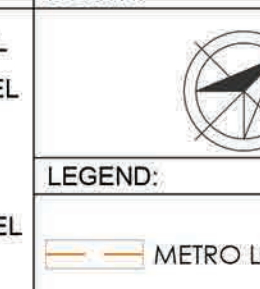

Owner / Employer
India International Convention & Exhibition Centre Limited
Room No. 432A, Ministry of Commerce & Industry,
CPRI, Vasant Vihar, New Delhi - 110011, India

Department of Industrial Policy and Promotion Ministry of Commerce & Industry Government of India

Knowledge Partner
Delhi Mumbai Industrial Corridor Development Corporation
Room No. 301 & 302 Floor 301 & 302, CPRI, Vasant Vihar, New Delhi - 110011, India

Employer's Representative
Programme Management Consultant (PMC)
AECOM

Preliminary Engineering Architecture Consultants (PEAC)
idom **CPKURUJA**

EPC Contractor
L&T Construction
Mount Road, Marolli Nagar, Marolli Nagar, New Delhi - 110028, India

EPC Contractor's Representatives
Design Consultant
Engineering Design and Research Center (EDRC)
L&T Construction - Buildings & Factories

Architectural Consultant
ARCOP
Arcop Associates Pvt. Ltd.,
A-15, Panchsheel Park, New Delhi - 110017, India

Structural Proof Consultant
Indian Institute of Technology (IIT) Madras
Sankar Patel Rd, Opposite to C. L. K. Adyar, Chennai, Tamil Nadu - 600026

MEP Proof Consultant
Egis India Consulting Engineers Pvt. Ltd.,
Plot No. 46, Sector 32, Industrial Area,
Gurgaon, Haryana - 122001

ICT Proof Consultant
C&R Consulting Engineers Pvt. Ltd.,
A-011, 3rd Floor, Naraina Arcade,
Sahibzada Ghalib Road, New Delhi - 110028, India

Certification
Design Consultant
Architectural Consultant
Proof Consultant
Structural **MEP** **ICT**
PEAC
Issued by:
Employer / Employer's Engineer

REV	DESCRIPTION	DATE	SIGN	DRWN	CHKD	APPD
1	GOOD FOR CONSTRUCTION	20/03/20	NL	TS	NL	FOR

REV	DESCRIPTION	DATE	SIGN	DRWN	CHKD	APPD
1	GOOD FOR CONSTRUCTION	20/03/20	NL	TS	NL	FOR

REV	DESCRIPTION	DATE	SIGN	DRWN	CHKD	APPD
1	GOOD FOR CONSTRUCTION	20/03/20	NL	TS	NL	FOR

EPC Contractor
L&T Construction
Buildings & Factories

Project Name
DESIGN AND CONSTRUCTION OF INDIA INTERNATIONAL CONVENTION & EXPO CENTRE SECTOR 25, DWARKA, NEW DELHI, INDIA

Drawing Status
GOOD FOR CONSTRUCTION (GFC)

Drawing No
N 00 0506


Rev. No
R0

Title:
LANDSCAPE PLANTING PLAN - UPPER CANOPY: ZONE 6

EDRC DWG No :
017203-N-SP-00-WD-0506

Scale
1:500

Sheet Size
A0

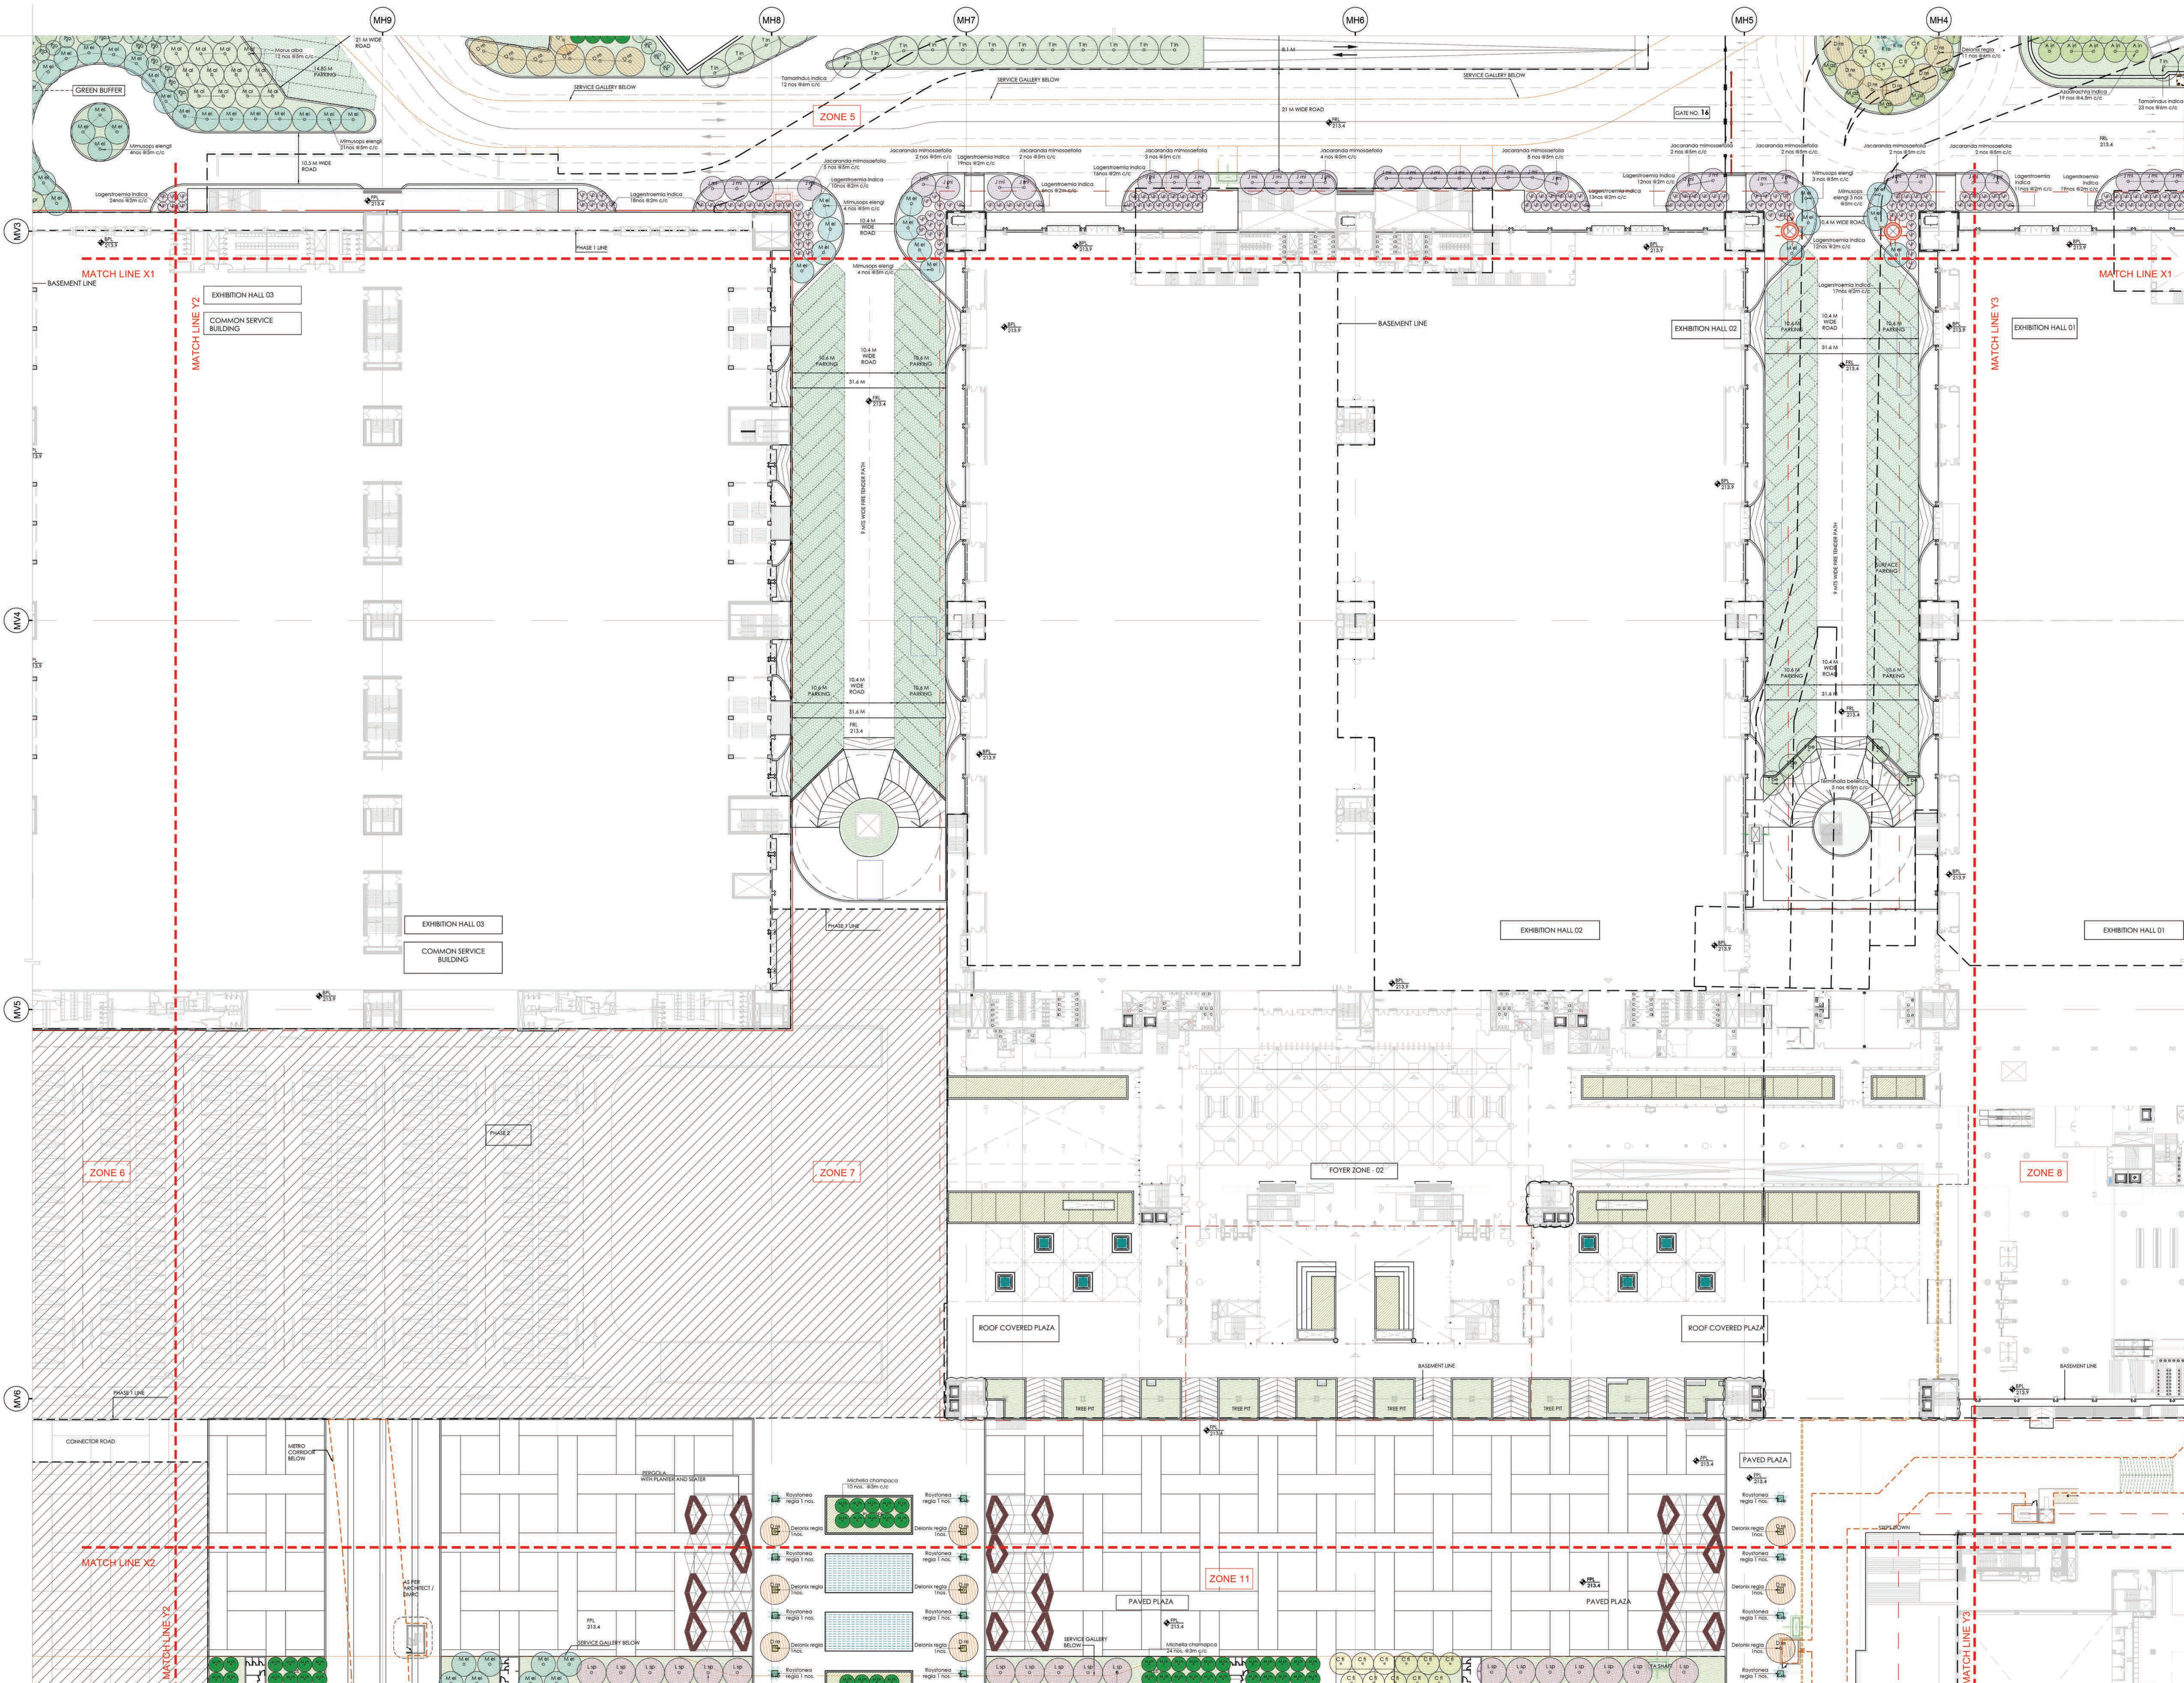

LEGEND FOR PLANTING PLAN - FOR COMPLETE PHASE 1			
SYMBOL	SPECIES NAME	COMMON NAME	C/C
	A in	Azadirachta indica	Neem tree
	A lb	Albizia lebbekii	Silk tree
	B va	Bauhinia variegata	Koachur, Orchid Tree
	B ce	Bombax ceiba	Indian Coral Tree
	C fi	Cassia fistula	Amaltas, Golden Shower tree
	C sp	Celastrus speciosus	Silk Rose tree
	C se	Corda sebestena	Orange Geiger Tree
	C al	Corda allamanda	Lemon bottlebrush

LEGEND FOR PLANTING PLAN - FOR COMPLETE PHASE 1			
SYMBOL	SPECIES NAME	COMMON NAME	C/C
	D re	Delonix regia	Flame Tree, Gulmohar
	D si	Dalbergia sissoo	Shisham
	E va	Erythrina variegata	Indian Coral Tree
	F el	Ficus elastica	Rubber fig
	F ly	Ficus lyrata	Tadpole Leaf Fig
	F vi	Ficus virens	White fig
	J mi	Jacaranda mimosaefolia	Neel gulmohar

LEGEND FOR PLANTING PLAN - FOR COMPLETE PHASE 1			
SYMBOL	SPECIES NAME	COMMON NAME	C/C
	L in	Lagerstroemia indica	Chapel myrtle
	L sp	Lagerstroemia speciosa	Pride of India
	M az	Mela azeedarach	Pentam Lilac
	M pu	Mimosa pudica	Moussouri, Spanish cherry
	M fe	Mesua ferrea	Nag Kesari, Cobra lathyrus
	M ch	Michelia champaca	Champa, Golden Champa
	M al	Morus alba	White Mulberry

LEGEND FOR PLANTING PLAN - FOR COMPLETE PHASE 1			
SYMBOL	SPECIES NAME	COMMON NAME	C/C
	M pi	Mitella pinnata	Pongam tree, Indian Beach tree
	P ab	Plumeria alabastrum	White Frangipani
	P lo	Polyalthia longifolia	Ashok tree
	S cu	Syzygium cumini	Jamun plum, Jamun
	T in	Tamarindus indica	Tamarind
	T al	Terminalia alata	Adju tree
	T be	Terminalia bellirica	Baheda


LEGEND FOR PLANTING PLAN - FOR COMPLETE PHASE 1			
SYMBOL	SPECIES NAME	COMMON NAME	C/C
	A al	Archontophoenix alexandrina	King Palm, Majestic Palm
	C hu	Chamaecyparis humilis	Mediterranean fan palm
	H gl	Hypochoeris glaucaulifolia	Bottle palm
	P ro	Phoenix roebelenii	Miniature date palm
	R re	Roystonea regia	Royal palm
	W fi	Washingtonia filifera	Desert fan palm
	W bi	Wodyetia bifurcata	Fox tail palm

017203-N-SP-00-WD-0500 SERIES-PLANTING SET, TO BE REFERRED FOR FOLLOWING POINTS:

- All dimensions are in Meters. Dimensions to be read and shall not be measured from the drawing.
- Total quantity shown in legend for the tree plantation is for the complete site of phase 1.
- For specifications of the proposed trees refer separate document.
- Green areas and planting of upper canopy are shown in colored hatches. To get clear understanding print should be taken in colour.
- Metro corridor line depiction in orange colour.
- No building details shall be referred from planning plan drawing sets.
- Service gallery and funnel coming in green areas and landscape plazas to be designed for the tree loading.

ABBREVIATIONS:

- FRL - FINISHED ROAD LEVEL
- FPL - FINISHED PAVED LEVEL
- FGL - FINISHED GROUND LEVEL
- BPL - BUILDING PAVED LEVEL
- TOF - TOP OF FILL

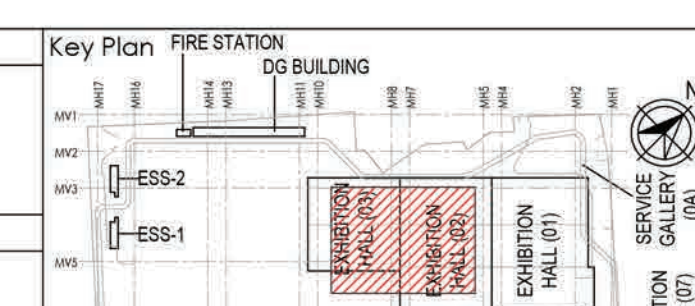

Owner / Employer

India International Convention & Exhibition Centre Limited
Room No. 432A, Ministry of Commerce & Industry,
CPRI, 15/15/15/15, New Delhi - 110011, India

Department of Industrial Policy and Promotion Ministry of Commerce & Industry
Government of India

Knowledge Partner

Delhi Mumbai Industrial Corridor
Development Corporation
Room No. 301 & 302, 3rd Floor, HSIIDC,
Sector 15, Gurgaon, Haryana, India

Employer's Representative

Programme Management Consultant (PMC)

AECOM

Preliminary Engineering Architecture Consultants (PEAC)

idom **CPKURUJA**

Av. Del Marquillo de E. Barco, 4, No. D-1, Ashwini Building, Green Park,
28001 Madrid, Spain New Delhi, India 110016, India

EPC Contractor

L&T Construction
Buildings & Factories

Mount Poonam Road, Marolpuri,
P. B. No. 17, Chennai - 600 099

EPC Contractor's Representatives

Design Consultant

Engineering Design and Research Center (EDRC)
L&T Construction - Buildings & Factories

Architectural Consultant

ARCOP

Arco Associates Pvt. Ltd.,
A-15, Panchsheel Enclave, G-1,
New Delhi, India 110016, India

Structural Proof Consultant

Indian Institute of Technology (IIT) Madras
Sankar Patel Rd, Opposite to C. I. R. Adyar, Chennai,
Tamil Nadu 600034

MEP Proof Consultant

Egis India Consulting Engineers Pvt. Ltd.
Plot No. 46, Sector 32, Institutional Area,
Gurgaon, Haryana, India 122001

ICT Proof Consultant

CKR Consulting Engineers Pvt. Ltd.
#401, 3rd Floor, Haryana Road,
Subramanyam Road, Nellore, Andhra Pradesh,
Bapatnagar, Bangalore - 560004

Certification

EPC Contractor

Design Consultant

Architectural Consultant

Proof Consultant

Structural

MEP

ICT

PEAC

Issued by:

Employer / Employer's Engineer

RE	GOOD FOR CONSTRUCTION	REVIS	N/A	TA	N/A	FO
REV	DESCRIPTION	DATE	DSGN	DRWN	CHKD	APPD

Revisions

ARCHITECTURE	REV	DATE
STRUCTURAL	REV	DATE
ELECTRICAL	REV	DATE
MEP	REV	DATE
ICT	REV	DATE

WAC: CHECKED BY: SIGN DATE CHECKED BY: SIGN DATE

EPC Contractor

L&T Construction
Buildings & Factories

JOB No: 017203

Project Name

DESIGN AND CONSTRUCTION OF INDIA
INTERNATIONAL CONVENTION & EXPO CENTRE
SECTOR 25, DWARKA, NEW DELHI, INDIA

Drawing Status

GOOD FOR CONSTRUCTION (GFC)

Drawing No

N 00 0507

Rev. No

R0

Title:

LANDSCAPE PLANTING PLAN -
UPPER CANOPY: ZONE 7

EDRC DWG No: 017203-N-SP-00-WD-0507

Scale

1:500

Sheet Size

A0