



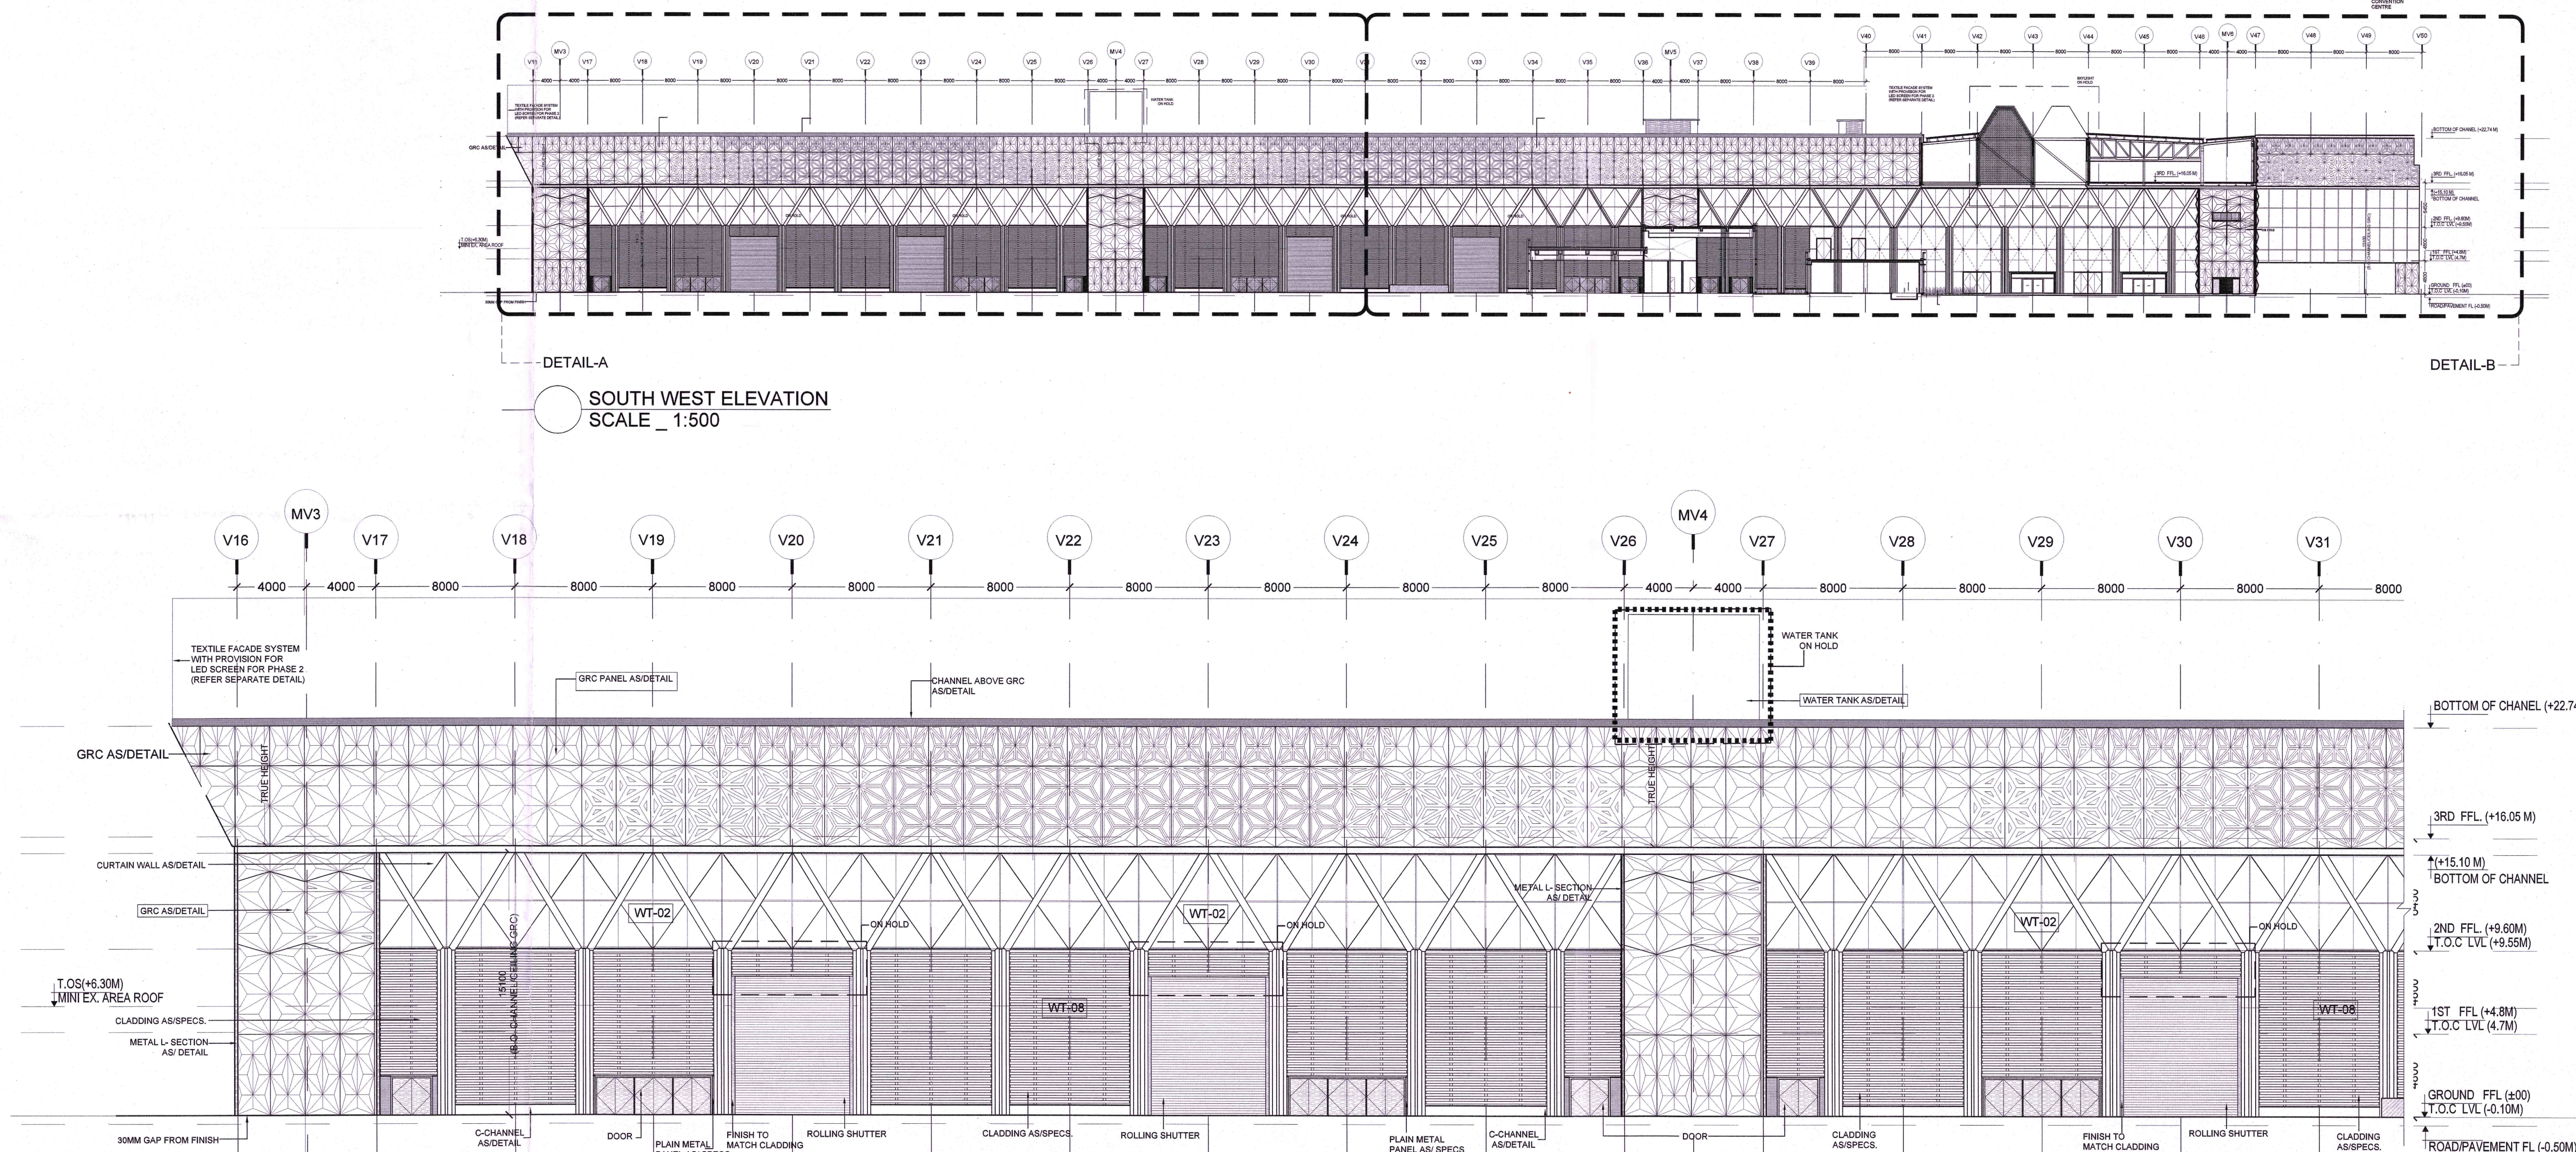

ELEVATION (DETAIL-A)
SCALE 1:200

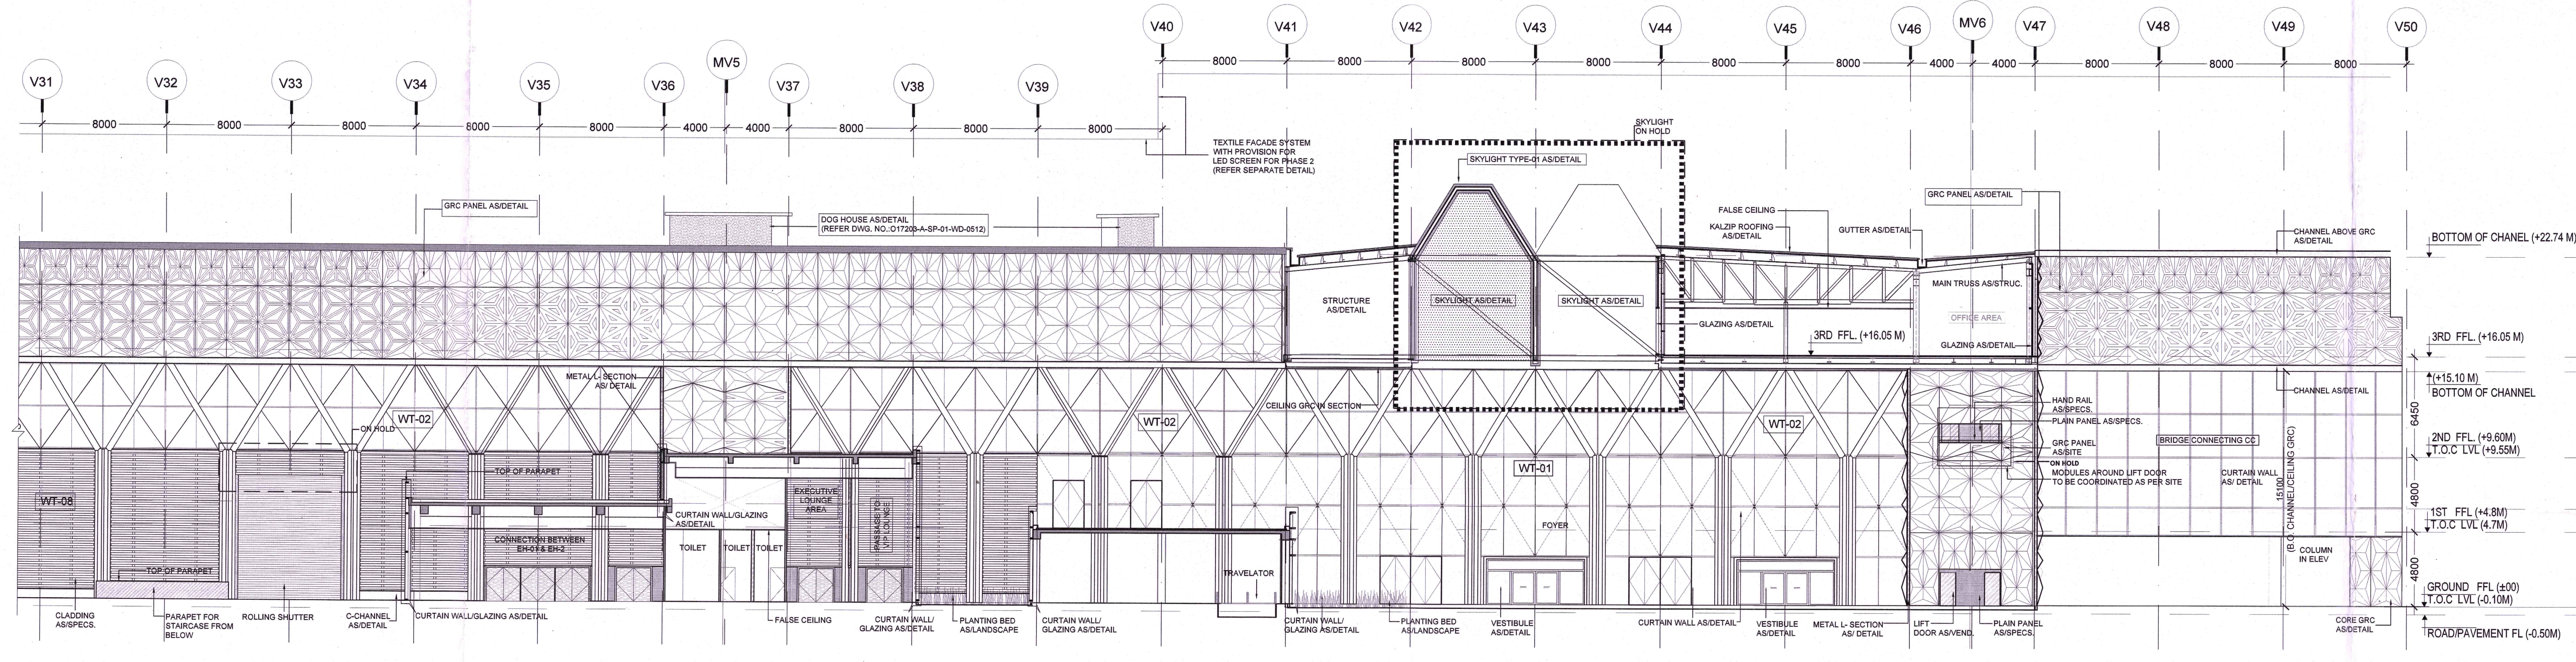


SOUTH WEST ELEVATION (DETAIL-B)
SCALE 1:200

- NOTES:
1. ALL DIMENSIONS ARE IN MILLIMETERS, LEVELS IN METERS AND ANGLES IN DEGREES UNLESS OTHERWISE NOTED.
 2. THE DRAWING IS TO BE READ AND NOT TO BE SCALED; ONLY WRITTEN DIMENSIONS IN ALL CASES SHALL BE FOLLOWED.
 3. THE DRAWING SHALL BE READ IN CONJUNCTION WITH ALL RELEVANT ARCHITECTURAL, STRUCTURAL AND SERVICE DRAWINGS.
 4. ALL DIMENSIONS SHALL BE VERIFIED ON SITE PRIOR TO START OF WORK AND ANY DISCREPANCY SHALL BE BROUGHT TO THE NOTICE OF THE ARCHITECT.
 5. 0.00 CORRESPONDENCE TO 210.9
 6. FOR GRC DETAILS, REFER SEPARATE GRC PACKAGE.
 7. FOR WALL TYPE DETAILS, REFER SEPARATE FACADE PACKAGE.

Wall Types	Description
WT-01	Horizontal Fin System ('X' Bracing start from first level of Aluminium Transom)
WT-02	Tension rod cable system
WT-08	Aluminium Siding with Bronze finish
	Plain Panels as' Specs

ALL FINISH FOR (WT-08, DOOR, ROLLING SHUTTER) WILL BE CAPTURED IN SEPARATE DOCUMENT AFTER APPROVAL FROM PEAC.

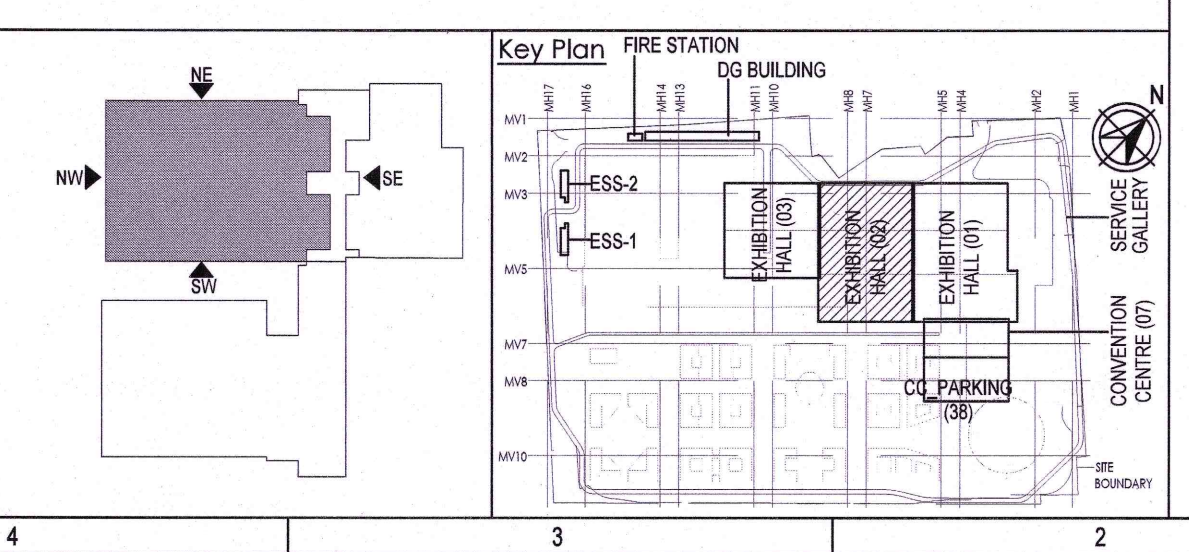

Owner / Employer

India International Convention & Exhibition Centre Limited
Room No. 341, 3rd Floor, New Delhi
110011, India

Department of Industrial Policy and Promotion
Ministry of Commerce & Industry
Government of India

Knowledge Partner

Delhi Mumbai Industrial Corridor Development Corporation
Room No. 341, 3rd Floor, New Delhi
110011, India

Employer's Representative

Employer Engineer
Programme Management Consultant (PMC)

AECOM

Preliminary Engineering Architecture Consultants (PEAC)

idom

Av. Del Marqués de Eizola, 4
2804 Madrid Spain

CPKUREU

No. D-1, Ashwini Building, Green Park
New Delhi 110016, India

EPC Contractor

L&T Construction
Buildings & Factories

Mount Postmodern Road, Manappuram,
Pattukkottai, Chennai - 605009

EPC Contractor's Representatives

Design Consultant
Engineering Design and Research Center (EDRC)
L&T Construction - Buildings & Factories

Architectural Consultant

ARCCOP
Arccop Associates Pvt. Ltd.
A-13, Parkside, Sector 17, Gurgaon
New Delhi 110048, India

Structural Proof Consultant

Indian Institute of Technology (IIT) Madras
Gopal Patel, Opposite to C.I.L. Nagar, Chennai
Tamil Nadu 600035

MEP Proof Consultant

Egn India Consulting Engineers Pvt. Ltd.
Plot No. 48, Sector 52, Institutional Area
Cap. Sarathi, Gurgaon,
Haryana 122001

ICT Proof Consultant

CKR Consulting Engineers Pvt. Ltd.
4/71, 3rd Floor, Nageswara Nagar
Subramanyam Road, Nellore District
Nellore, Andhra Pradesh - 522009

EPC Contractor

Design Consultant

Architectural Consultant

Proof Consultant

Structural

MEP

ICT

MAC

Reviewed GFC drawing prepared by Contractor and ensured that all preliminary aspects and parameters have been addressed.

Issued by

Employer / Employer Engineer

09 SEP 2019

Rev

Rev	DESCRIPTION	DATE	DESIGN	DRW	CHKD	APPR
01	ISSUED FOR GFC	09/09/2019	NA	NA	NA	NA

Revisions

Rev	DESCRIPTION	DATE	DESIGN	DRW	CHKD	APPR
01	ISSUED FOR GFC	09/09/2019	NA	NA	NA	NA

EPC Contractor

L&T Construction
Buildings & Factories

JOB No.: 017203

Project Name
DESIGN AND CONSTRUCTION OF INDIA
INTERNATIONAL CONVENTION & EXPO CENTRE
SECTOR 25, DWARKA, NEW DELHI, INDIA

Drawing Status
GOOD FOR CONSTRUCTION

Drawing No
A 01 0202

Rev. No
R0

Title:
EXHIBITION HALL - 1
ELEVATION SOUTH WEST

EDRC DWG No.:
017203-A-SP-01-WD-0202

Scale
1:500, 1:200

Sheet Size
A0